

## COMPONENTS OF CONTRACT PLANS SET

ROADWAY PLANS  
SIGNING & PAVEMENT MARKING PLANS  
SIGNALIZATION PLANS (FUTURE SUBMITTAL)  
INTELLIGENT TRANSPORTATION SYSTEMS PLANS (FUTURE SUBMITTAL)  
LIGHTING PLANS (FUTURE SUBMITTAL)  
LANDSCAPE PLANS (FUTURE SUBMITTAL)  
ARCHITECTURAL PLANS (FUTURE SUBMITTAL)  
STRUCTURE PLANS (FUTURE SUBMITTAL)



Exhibit 1


**STATE OF FLORIDA**  
**DEPARTMENT OF TRANSPORTATION**

**CONTRACT PLANS**

FINANCIAL PROJECT ID 220664-2-52-01

WALTON COUNTY (60040)


STATE ROAD NO. 83 (US 331)

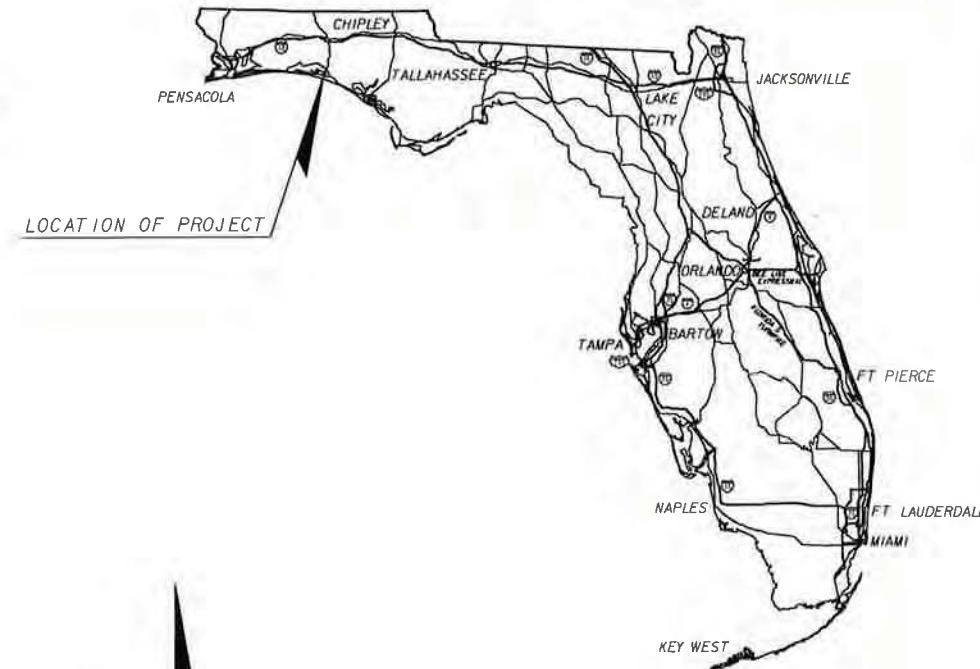

LOCATION OF PROJECT

END PROJECT

B CONST. NB US 331  
STA. 189+17.93  
MP 4.934

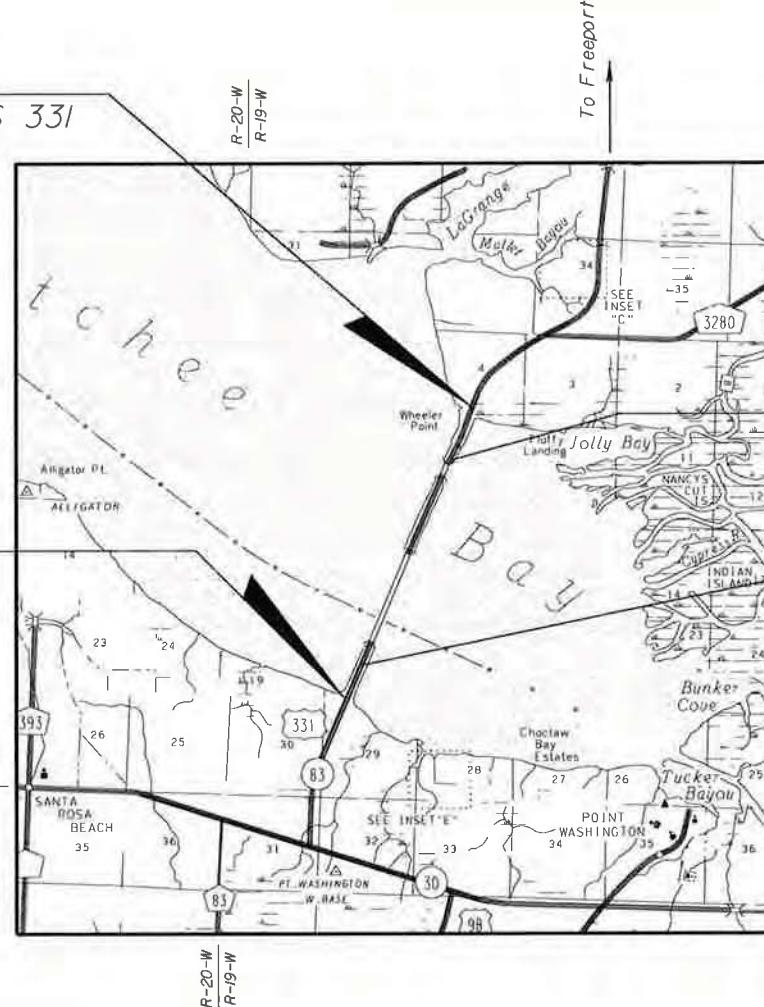

PROJECT LENGTH IS BASED ON B OF CONSTRUCTION

## LENGTH OF PROJECT

	LINEAR FEET	MILES
ROADWAY	5862.00	1.110
BRIDGES	12055.61	2.283
NET LENGTH OF PROJECT	17917.61	3.393
EXCEPTIONS		
GROSS LENGTH OF PROJECT	17917.61	3.393

FDOT PROJECT MANAGER: Kerrie Harrell, P.E.

KEY SHEET REVISIONS		
DATE	BY	DESCRIPTION

S.R. 83 From Chat Holley Rd to Jolly Bay Rd

ROADWAY PLANS  
ENGINEER OF RECORD: CHRISTOPHER D DAVIS

P.E. NO. 063070

FISCAL YEAR	SHEET NO.
13	1

ROADWAY SHOP DRAWINGS  
TO BE SUBMITTED TO:

Charles Rudie, PE  
Parsons Brinckerhoff  
2202 North West Shore Blvd. Suite 300  
Tampa, Florida 33607  
(813) 520-4394



PLANS PREPARED BY:

Parsons Brinckerhoff, Inc.  
121 W. Trade Street, Suite 1950  
Charlotte, NC 28202  
(704) 342-8463  
Vendor No. III531569  
Cert. of Auth. No. 01462  
EOR: Christopher D. Davis, P.E. No. 63070



100% ROADWAY PLANS  
SUBMITTED 01/16/14

NOTE: THE SCALE OF THESE PLANS MAY  
HAVE CHANGED DUE TO REPRODUCTION.

Ch D  
1/16/14

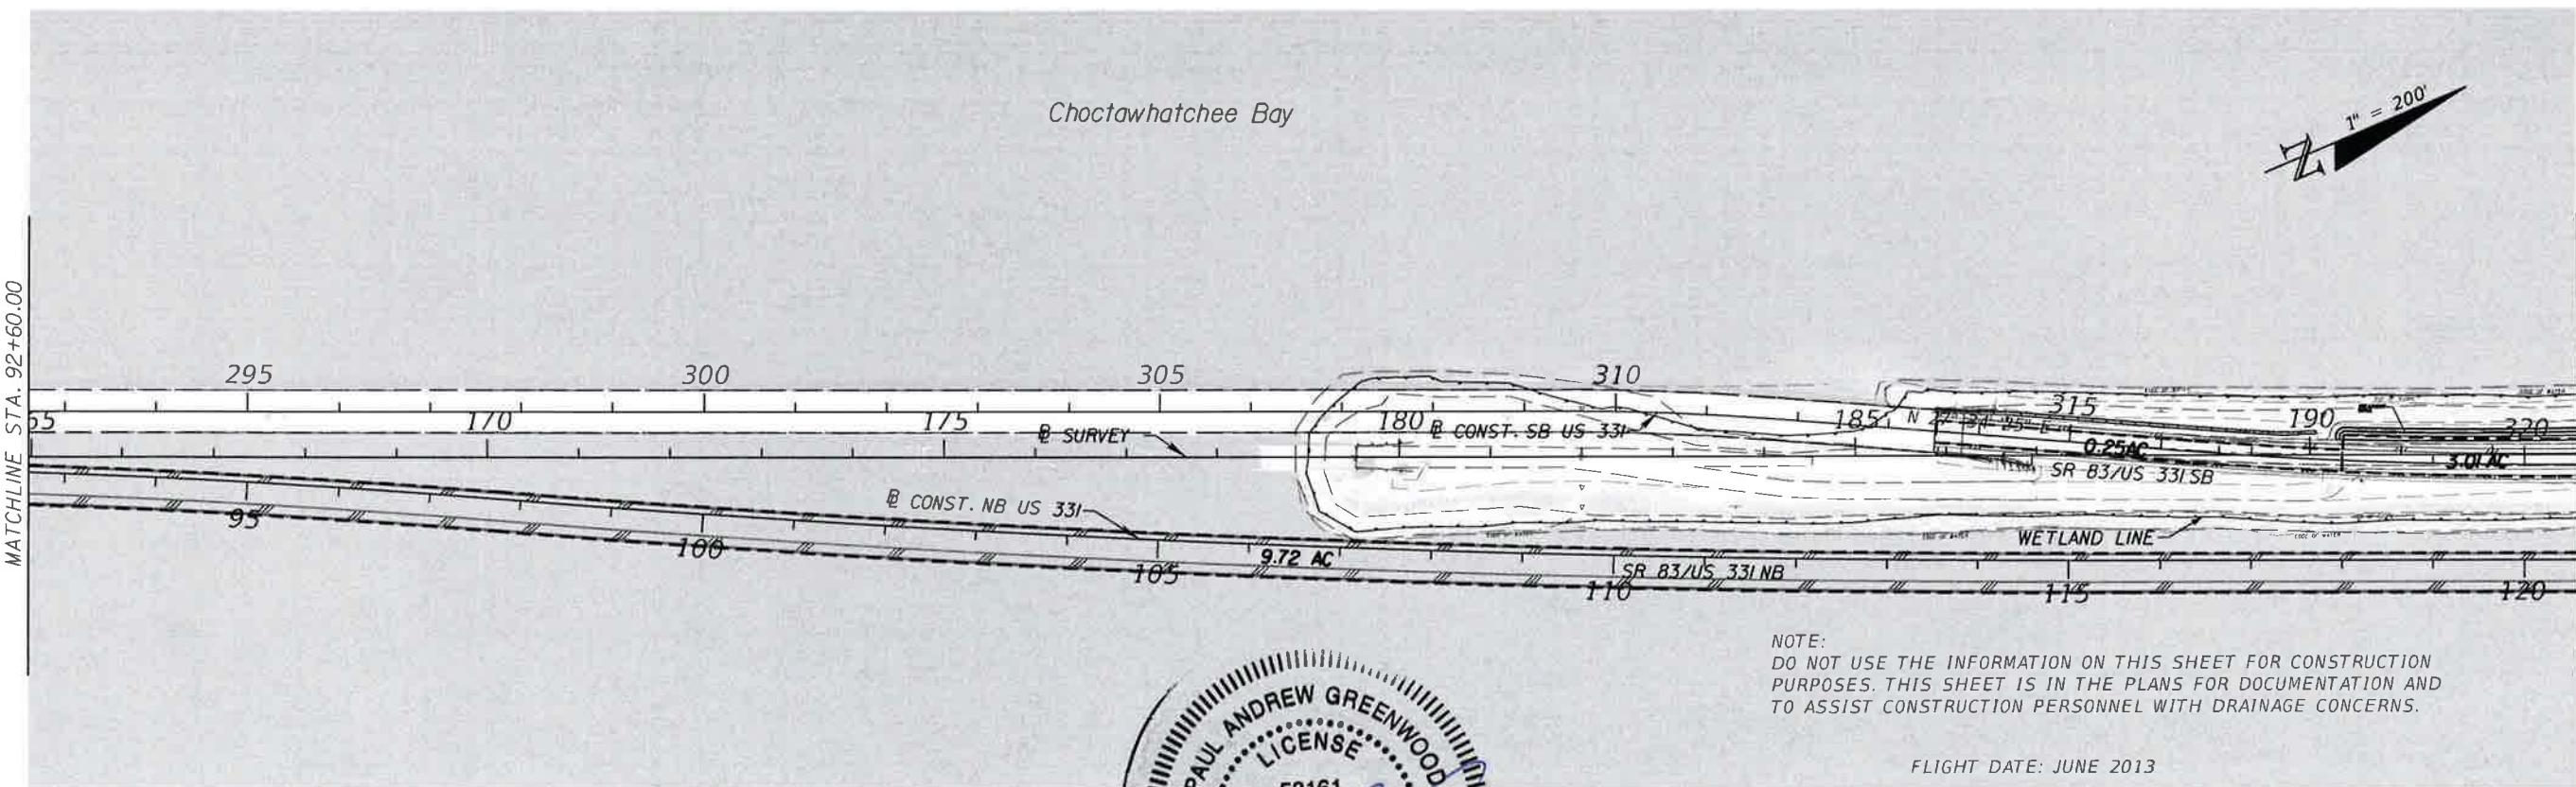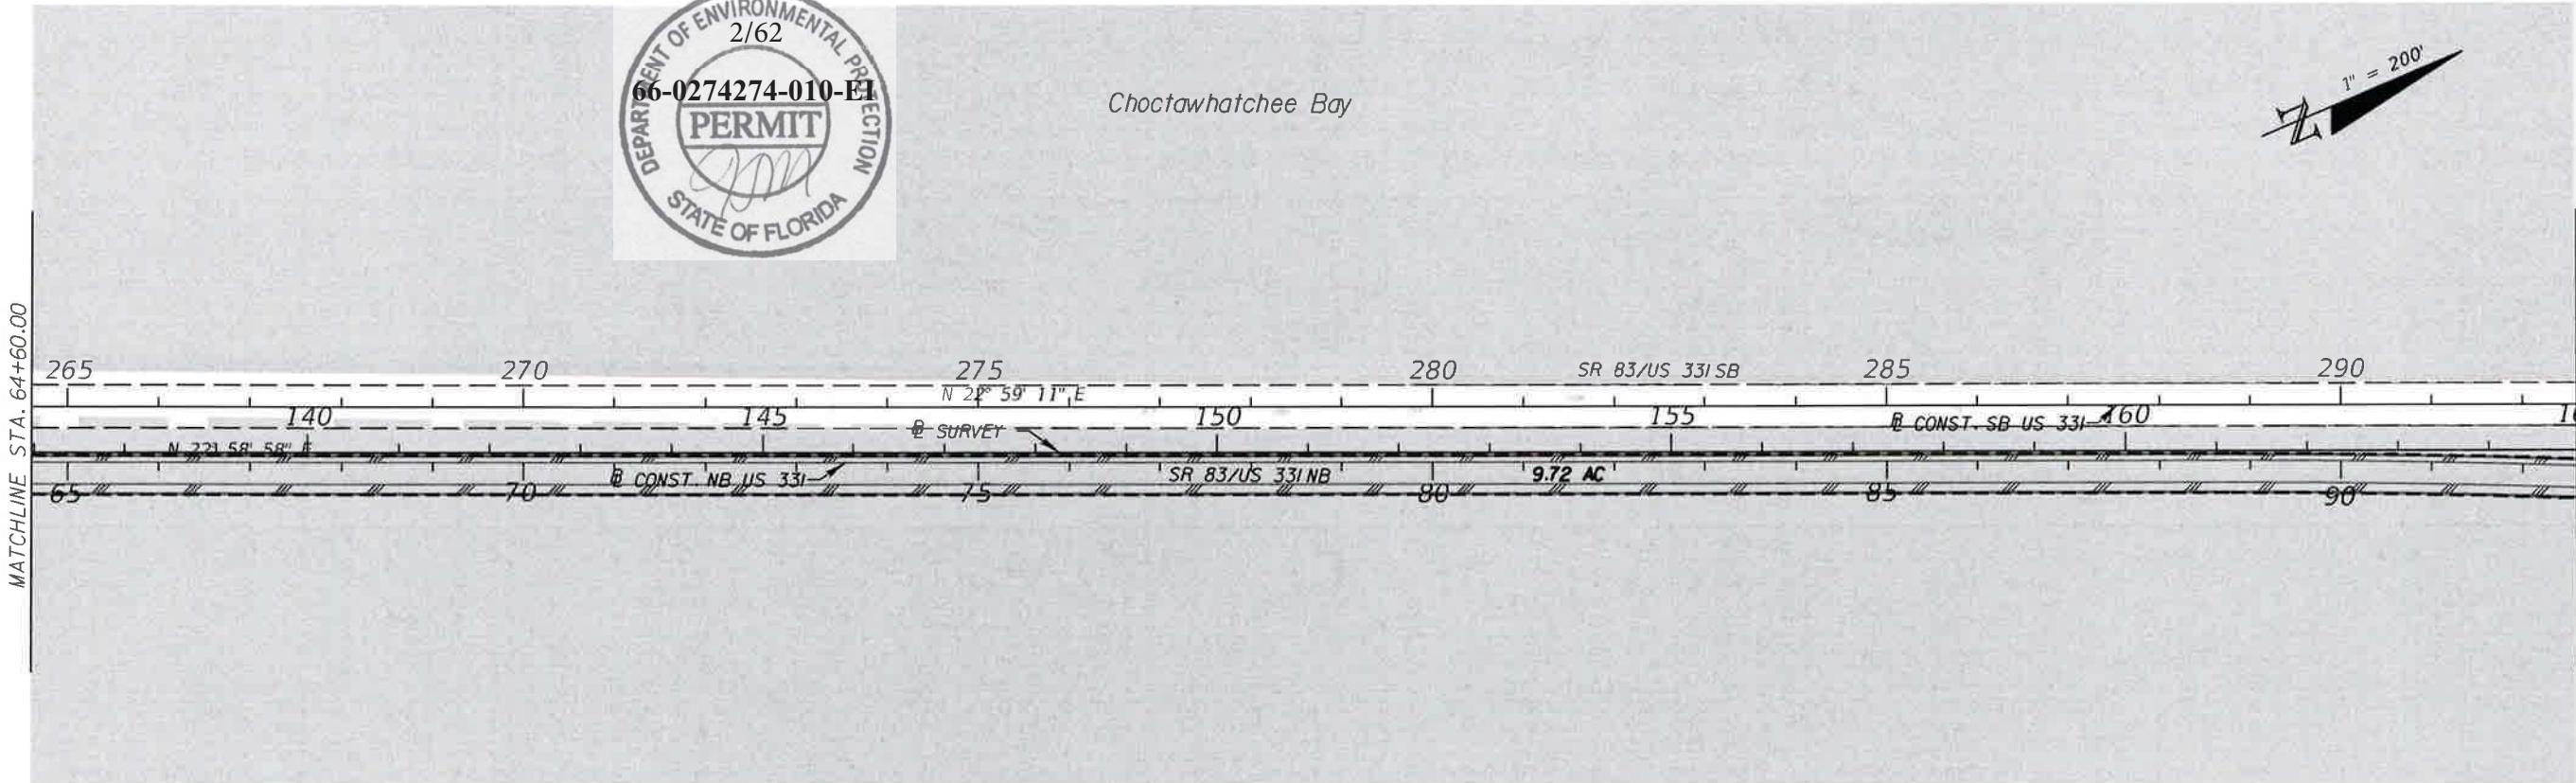

REVISIONS				STATE OF FLORIDA DEPARTMENT OF TRANSPORTATION	COUNTY	FINANCIAL PROJECT ID	SHEET NO.
DATE	DESCRIPTION	DATE	DESCRIPTION				
				ANDERSON	WALTON	220664-2-52-01	DRAINAGE MAP (2)
							3

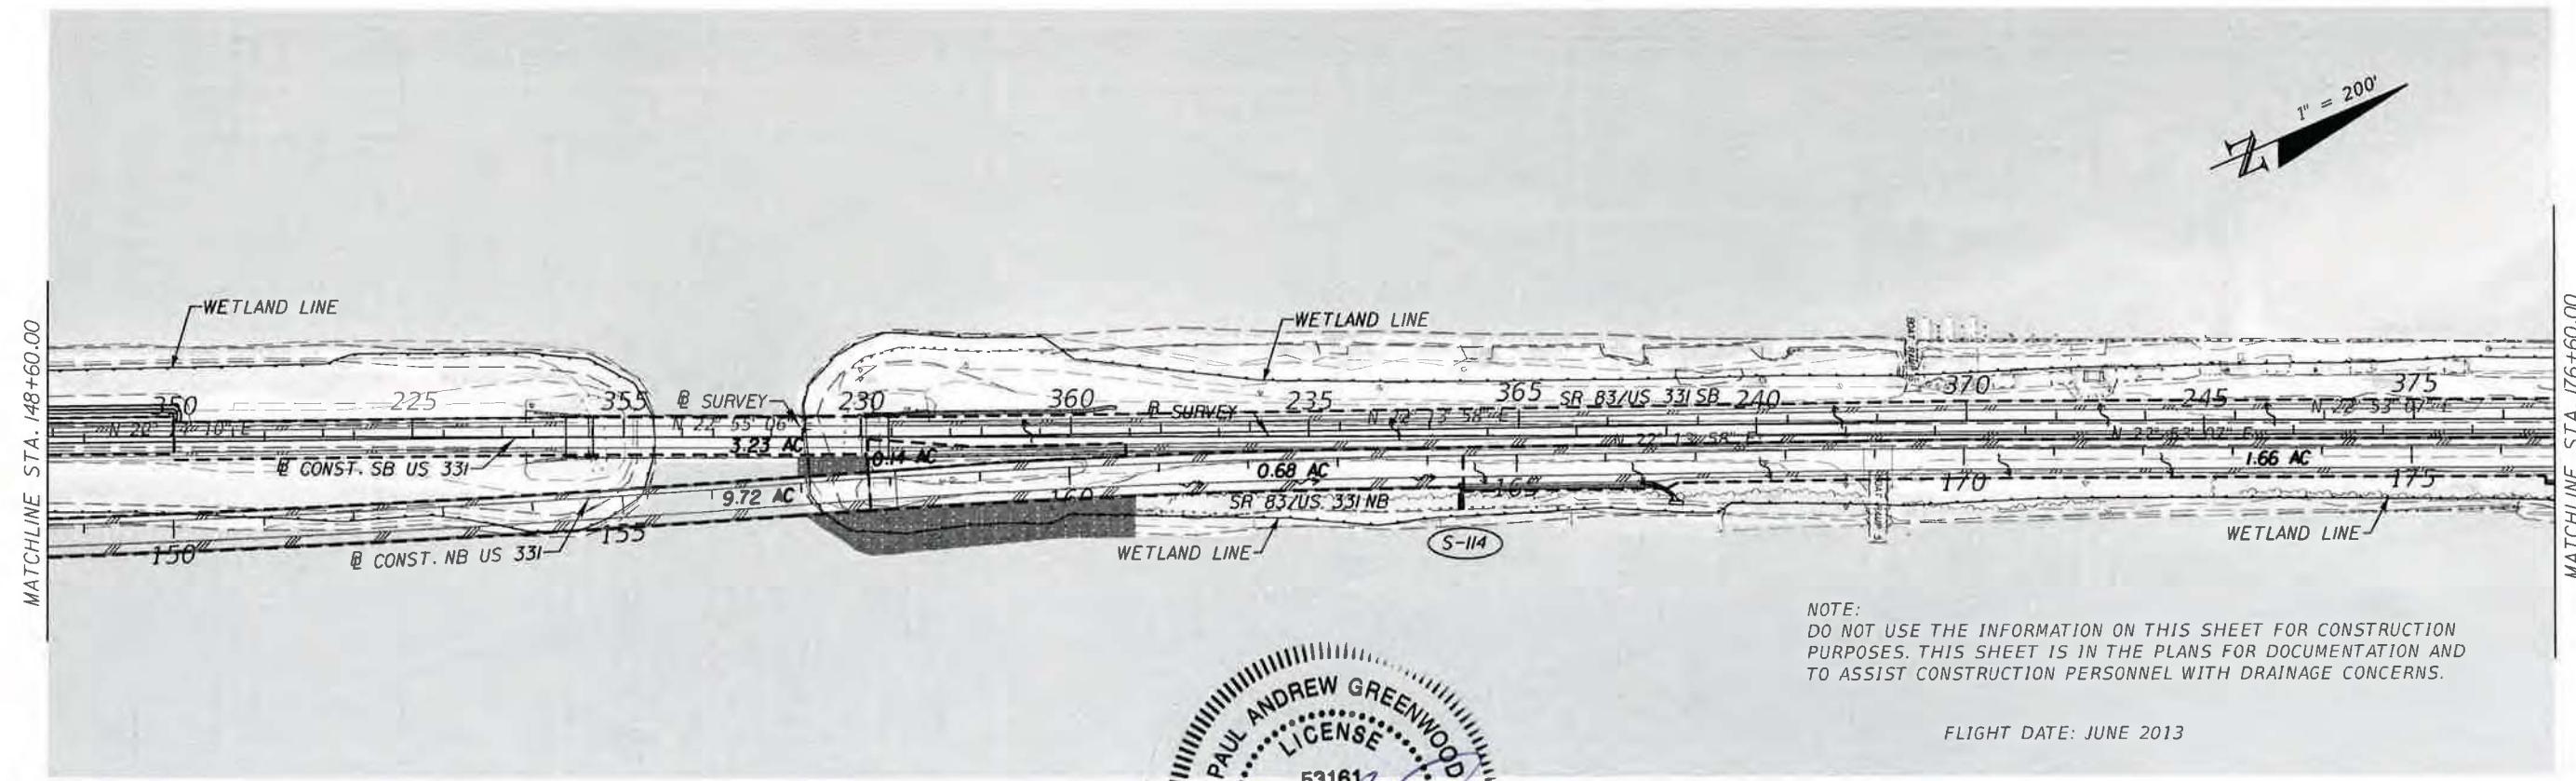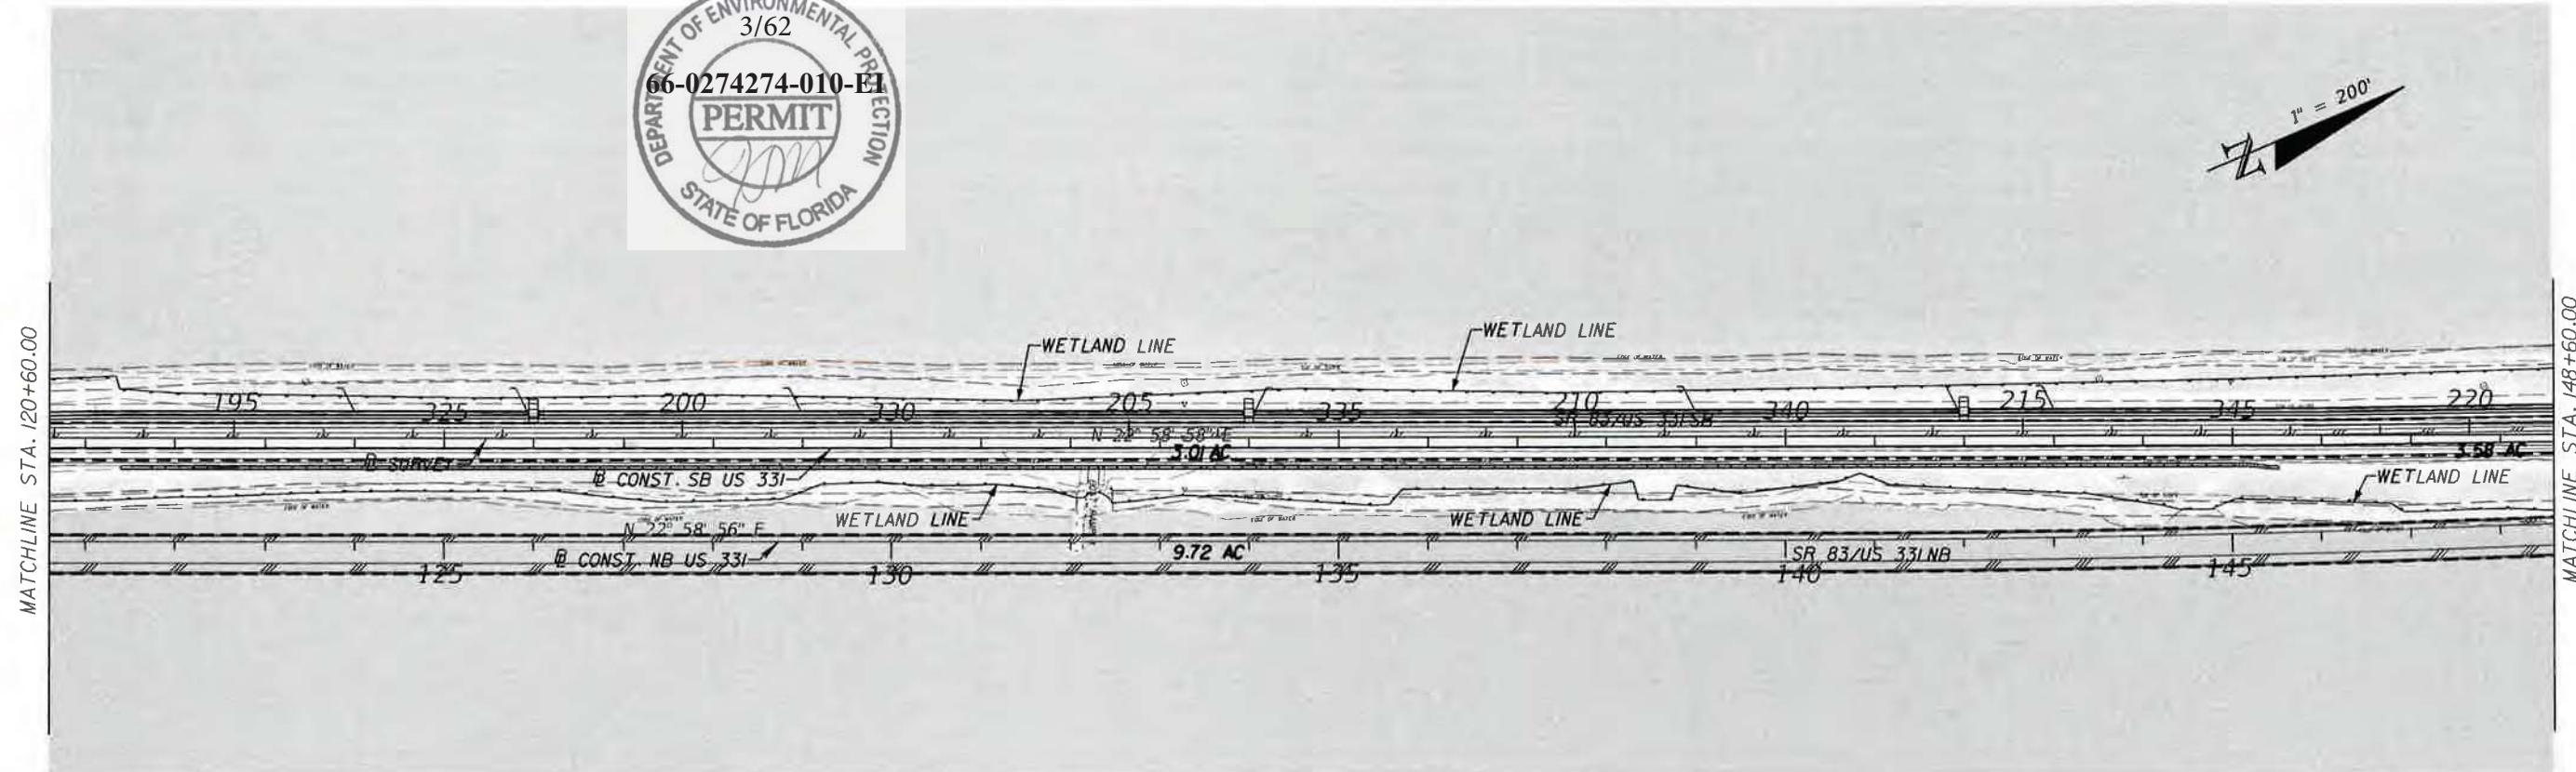

REVISIONS			
DATE	DESCRIPTION	DATE	DESCRIPTION

SP10DRVS  
\$PENTBLL\$

Parsons Brinckerhoff, Inc.  
2202 North West Shore Blvd, Suite 500  
Tampa, Florida 33607  
(813) 520-4444  
Cert. of Auth. No. 01462  
EOR: Andy Greenwood, P.E. N.F.P.E.D.

STATE OF FLORIDA  
DEPARTMENT OF TRANSPORTATION  
PROFESSIONAL ENGINEER  
ROAD NAME  
COUNTY  
FINANCIAL PROJECT ID


WALTON 220664-2-52-01



DRAINAGE MAP (3)

SHEET NO.

4

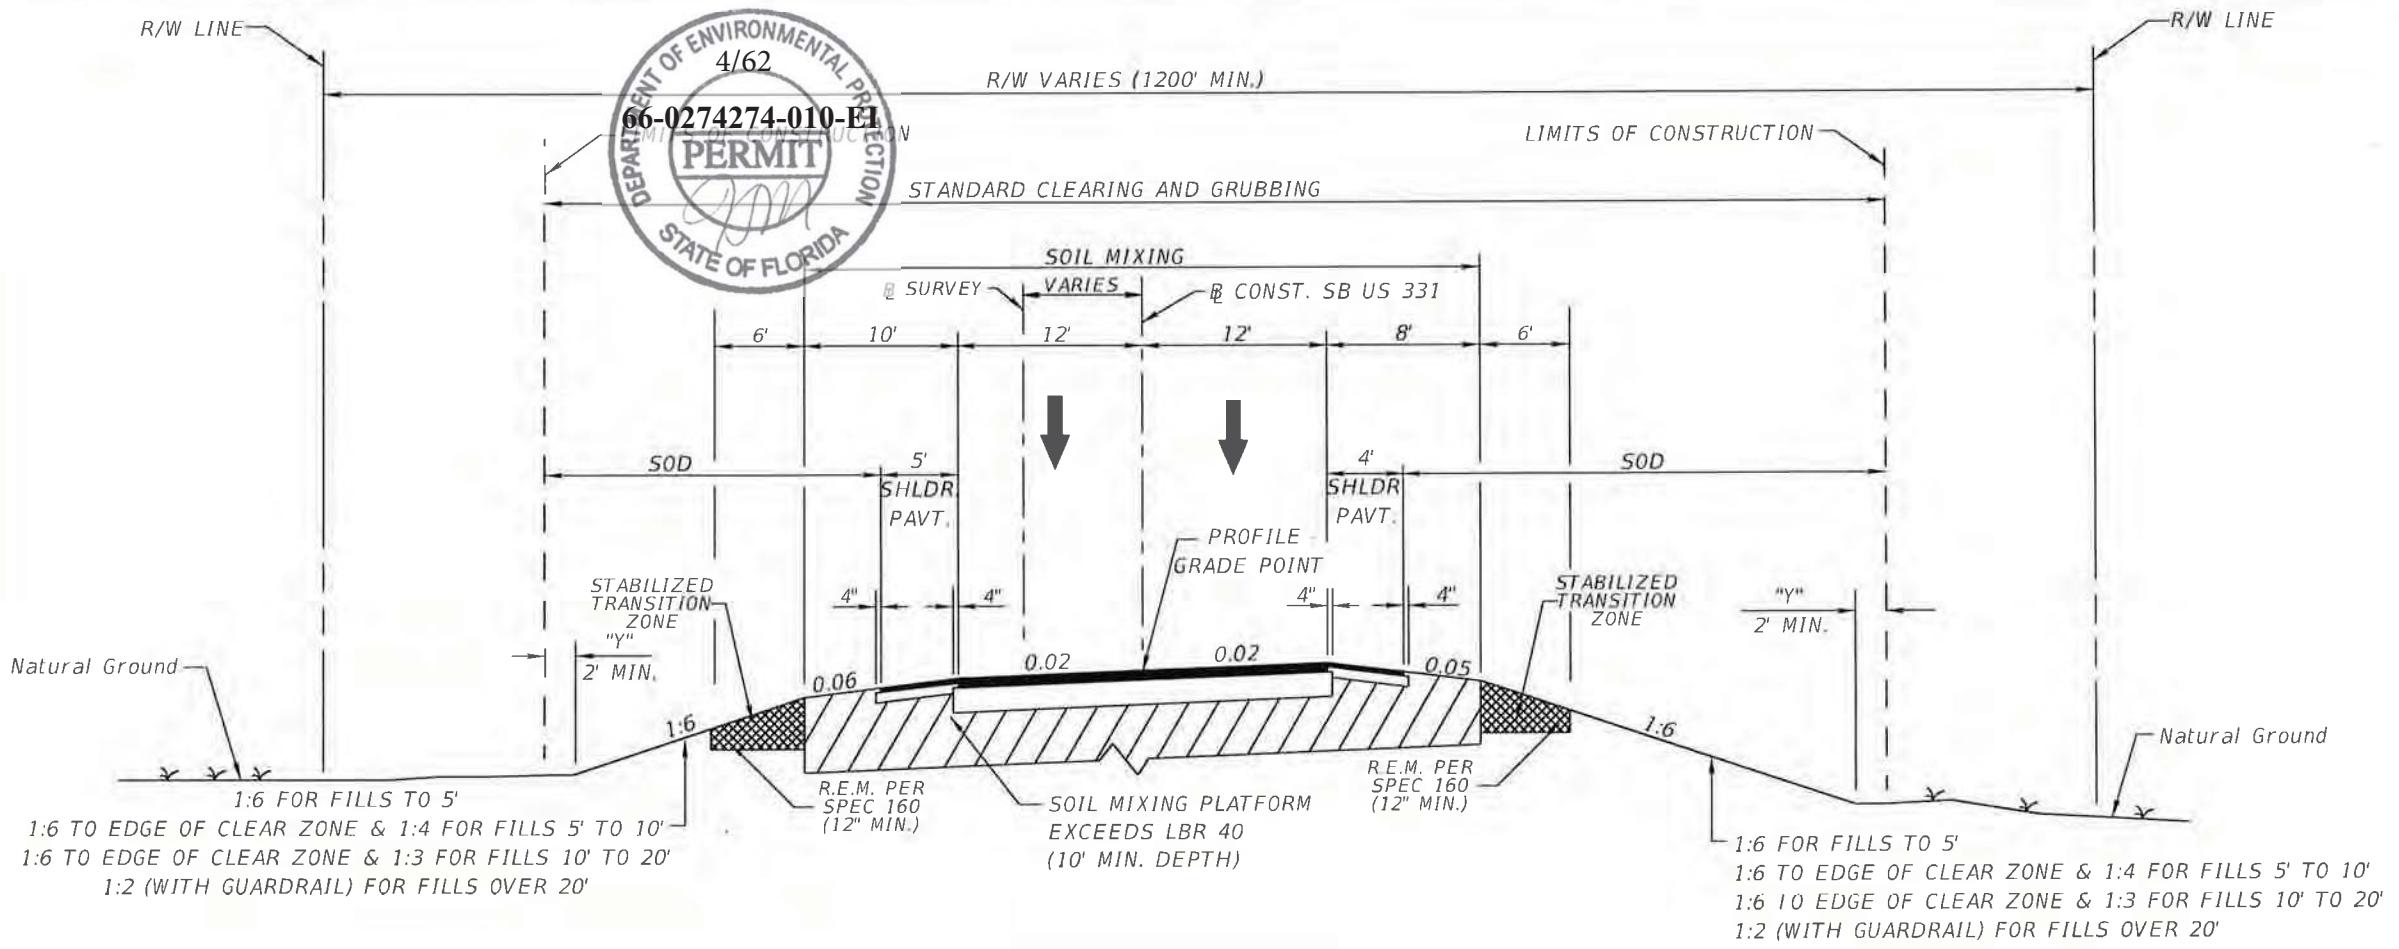

**TYPICAL SECTION**  
**SR 83 (US 331)**  
**STA. 313+51.94 TO STA. 354+66.44**  
**(# CONST. SB US 331)**

**NEW CONSTRUCTION**

OPTIONAL BASE GROUP 9 WITH  
 TYPE SP STRUCTURAL COURSE (TRAFFIC C) (3½") (PG 76-22, PMA)  
 AND FRICTION COURSE FC-5 (¾") (PG 76-22, PMA)

**SHOULDER PAVEMENT**


OPTIONAL BASE GROUP 1 WITH  
 TYPE SP STRUCTURAL COURSE (TRAFFIC C) (1½") (PG 76-22)  
 AND FRICTION COURSE FC-5 (¾") (PG 76-22)

**TRAFFIC DATA**

CURRENT YEAR = 2013 AADT = 12800  
 ESTIMATED OPENING YEAR = 2016 AADT = 16000  
 ESTIMATED DESIGN YEAR = 2037 AADT = 31900  
 $K = 9\%$   $D = 65.9\%$   $T = 7.09\%$  (24 HOUR)  
 DESIGN HOUR T = 3.55%  
 DESIGN SPEED = 65 MPH  
 POSTED SPEED = 55 MPH

**TYPICAL SECTION NOTES:**

1. Static Compaction Only.
2. At the contractor's option, unpaved shoulders may be constructed of base material.
3. Refer to Soil Mixing Plans for exact limits of Soil Mixing.
4. Refer to Shore Protection Plans for details on Shore Protection requirements.
5. Refer to Typical Section Details for grading above Soil Mixing Elements.
6. See Soil Mixing Plans for Stabilized Transition Zone details.
7. Refer to Typical Section Details, Summary of Quantities & Plan Sheets for guardrail placement locations.

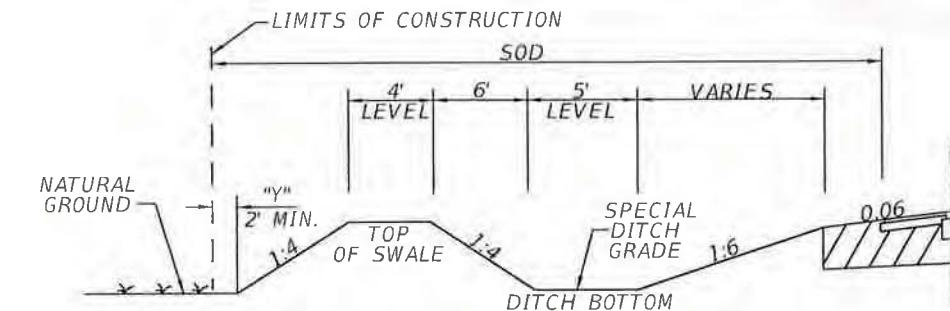

**SPECIAL DITCH DETAIL**  
 STA. 318+00.00 (LT) TO STA. 350+00.00 (LT)


REVISIONS				Parsons Brinckerhoff, Inc. 121 W. Trade Street, Suite 1950 Charlotte, NC 28202 (704) 342-8469 Cert. of Auth. No. 01462 EOR: Christopher D Davis, P.E. No. 63070	STATE OF FLORIDA DEPARTMENT OF TRANSPORTATION			SHEET NO.
DATE	DESCRIPTION	DATE	DESCRIPTION		ROAD NO.	COUNTY	FINANCIAL PROJECT ID	
					83	WALTON	220664-2-52-01	10

**TYPICAL SECTIONS (5)**



SCALE: 1" = 50' HORIZ.  
1" = 5' VERT.

e = 1-10.02

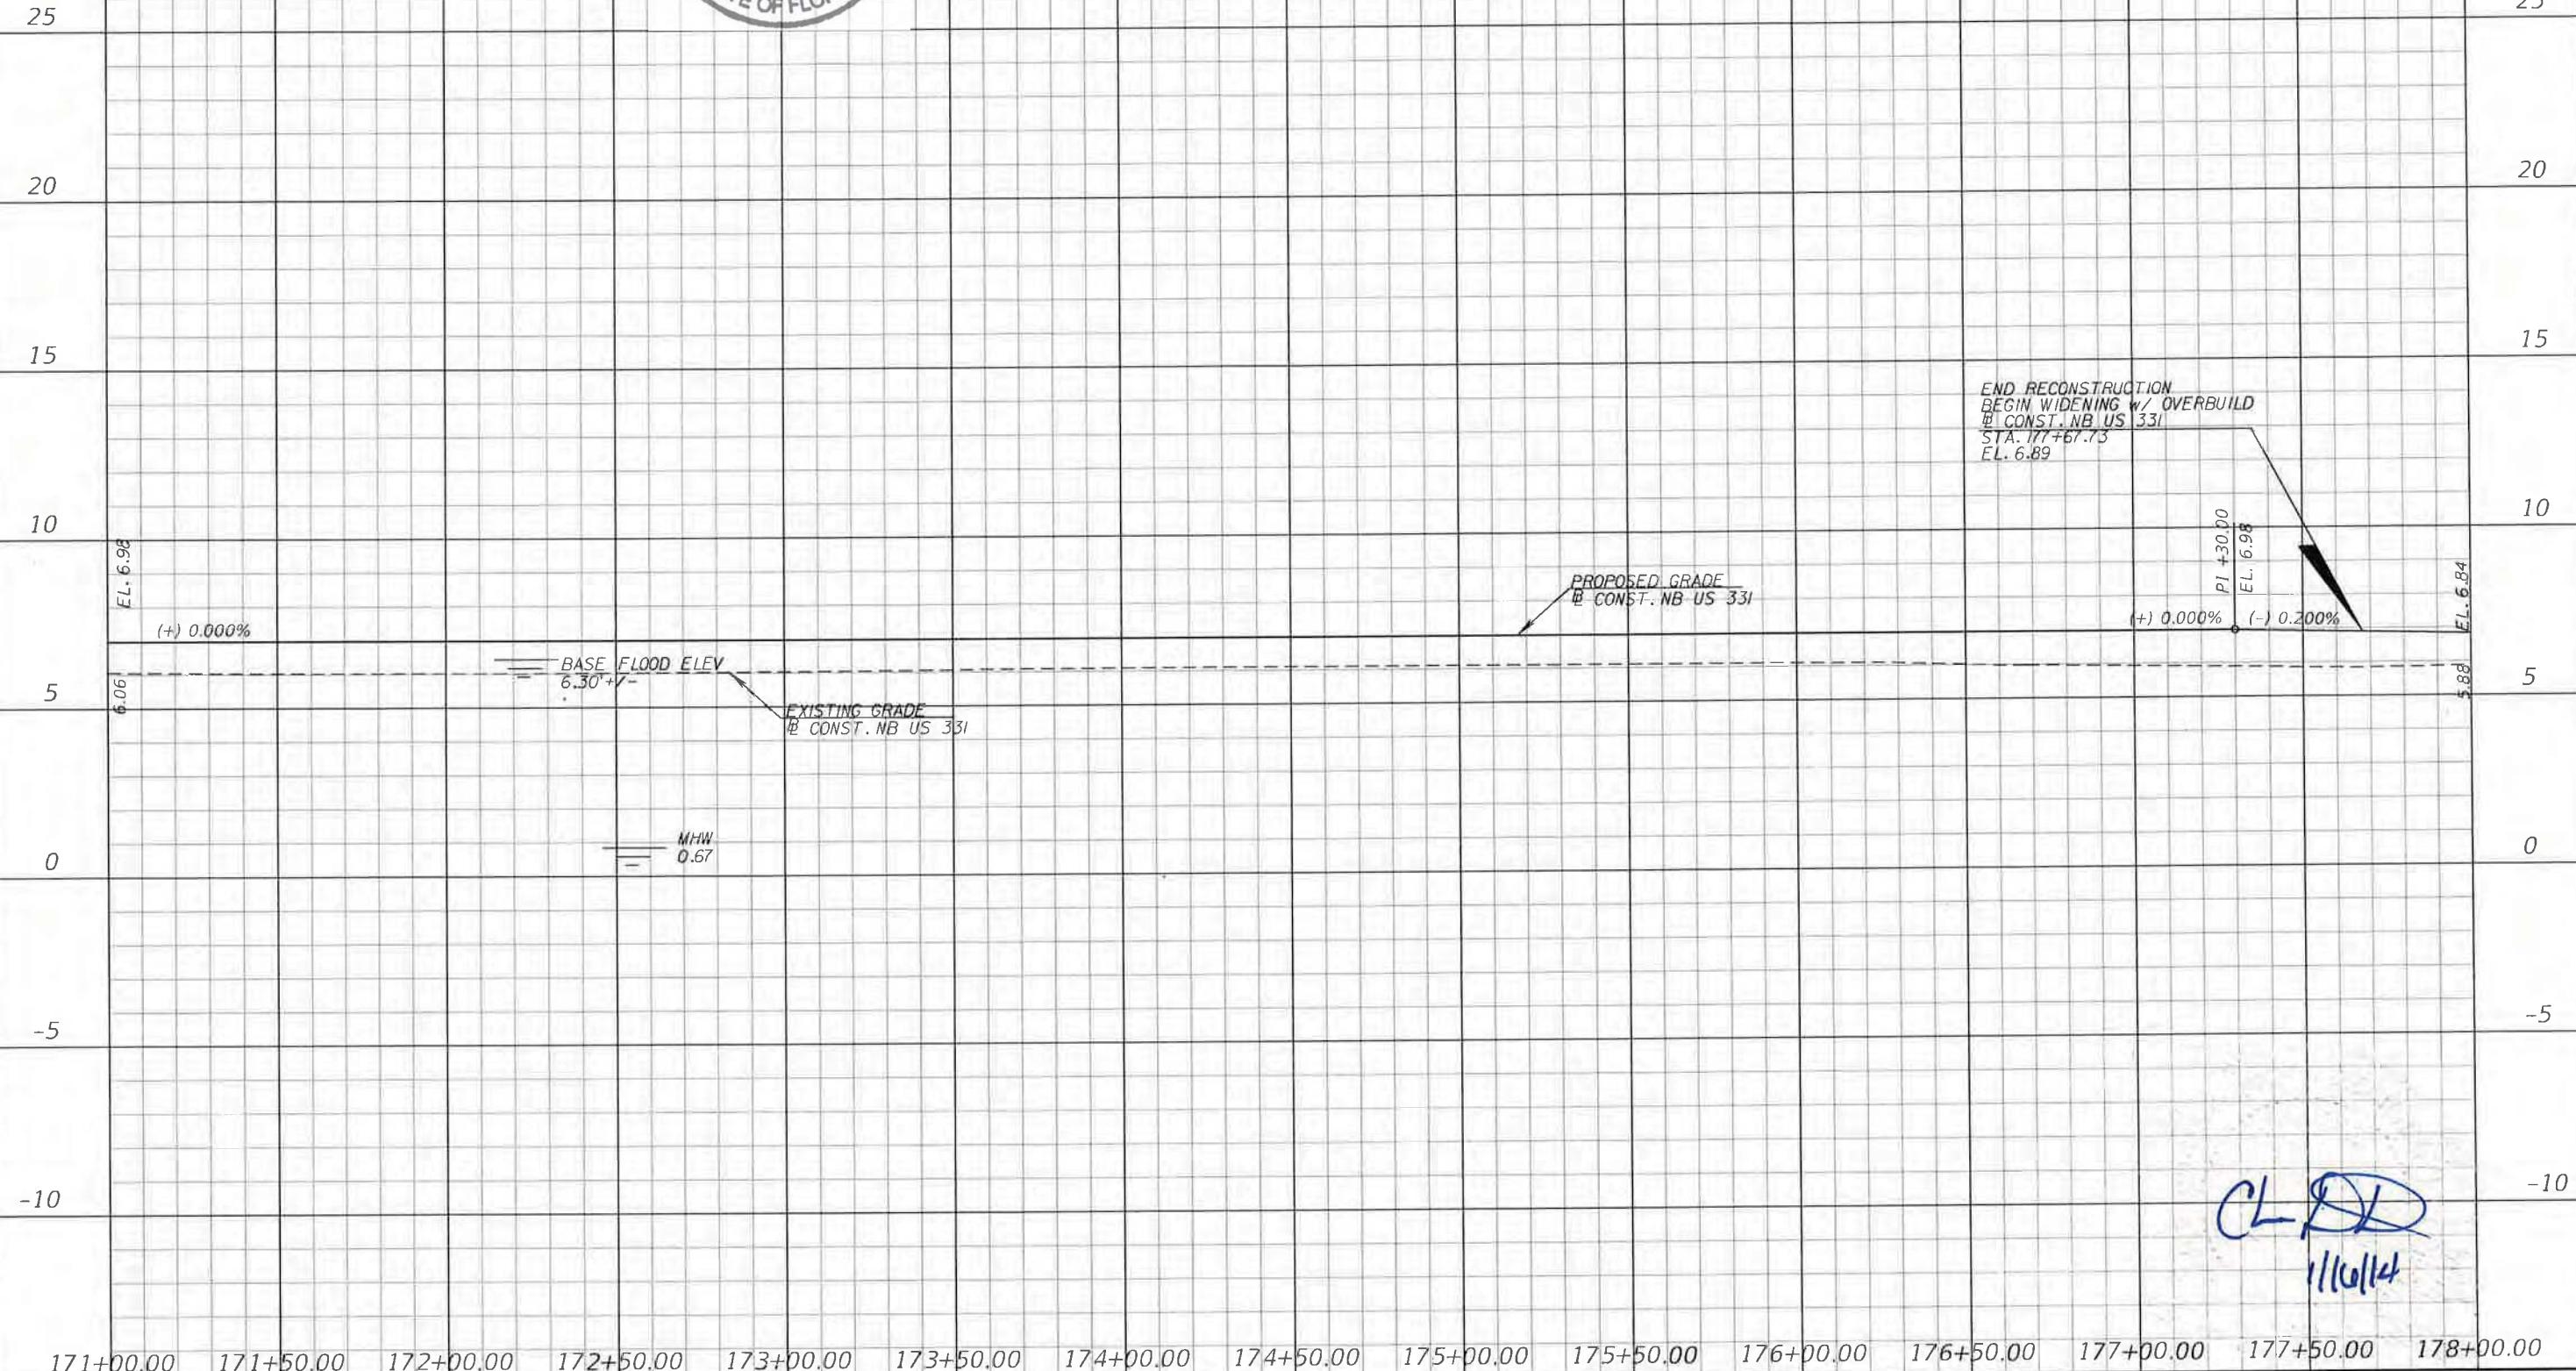

REVISIONS			
DATE	DESCRIPTION	DATE	DESCRIPTION

Parsons Brinckerhoff, Inc.  
121 W. Trade Street, Suite 1950  
Charlotte, NC 28202  
(704) 342-8469  
Cert. of Auth. No. 01462  
EOR: Christopher D Davis, P.E. No. 63070

STATE OF FLORIDA  
DEPARTMENT OF TRANSPORTATION  
ROAD NO. COUNTY FINANCIAL PROJECT ID  
83 WALTON 220664-2-52-01

PROFILE (24)  
NB US 331

SHEET NO.  
75

SCALE: 1" = 50' HORIZ.  
1" = 5' VERT.



e = (-10.039 LT  
e = (+10.039 RT

100' SE TRANSITION  
(0'-12' LT)  
e = (-10.039 TO (-10.02  
100' SE TRANSITION  
(0'-12' RT)  
e = (+10.039 TO (+10.02

e = (-10.02 LT  
e = (+10.02 RT

25

25

20

20

15

15

10

10

5

5

0

0

-5

-5

-10


-10

317+50.00 318+00.00 318+50.00 319+00.00 319+50.00 320+00.00 320+50.00 321+00.00 321+50.00 322+00.00 322+50.00 323+00.00 323+50.00 324+00.00 324+50.00

REVISIONS

DATE	DESCRIPTION	DATE	DESCRIPTION	Parsons Brinckerhoff, Inc. 121 W. Trade Street, Suite 1950 Charlotte, NC 28202 (704) 342-8469 Cert. of Auth. No. 01462 EOR: Christopher D Davis, P.E. No. 63070	STATE OF FLORIDA DEPARTMENT OF TRANSPORTATION			PROFILE (33) SB US 331
ROAD NO.	COUNTY	FINANCIAL PROJECT ID						
83	WALTON	220664-2-52-01						
davisch								
1/16/2014	1:40:36 PM	T:\projects\DD3_Chattawhatchee_Bridge_DB\roadway\PROFRD33.dgn						


CD  
1/16/14

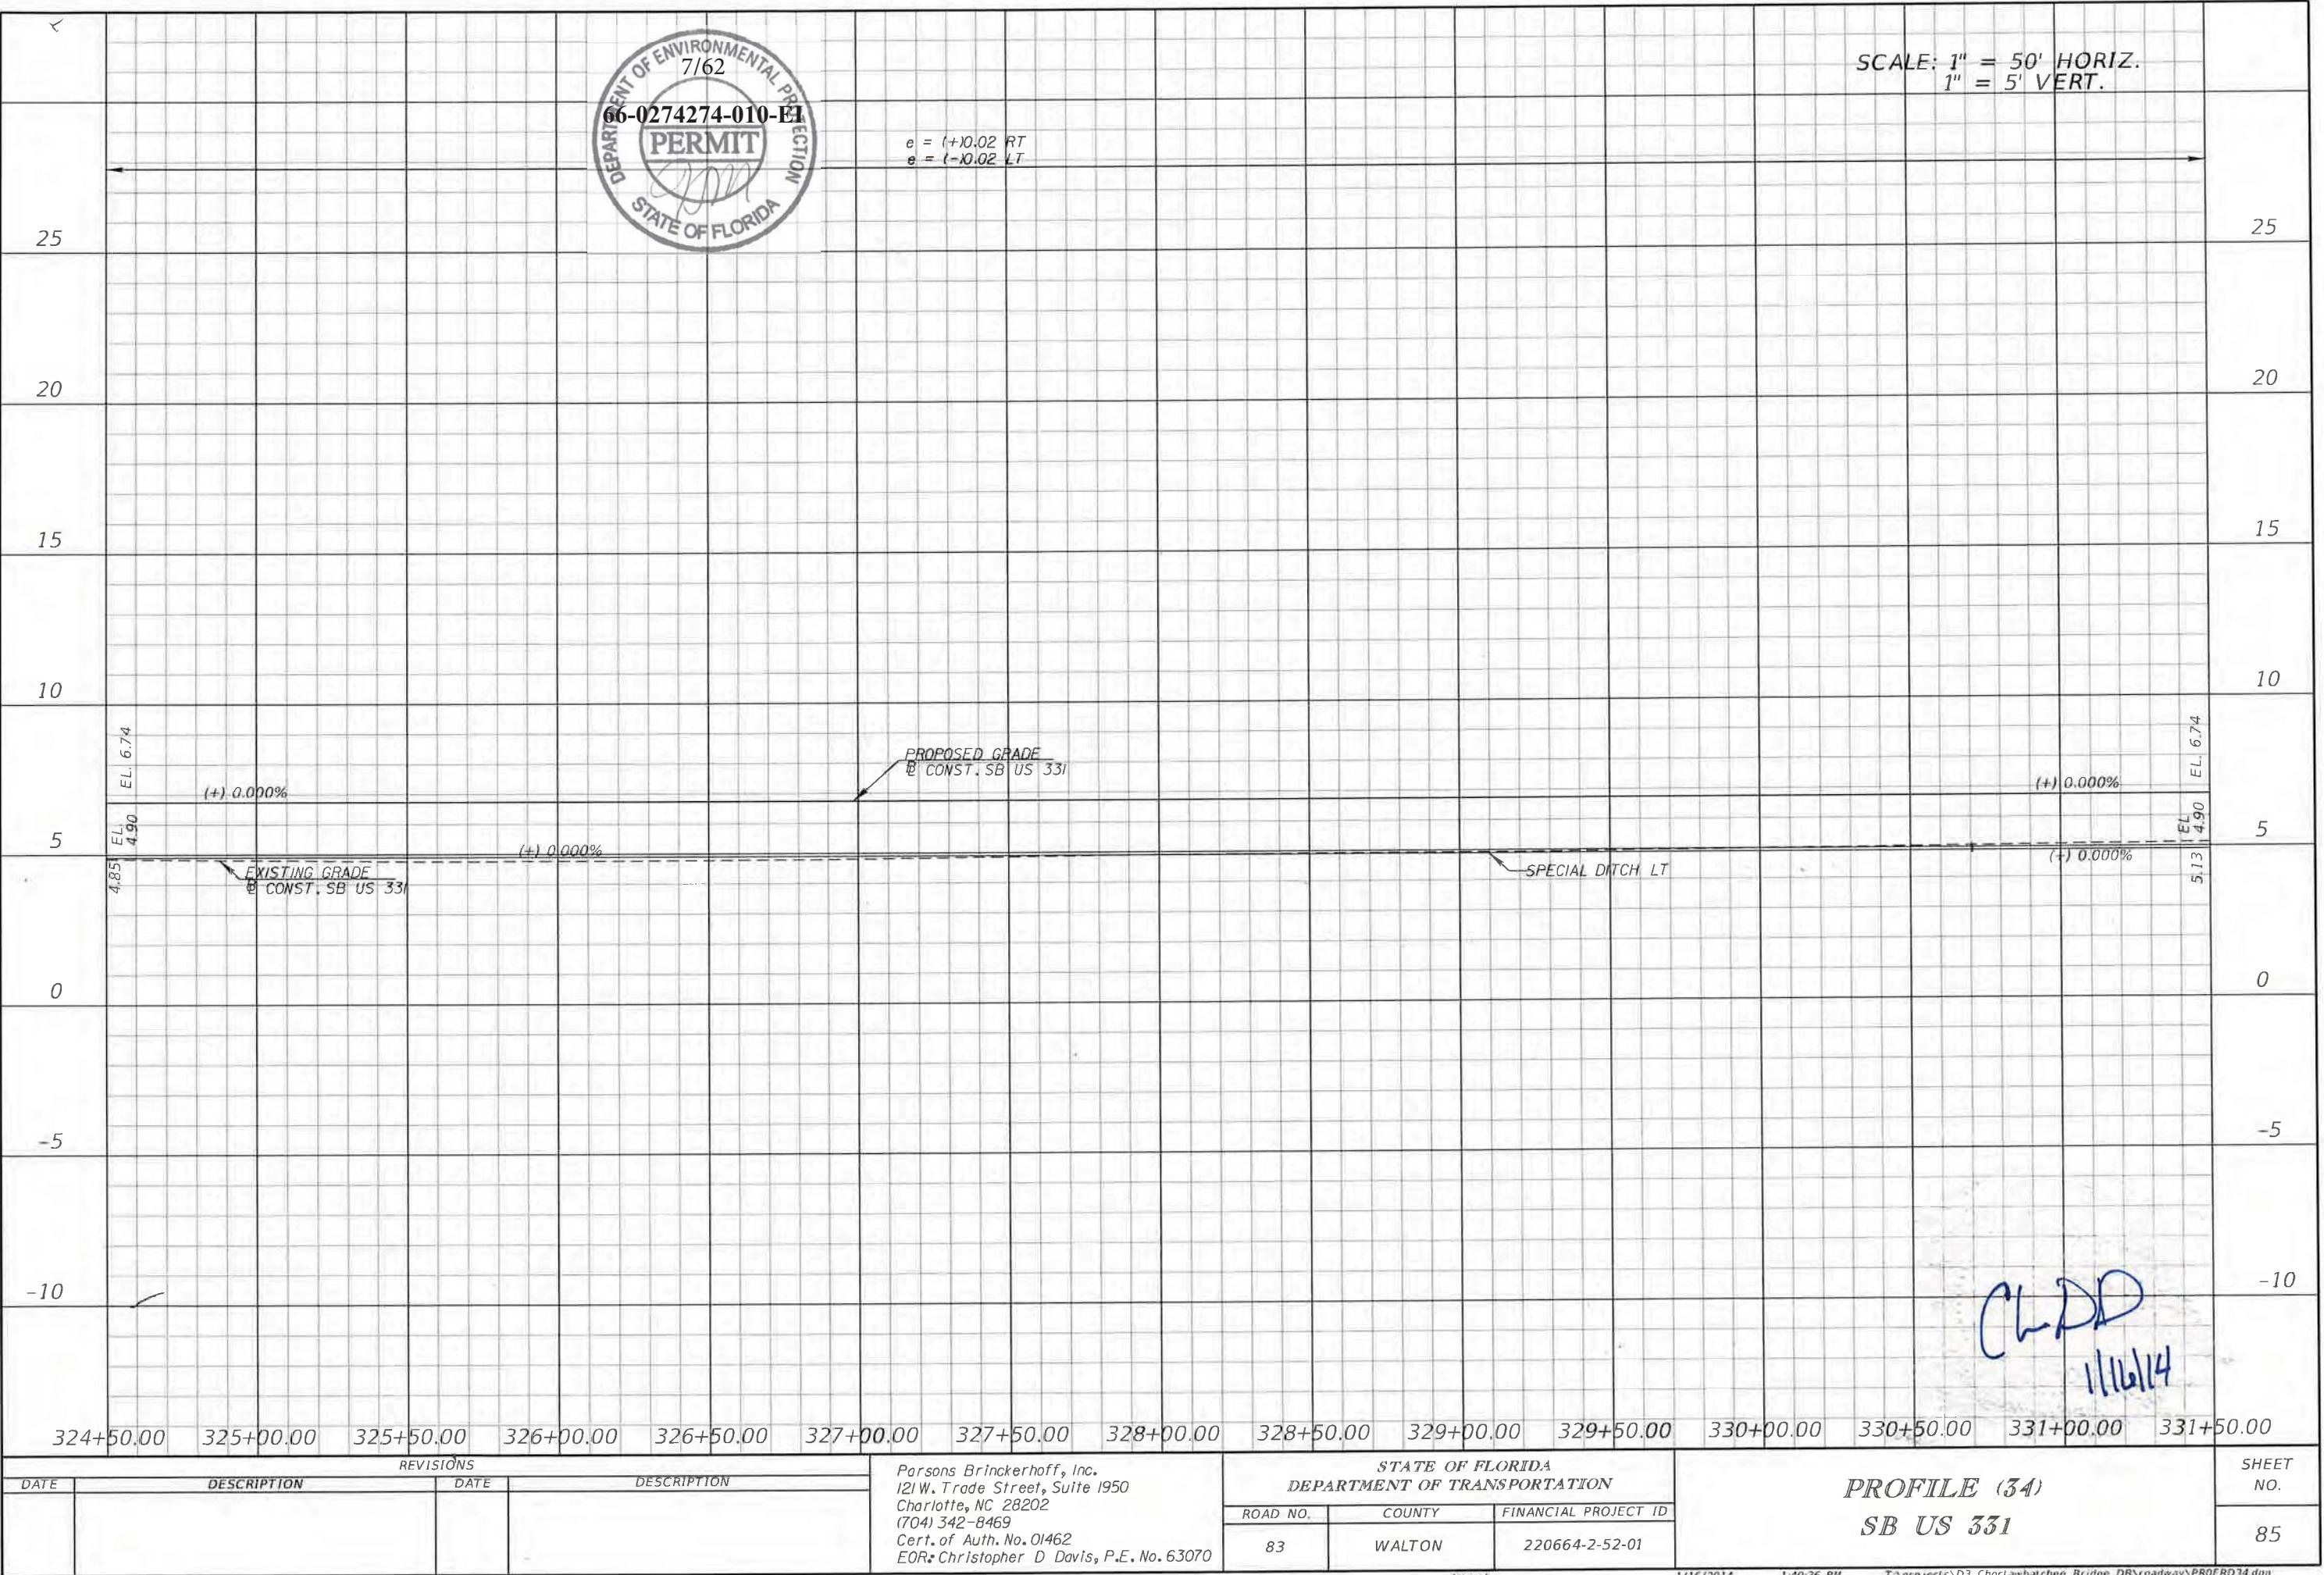



e = (+)0.02 RT  
e = (-)0.02 LT

SCALE: 1" = 50' HORIZ.  
1" = 5' VERT.

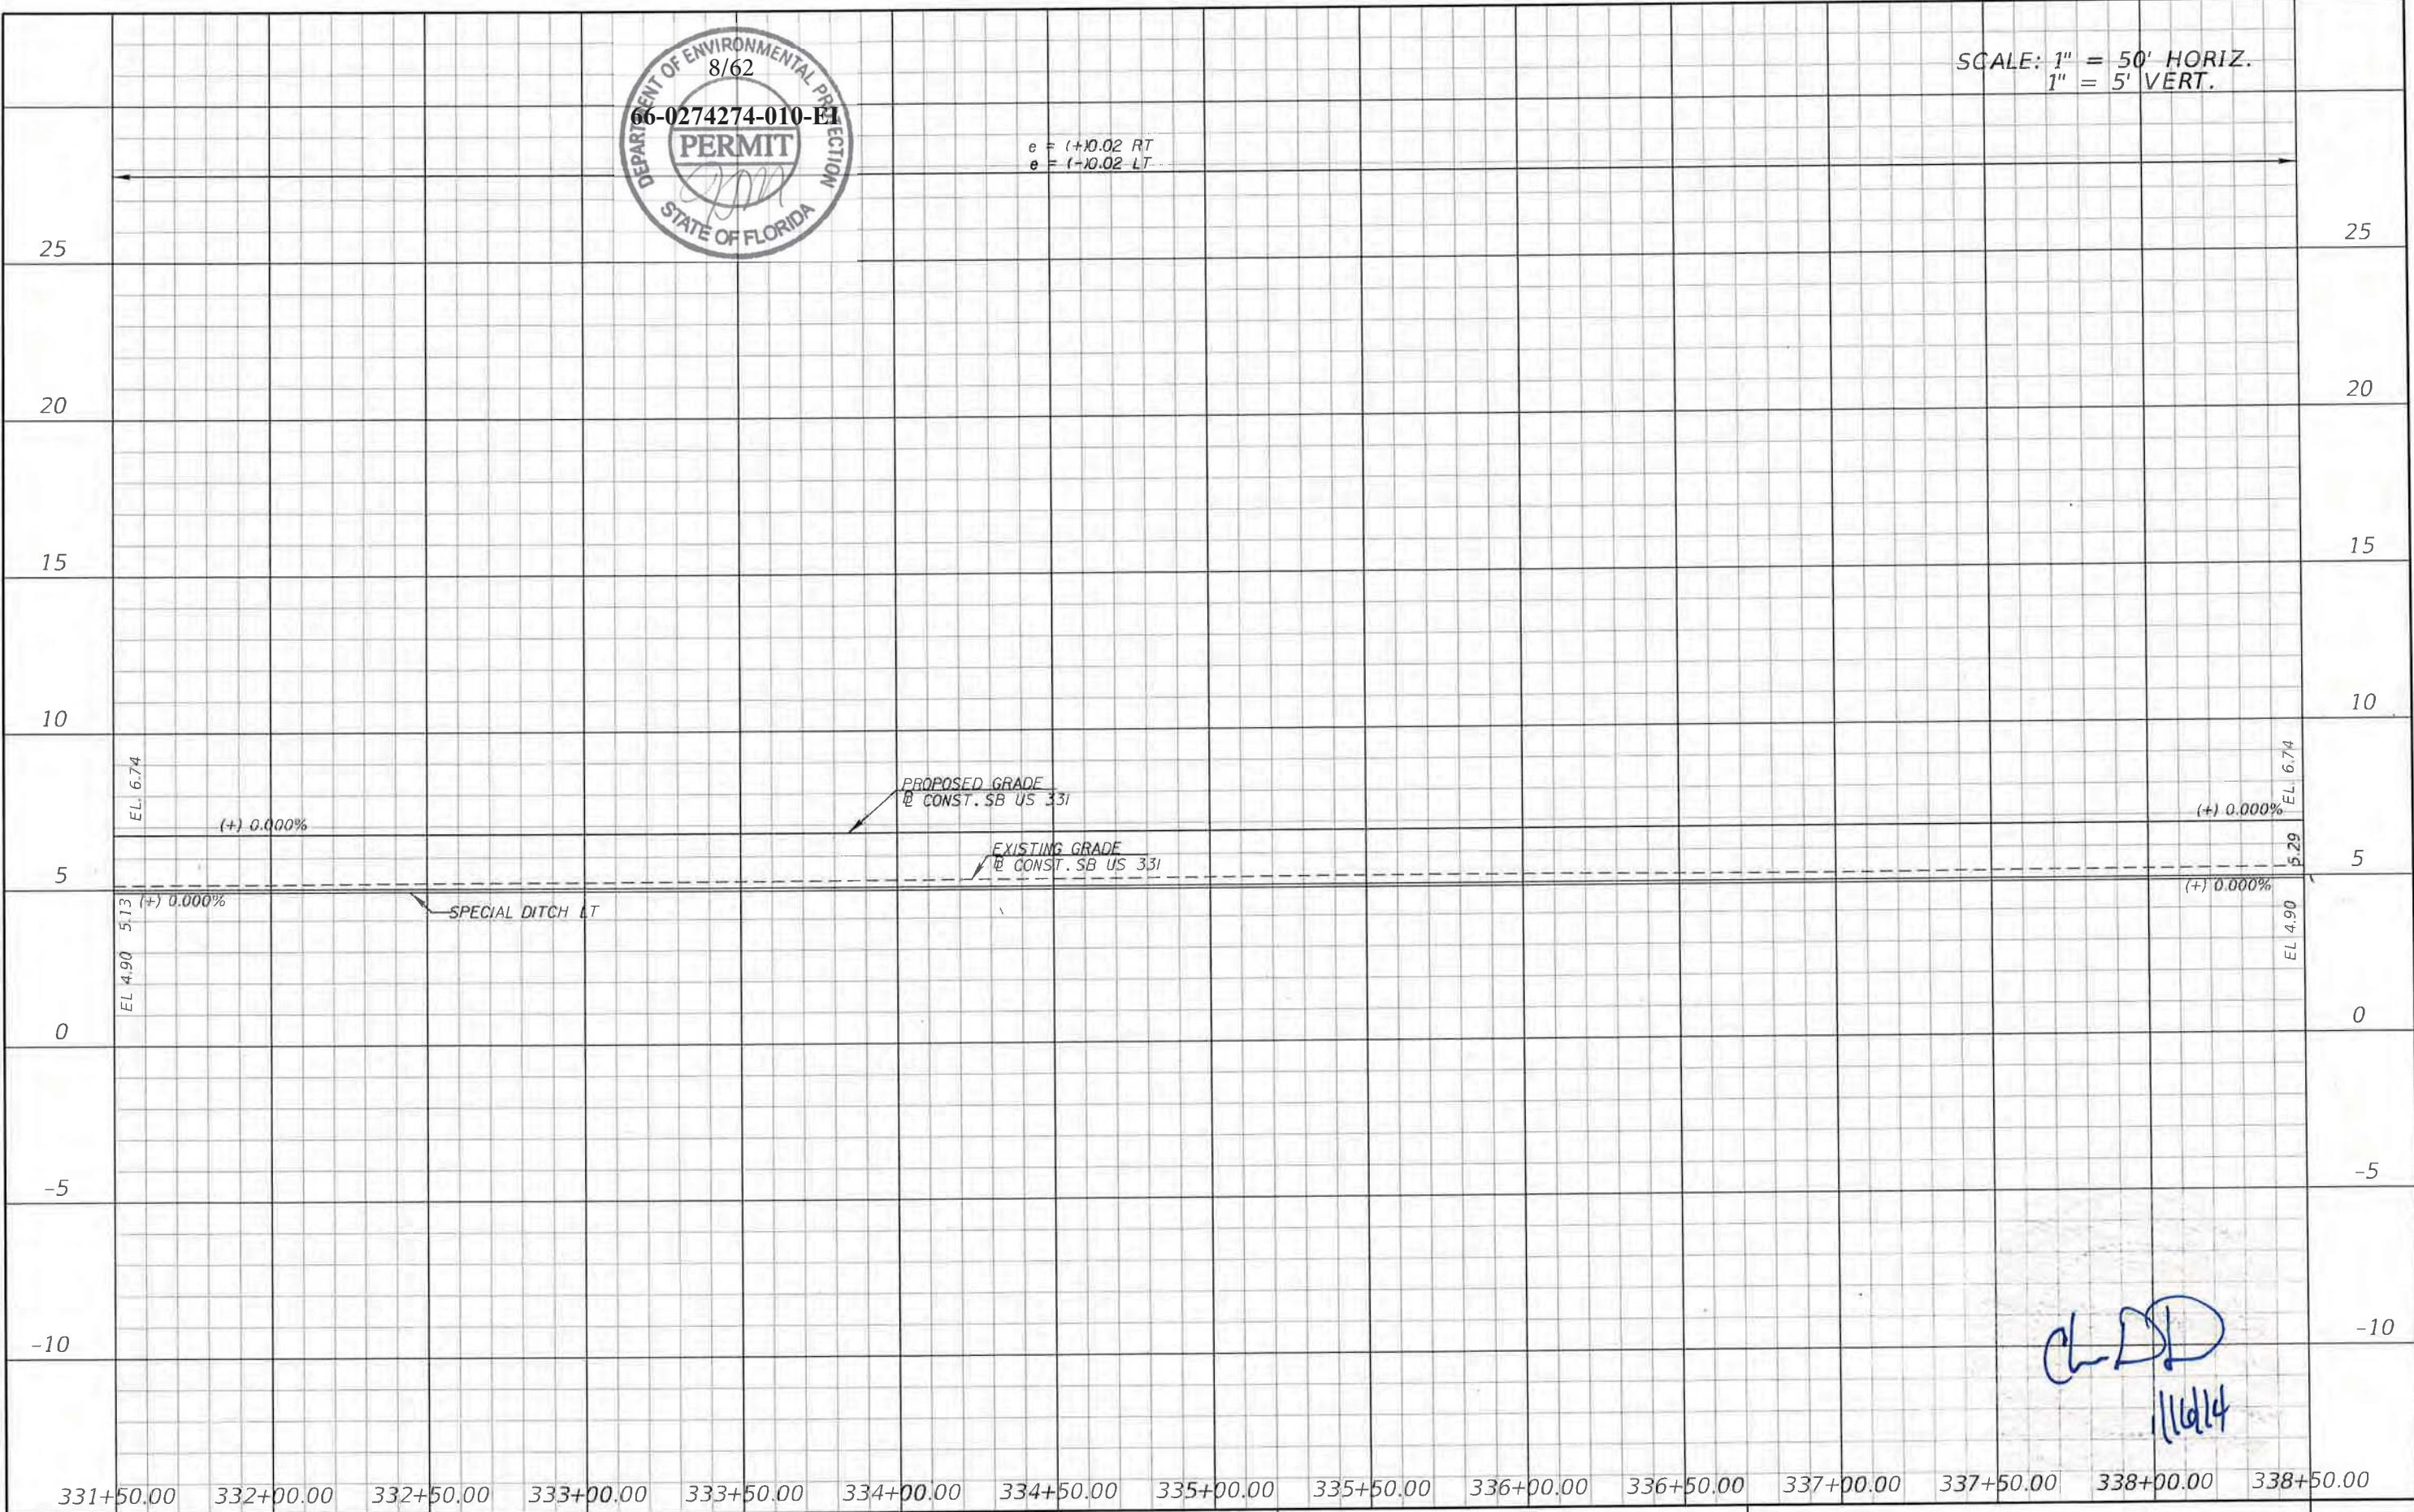

REVISIONS			
DATE	DESCRIPTION	DATE	DESCRIPTION

Parsons Brinckerhoff, Inc.  
121 W. Trade Street, Suite 1950  
Charlotte, NC 28202  
(704) 342-8469  
Cert. of Auth. No. 01462  
EOR: Christopher D Davis, P.E. No. 63070

STATE OF FLORIDA  
DEPARTMENT OF TRANSPORTATION  
ROAD NO. COUNTY FINANCIAL PROJECT ID  
83 WALTON 220664-2-52-01

PROFILE (35)  
SB US 331

SHEET NO.  
86

SCALE: 1" = 50' HORIZ.  
1" = 5' VERT.



e = (+)0.02 RT  
e = (-)0.02 LT

25

25

20

20

15

15

10

10

5.29 EL. 6.74  
(+/-) 0.000%

PROPOSED GRADE  
# CONST. SB US 331

5.35 EL. 6.74  
(+/-) 0.000%

EXISTING GRADE  
# CONST. SB US 331

(+/-) 0.000%

(+/-) 0.000% ← SPECIAL DITCH LT

5.35 EL. 6.74  
(+/-) 0.000%

5

5

0

0

-5

-5

-10

-10

338+50.00 339+00.00 339+50.00 340+00.00 340+50.00 341+00.00 341+50.00 342+00.00 342+50.00 343+00.00 343+50.00 344+00.00 344+50.00 345+00.00 345+00.00

Ch DD  
1/16/14

REVISIONS

DATE	DESCRIPTION	DATE	DESCRIPTION

Parsons Brinckerhoff, Inc.  
121 W. Trade Street, Suite 1950  
Charlotte, NC 28202  
(704) 342-8469  
Cert. of Auth. No. 01462  
EOR: Christopher D Davis, P.E. No. 63070

STATE OF FLORIDA


DEPARTMENT OF TRANSPORTATION

ROAD NO.	COUNTY	FINANCIAL PROJECT ID
83	WALTON	220664-2-52-01

PROFILE (36)  
SB US 331

SHEET NO.

87

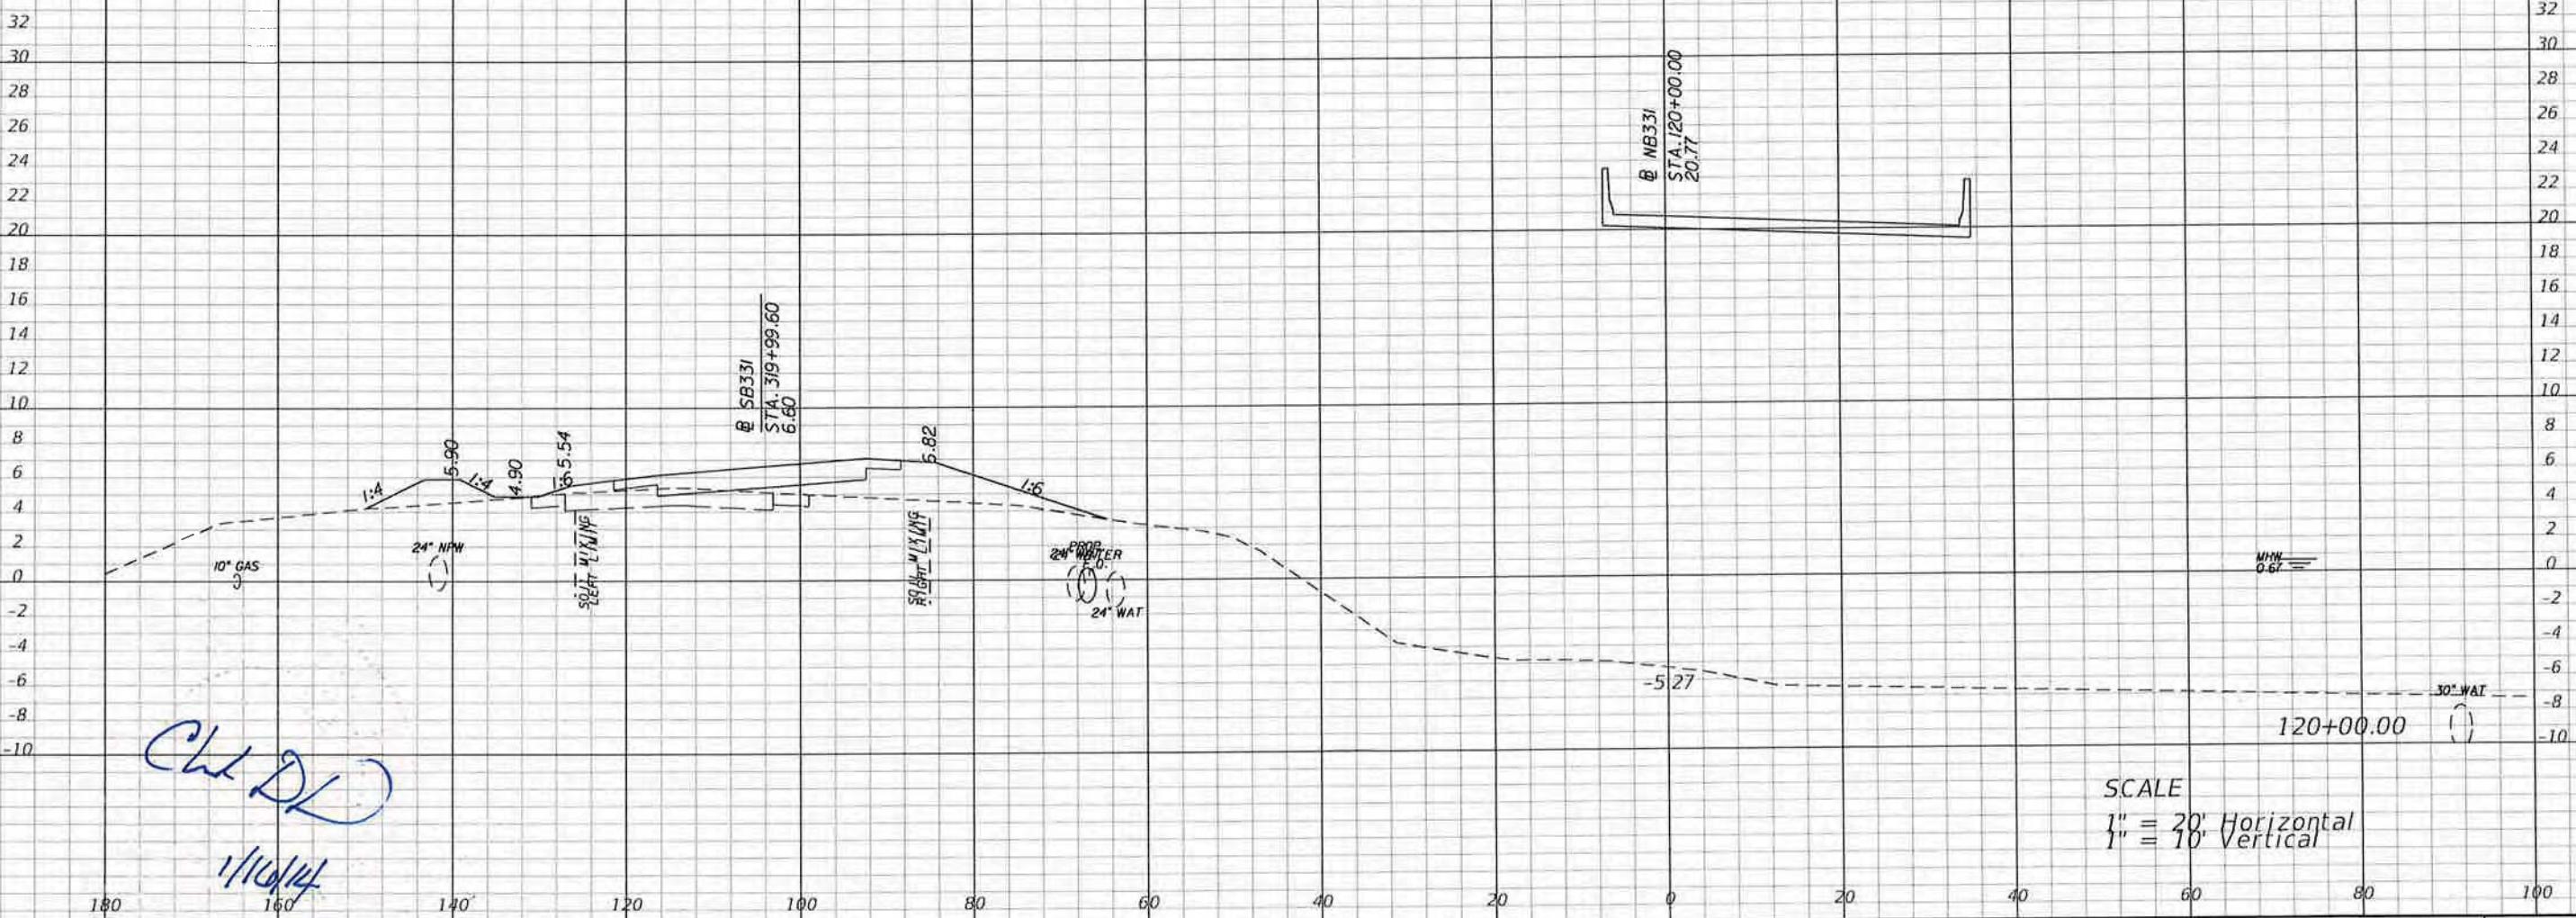


REVISIONS			
DATE	DESCRIPTION	DATE	DESCRIPTION

Parsons Brinckerhoff, Inc.  
121 W. Trade Street, Suite 1950  
Charlotte, NC 28202  
(704) 342-8469  
Cert. of Auth. No. 01462  
EOR: Christopher D Davis, P.E. No. 63070


STATE OF FLORIDA  
DEPARTMENT OF TRANSPORTATION  
ROAD NO. COUNTY FINANCIAL PROJECT ID  
83 WALTON 220664-2-52-01

CROSS SECTIONS

SHEET NO.  
169

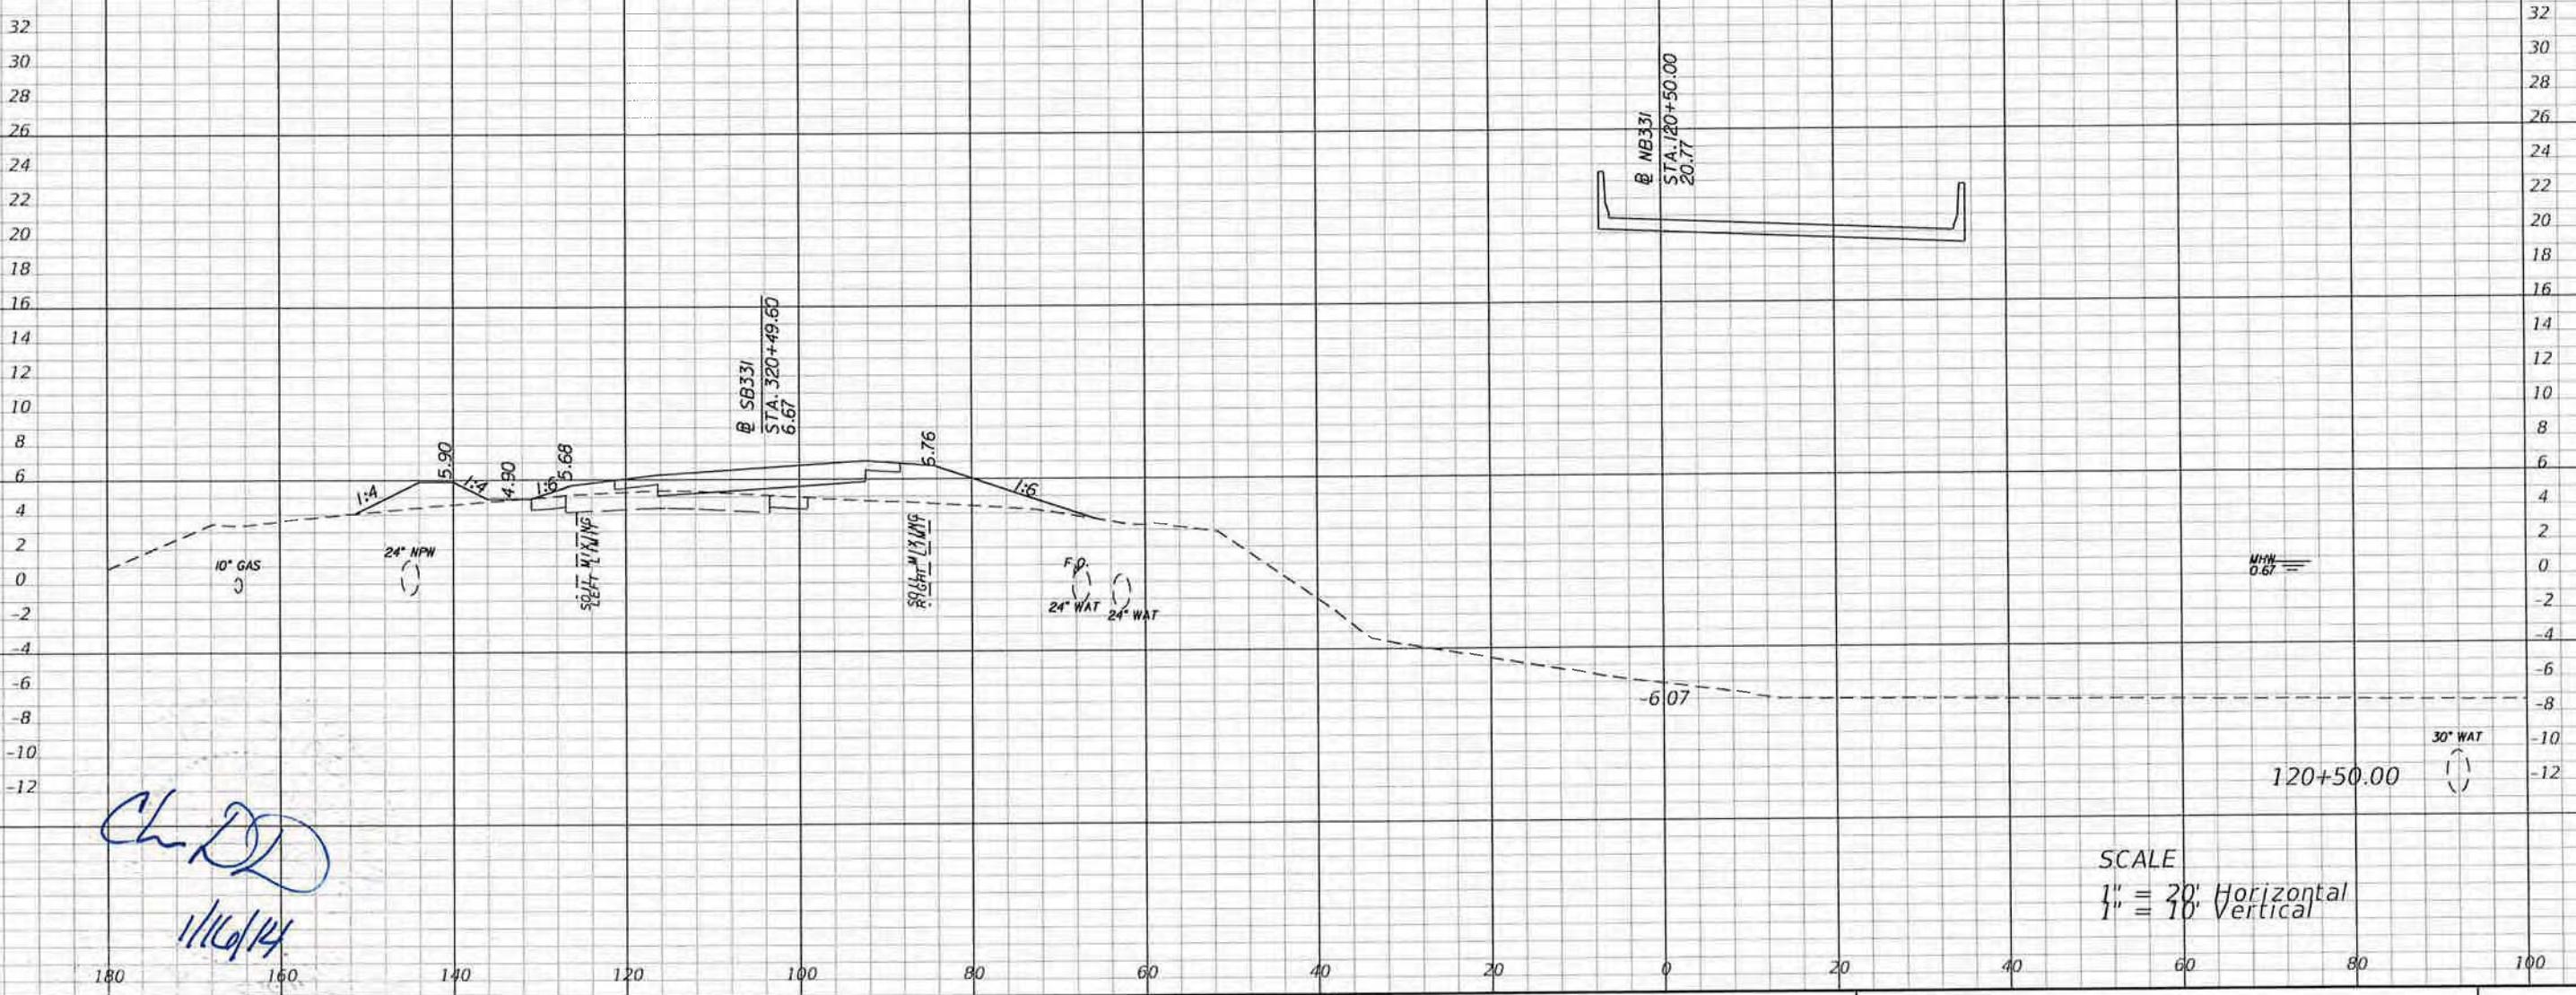

REVISIONS				Parsons Brinckerhoff, Inc. 121 W. Trade Street, Suite 1950 Charlotte, NC 28202 (704) 342-8469 Cert. of Auth. No. 01462 EOR: Christopher D Davis, P.E. No. 63070	STATE OF FLORIDA DEPARTMENT OF TRANSPORTATION			CROSS SECTIONS	SHEET NO.
DATE	DESCRIPTION	DATE	DESCRIPTION		ROAD NO.	COUNTY	FINANCIAL PROJECT ID		170
					83	WALTON	220664-2-52-01		davisch

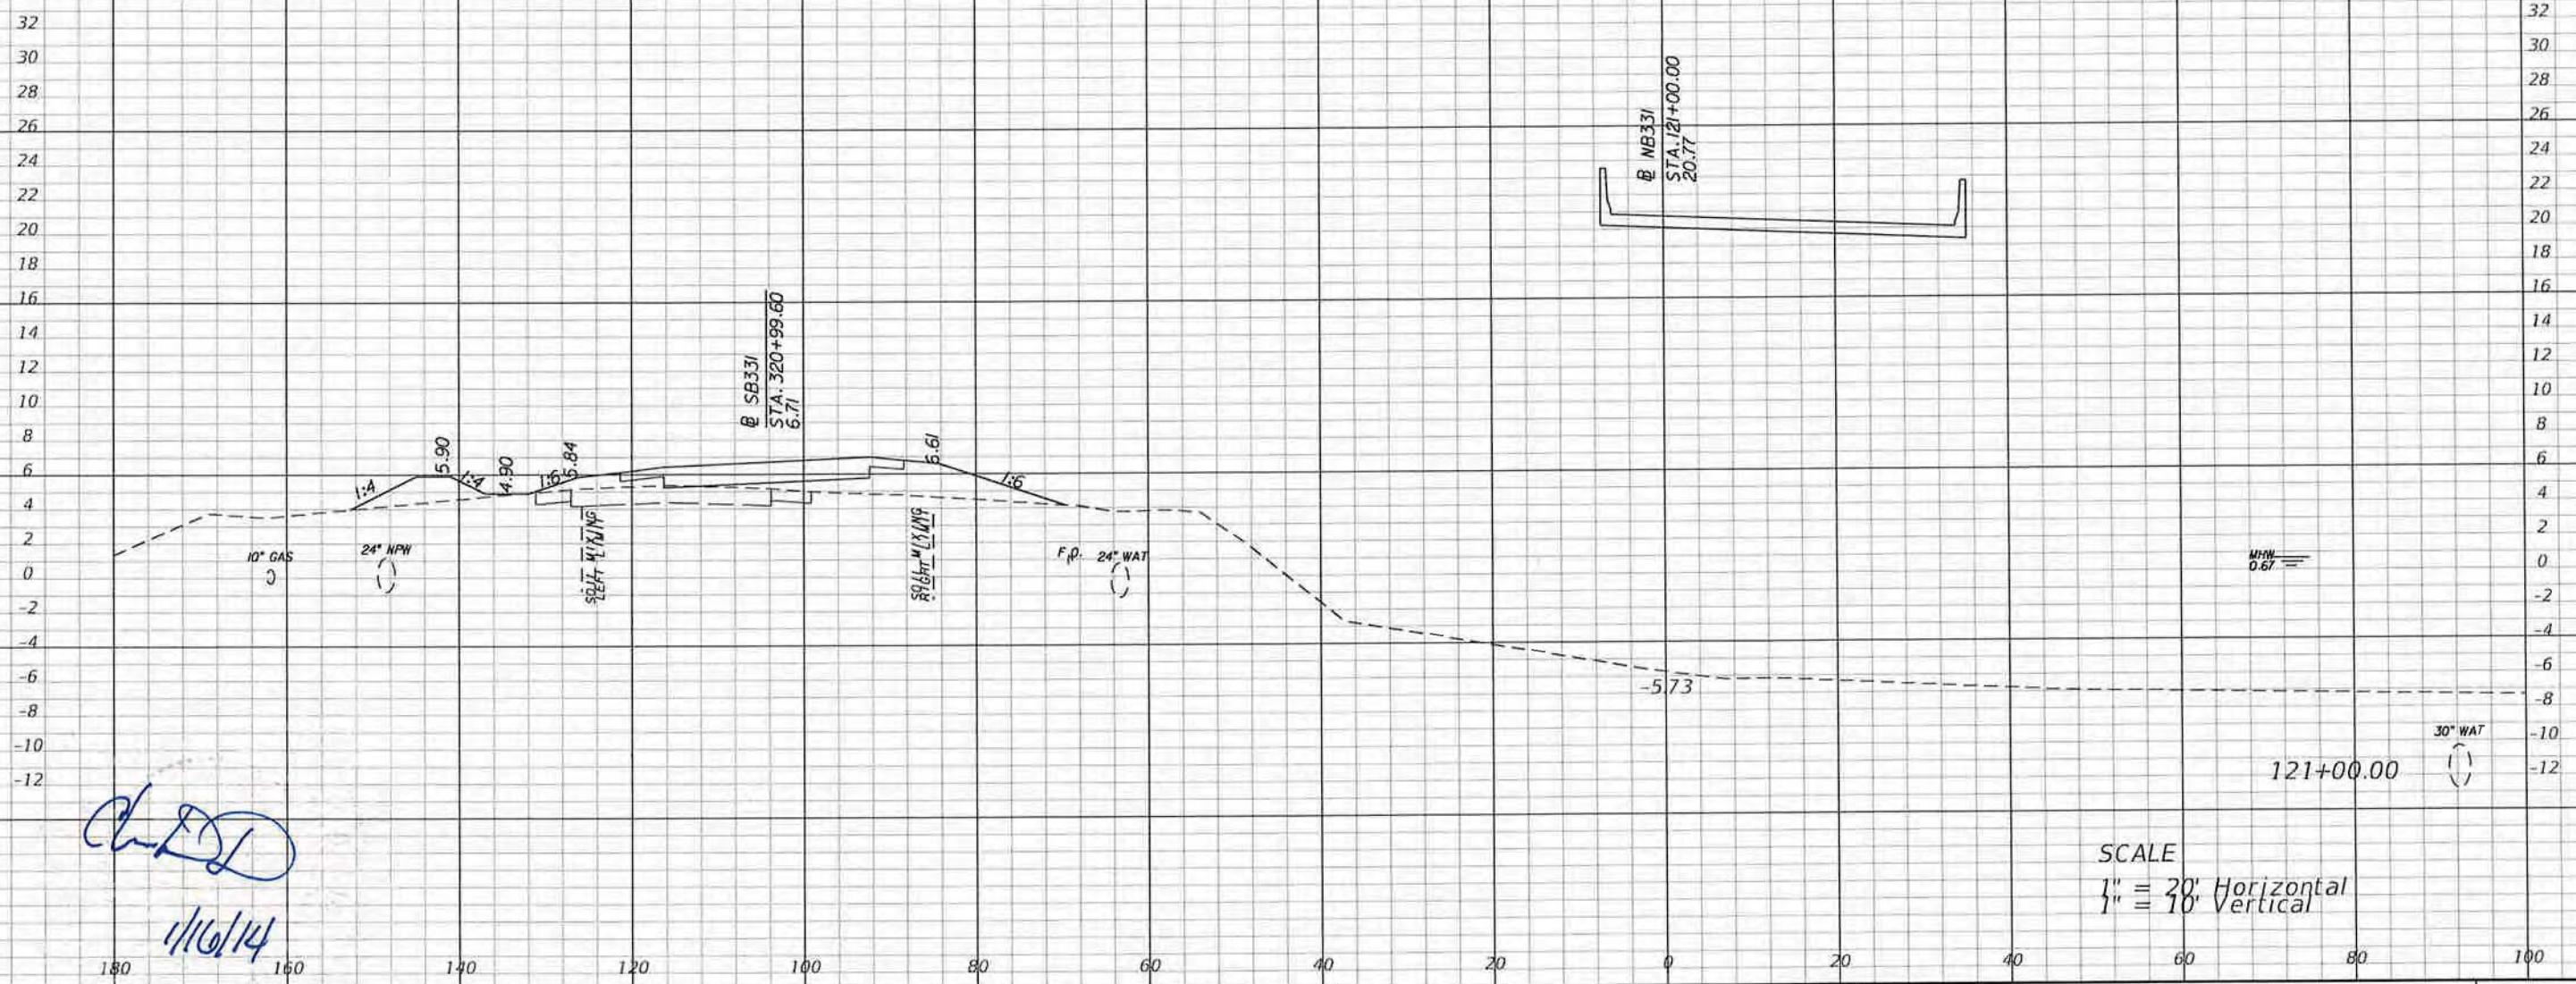


REVISIONS			
DATE	DESCRIPTION	DATE	DESCRIPTION

Parsons Brinckerhoff, Inc.  
121 W. Trade Street, Suite 1950  
Charlotte, NC 28202  
(704) 342-8469  
Cert. of Auth. No. 01462  
EOR: Christopher D Davis, P.E. No. 63070

STATE OF FLORIDA  
DEPARTMENT OF TRANSPORTATION  
ROAD NO.      COUNTY      FINANCIAL PROJECT ID  
83      WALTON      220664-2-52-01

### CROSS SECTIONS

SHEET NO.  
171

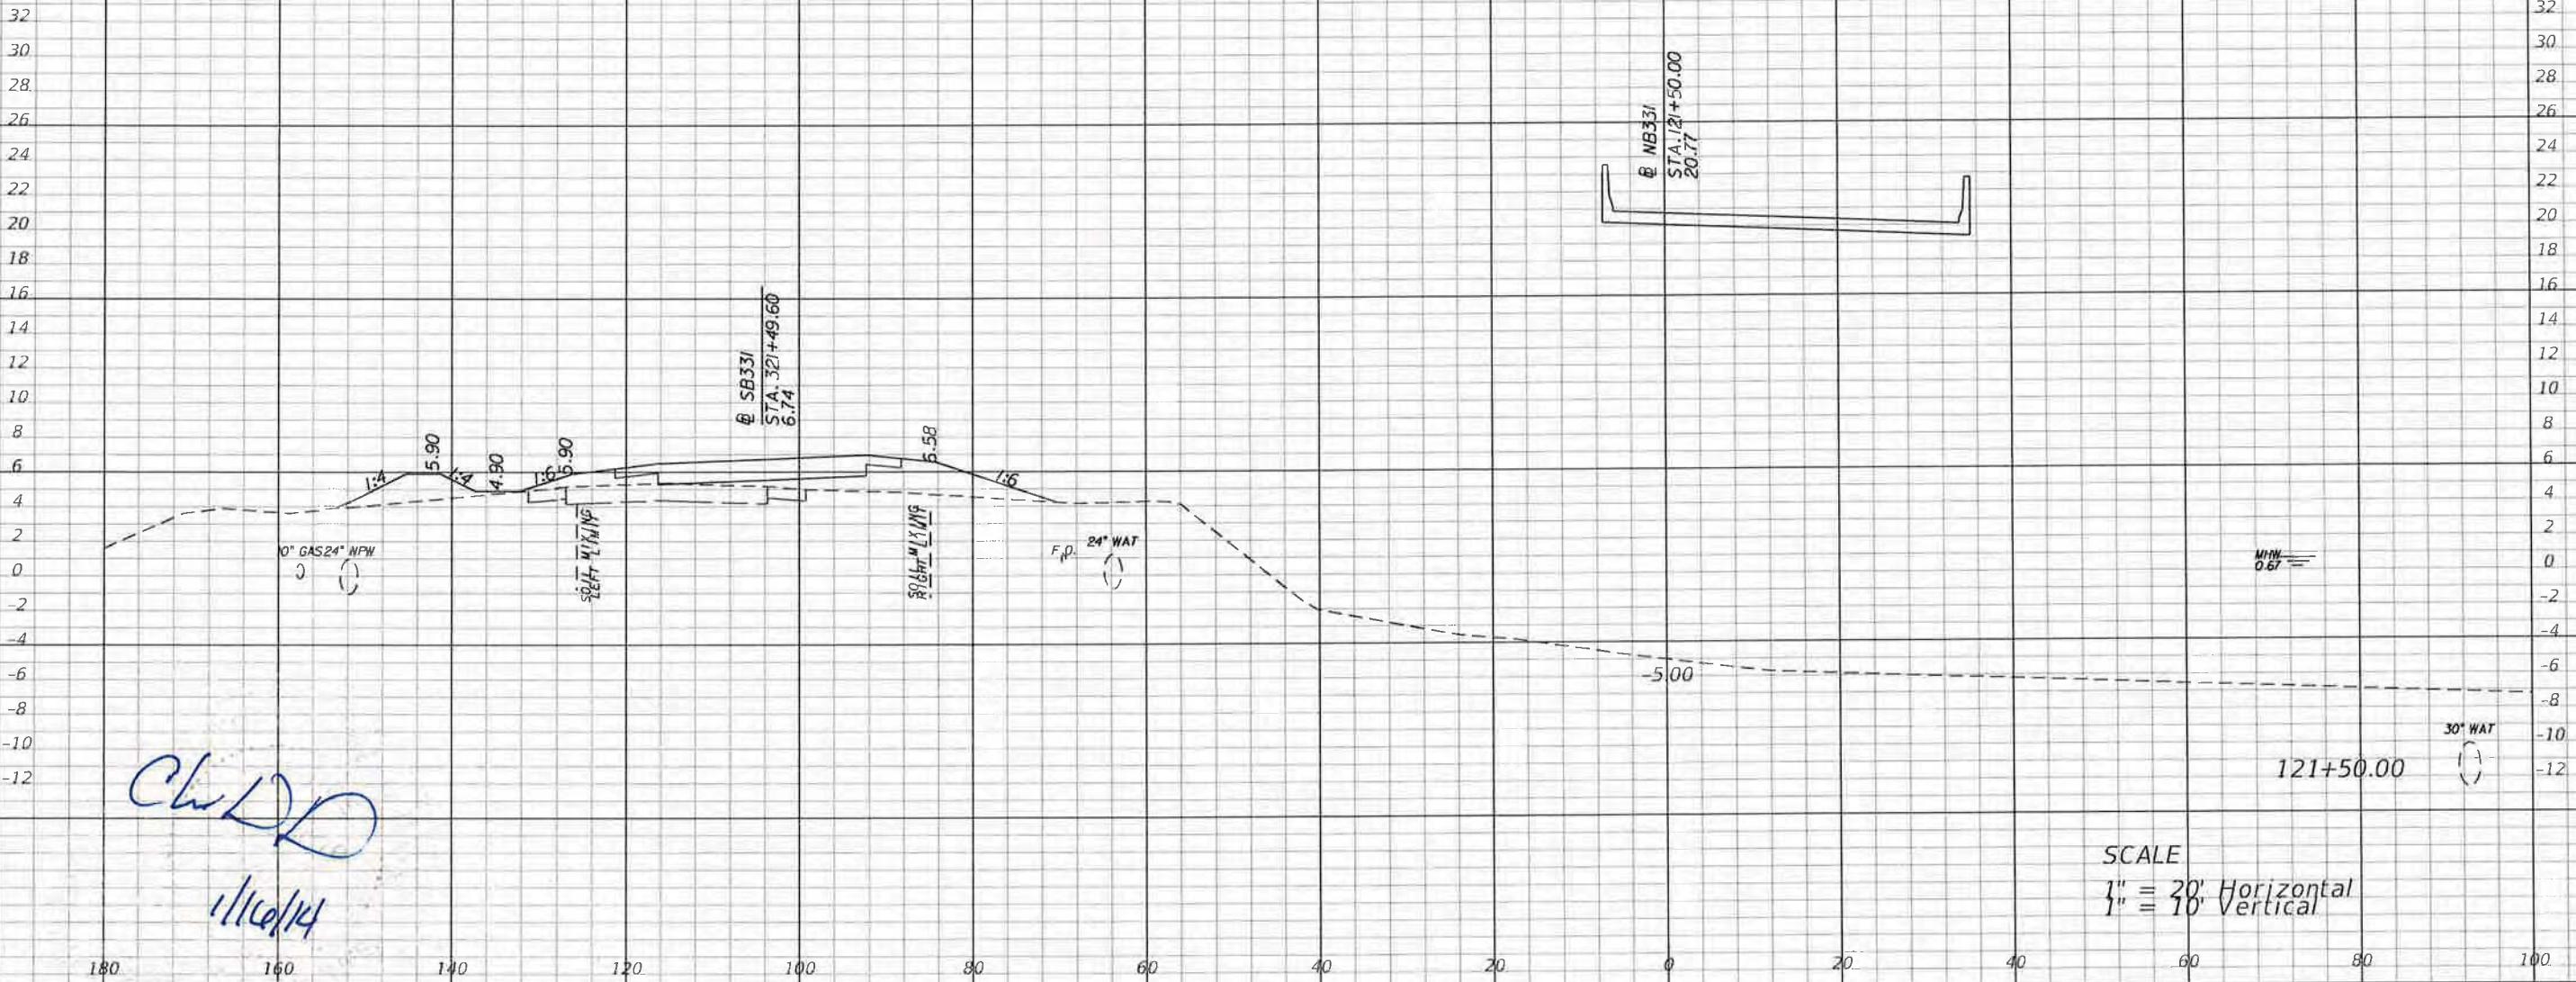


REVISIONS			
DATE	DESCRIPTION	DATE	DESCRIPTION

Parsons Brinckerhoff, Inc.  
121 W. Trade Street, Suite 1950  
Charlotte, NC 28202  
(704) 342-8469  
Cert. of Auth. No. 01462  
EOR: Christopher D Davis, P.E. No. 63070

STATE OF FLORIDA  
DEPARTMENT OF TRANSPORTATION  
ROAD NO. COUNTY FINANCIAL PROJECT ID  
83 WALTON 220664-2-52-01

### CROSS SECTIONS

SHEET NO.  
172

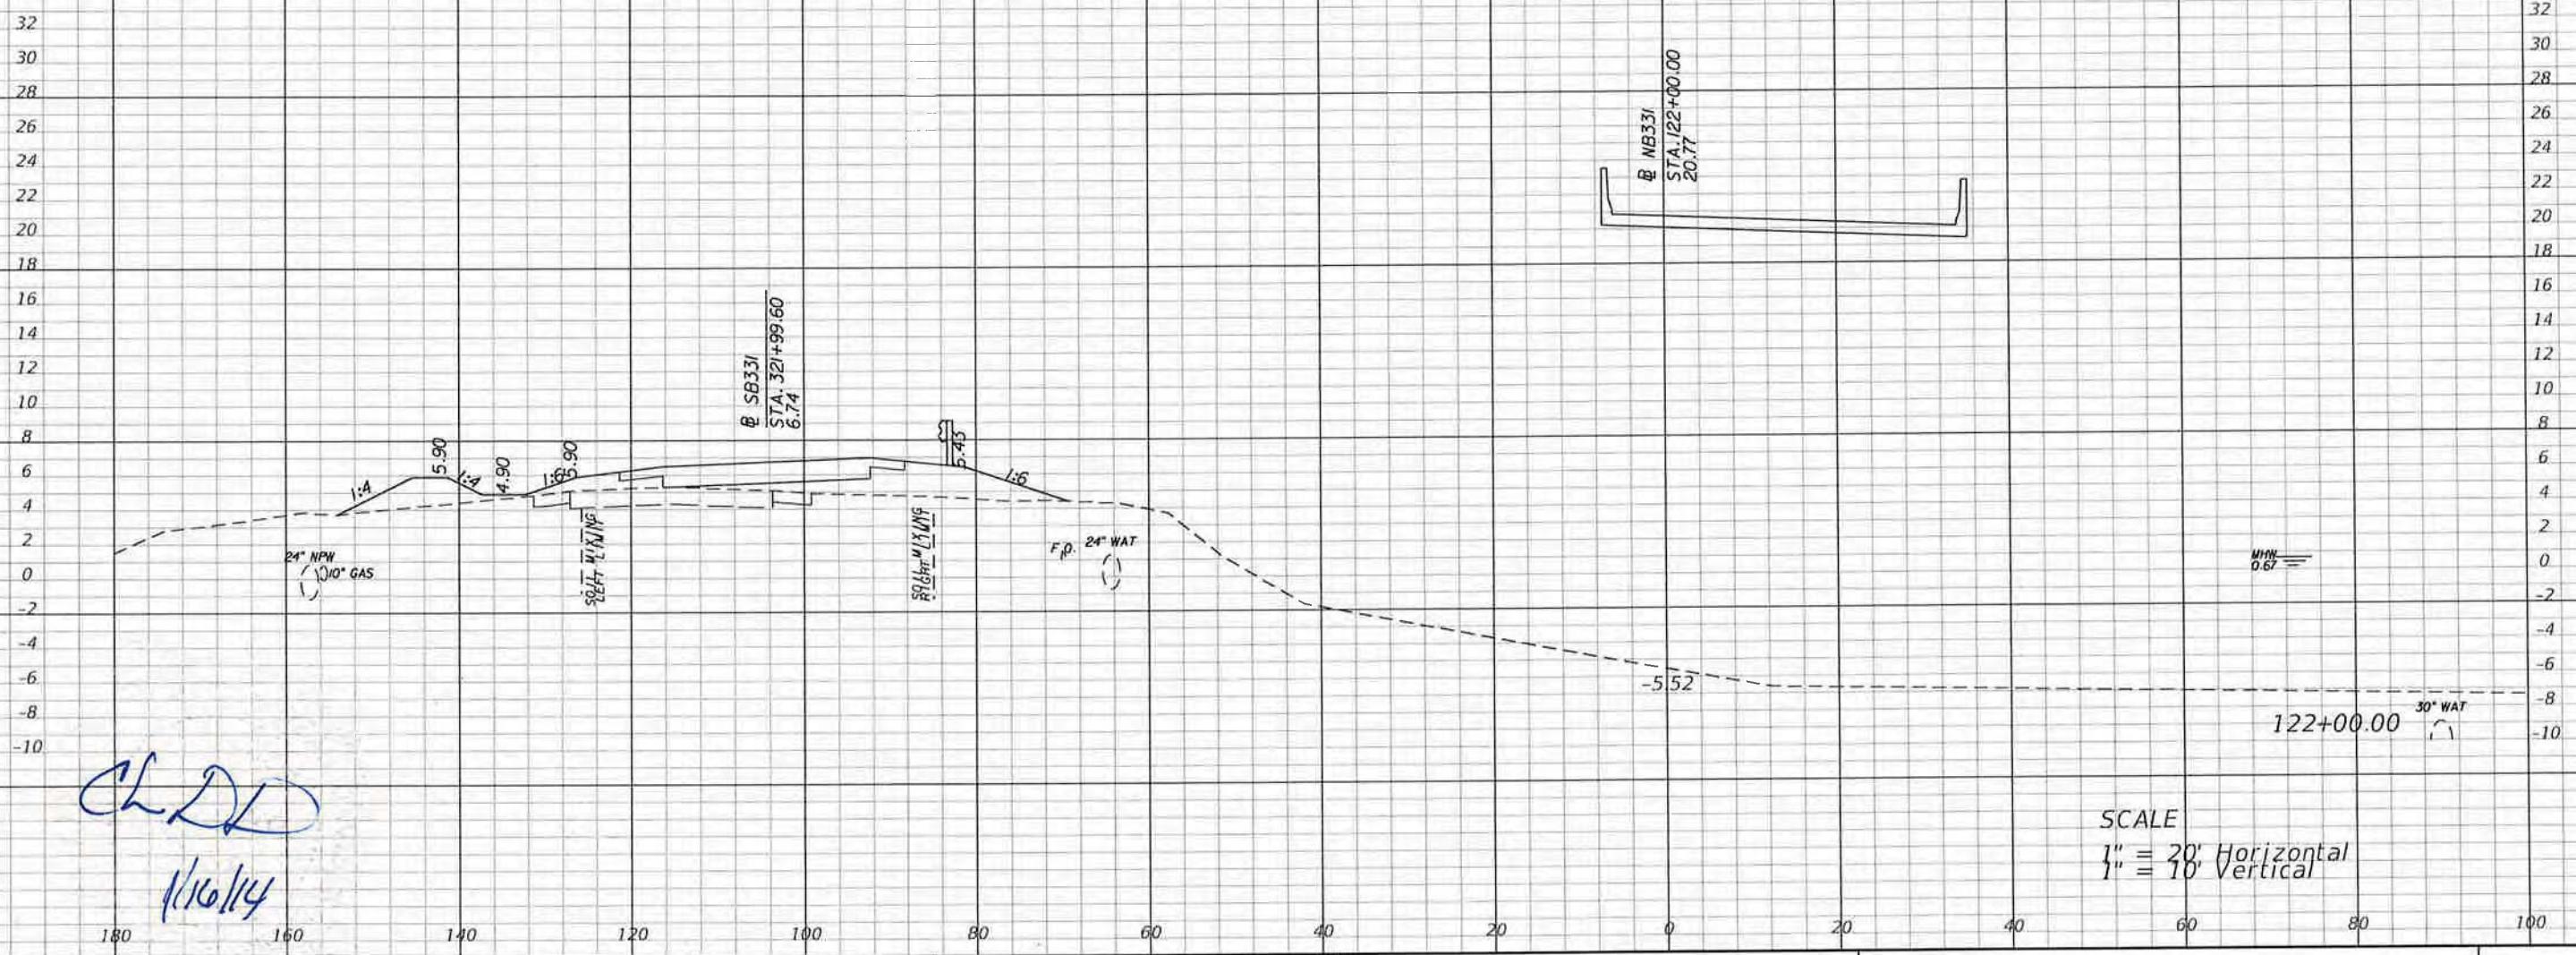

REVISIONS			
DATE	DESCRIPTION	DATE	DESCRIPTION


Parsons Brinckerhoff, Inc.  
121 W. Trade Street, Suite 1950  
Charlotte, NC 28202  
(704) 342-8469  
Cert. of Auth. No. 01462  
EOR: Christopher D Davis, P.E. No. 63070

STATE OF FLORIDA  
DEPARTMENT OF TRANSPORTATION

ROAD NO.	COUNTY	FINANCIAL PROJECT ID
83	WALTON	220664-2-52-01

### CROSS SECTIONS



SHEET NO.  
173

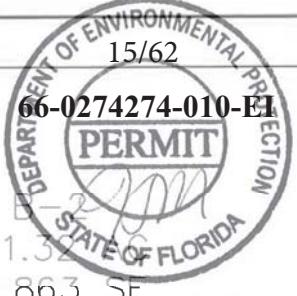

66-0274274-010-EL

BASIN  
STATE OF FLORIDA  
AREA 1.32 AC  
OR 58,863 SF

BASIN B-1  
AREA 1.34 AC  
OR 58,657 SF

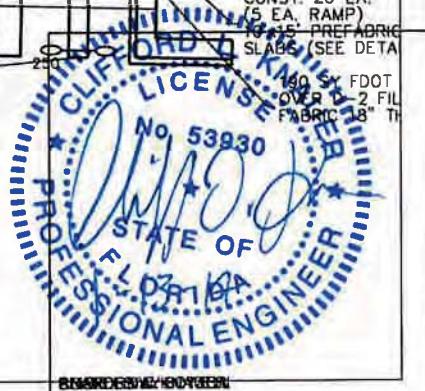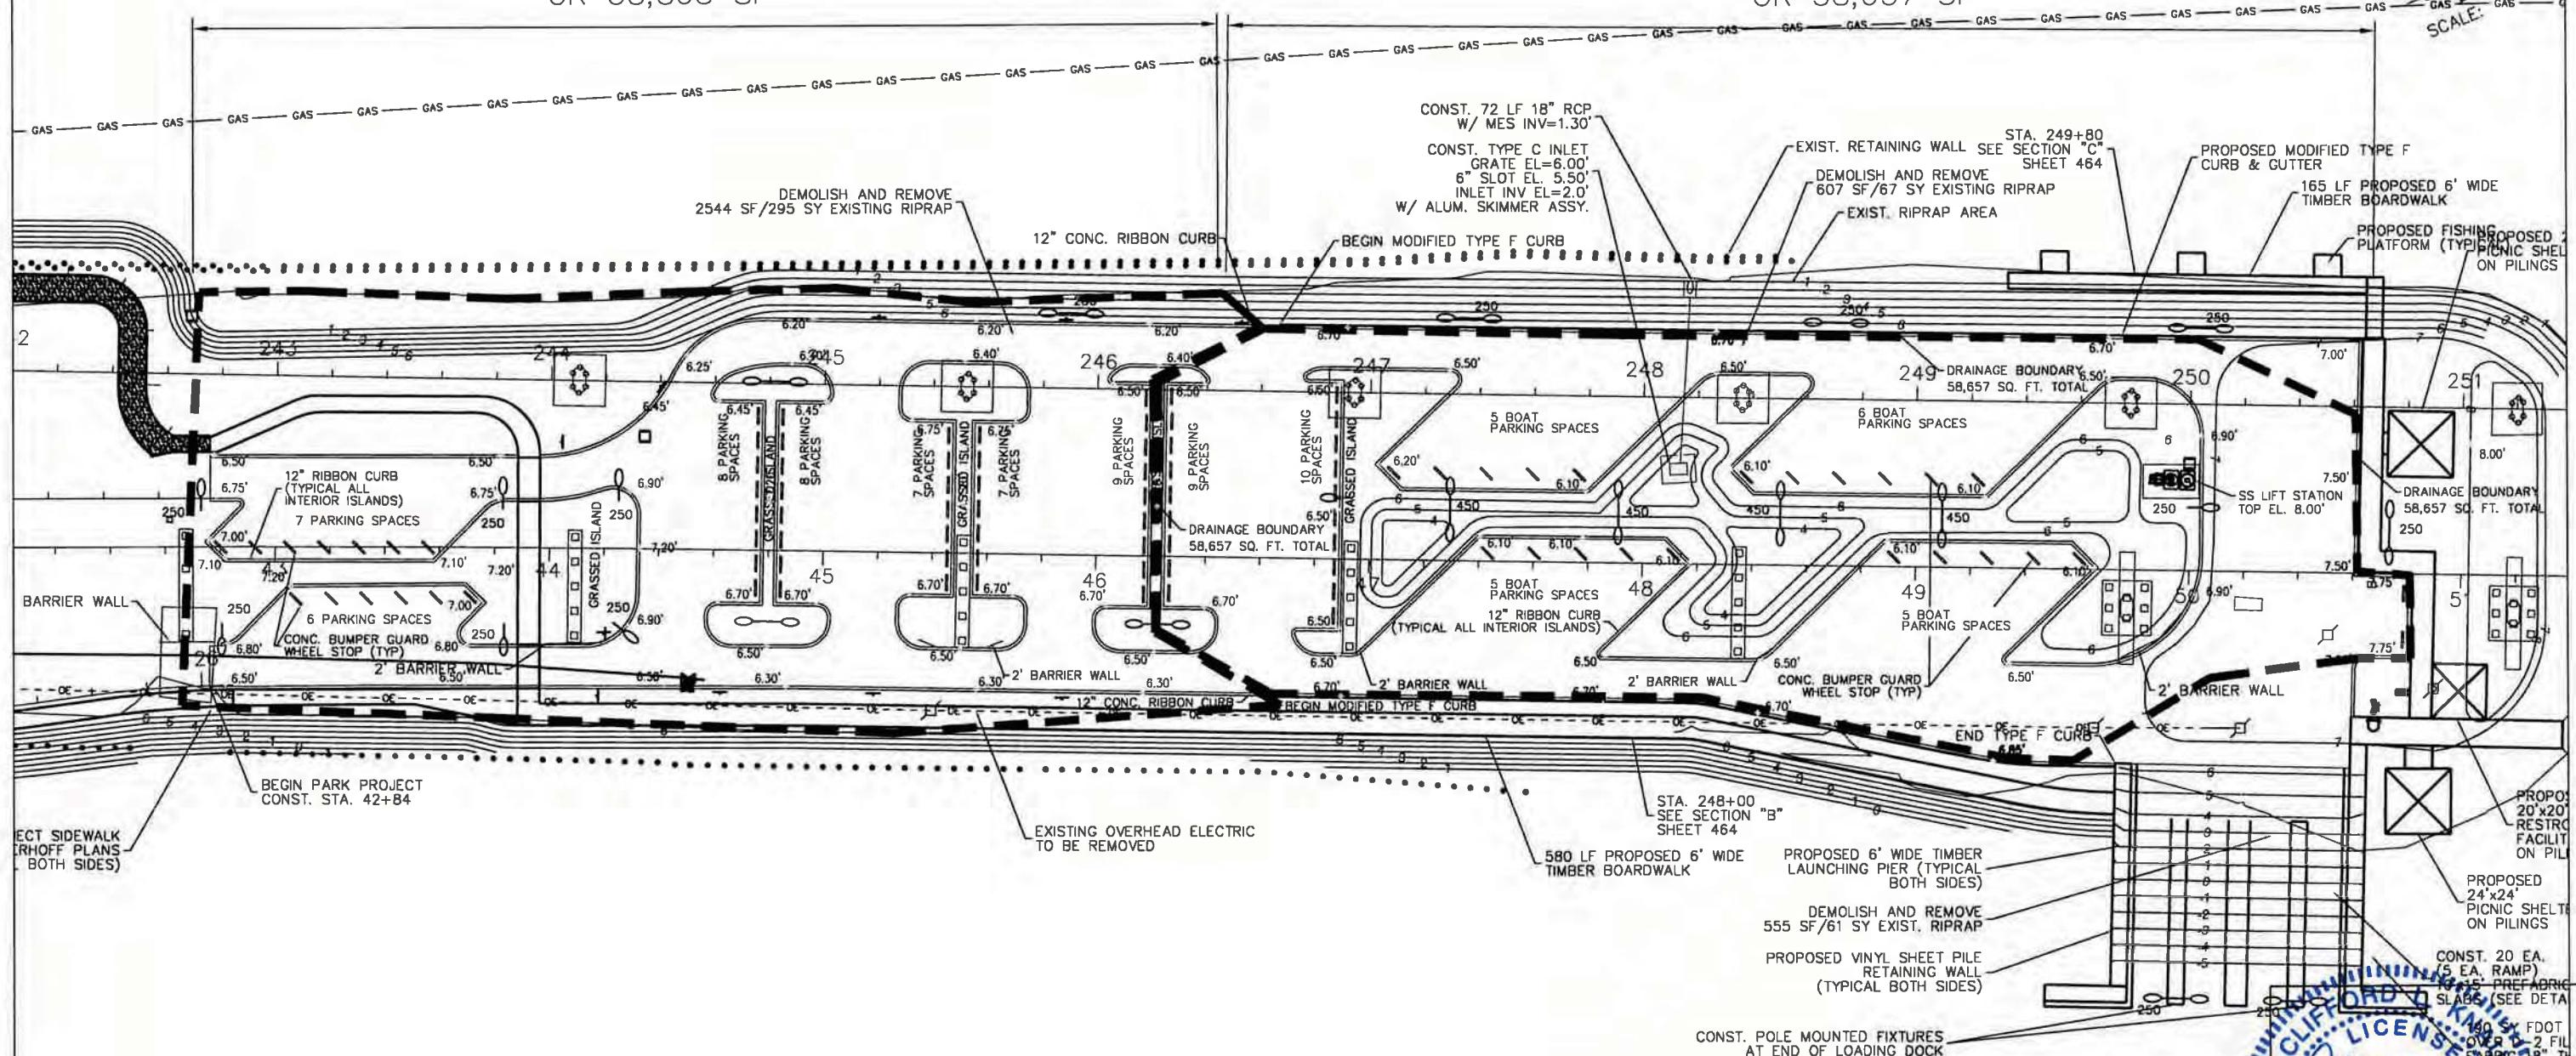

NO.	DATE	APPR.	REVISION:
1	12-19-13	CLK	ADDED BASIN B-1 AND B-2 DELINEATION
2	12-21-13		
3			
4			
5			



PREBLE-RISH, INC.  
CONSULTING ENGINEERS  
CIVIL • SURVEYING • SITE PLANNING

324 MARINA DRIVE  
PORT ST. JOE, FL 32458  
(850) 227-7200


203 ABERDEEN PARKWAY  
PANAMA CITY, FL 32405  
(850) 522-0944

2087 CENTRAL AVE. EAST  
BLOUNTSTOWN, FL 32424  
(850) 674-3300

877 COUNTY ROAD 363  
SANTA ROSA BEACH, FL 32459  
(850) 267-0759



STORMWATER BASIN DELINEATION MAP  
SR-83 CHOCTAWHATCHEE BAY BRIDGE

DATE: 827.001	PROJECT NO. 827.001
SCALE: 1'=60'-0"	
DRAWN: JM	
CHECKED: CLK	

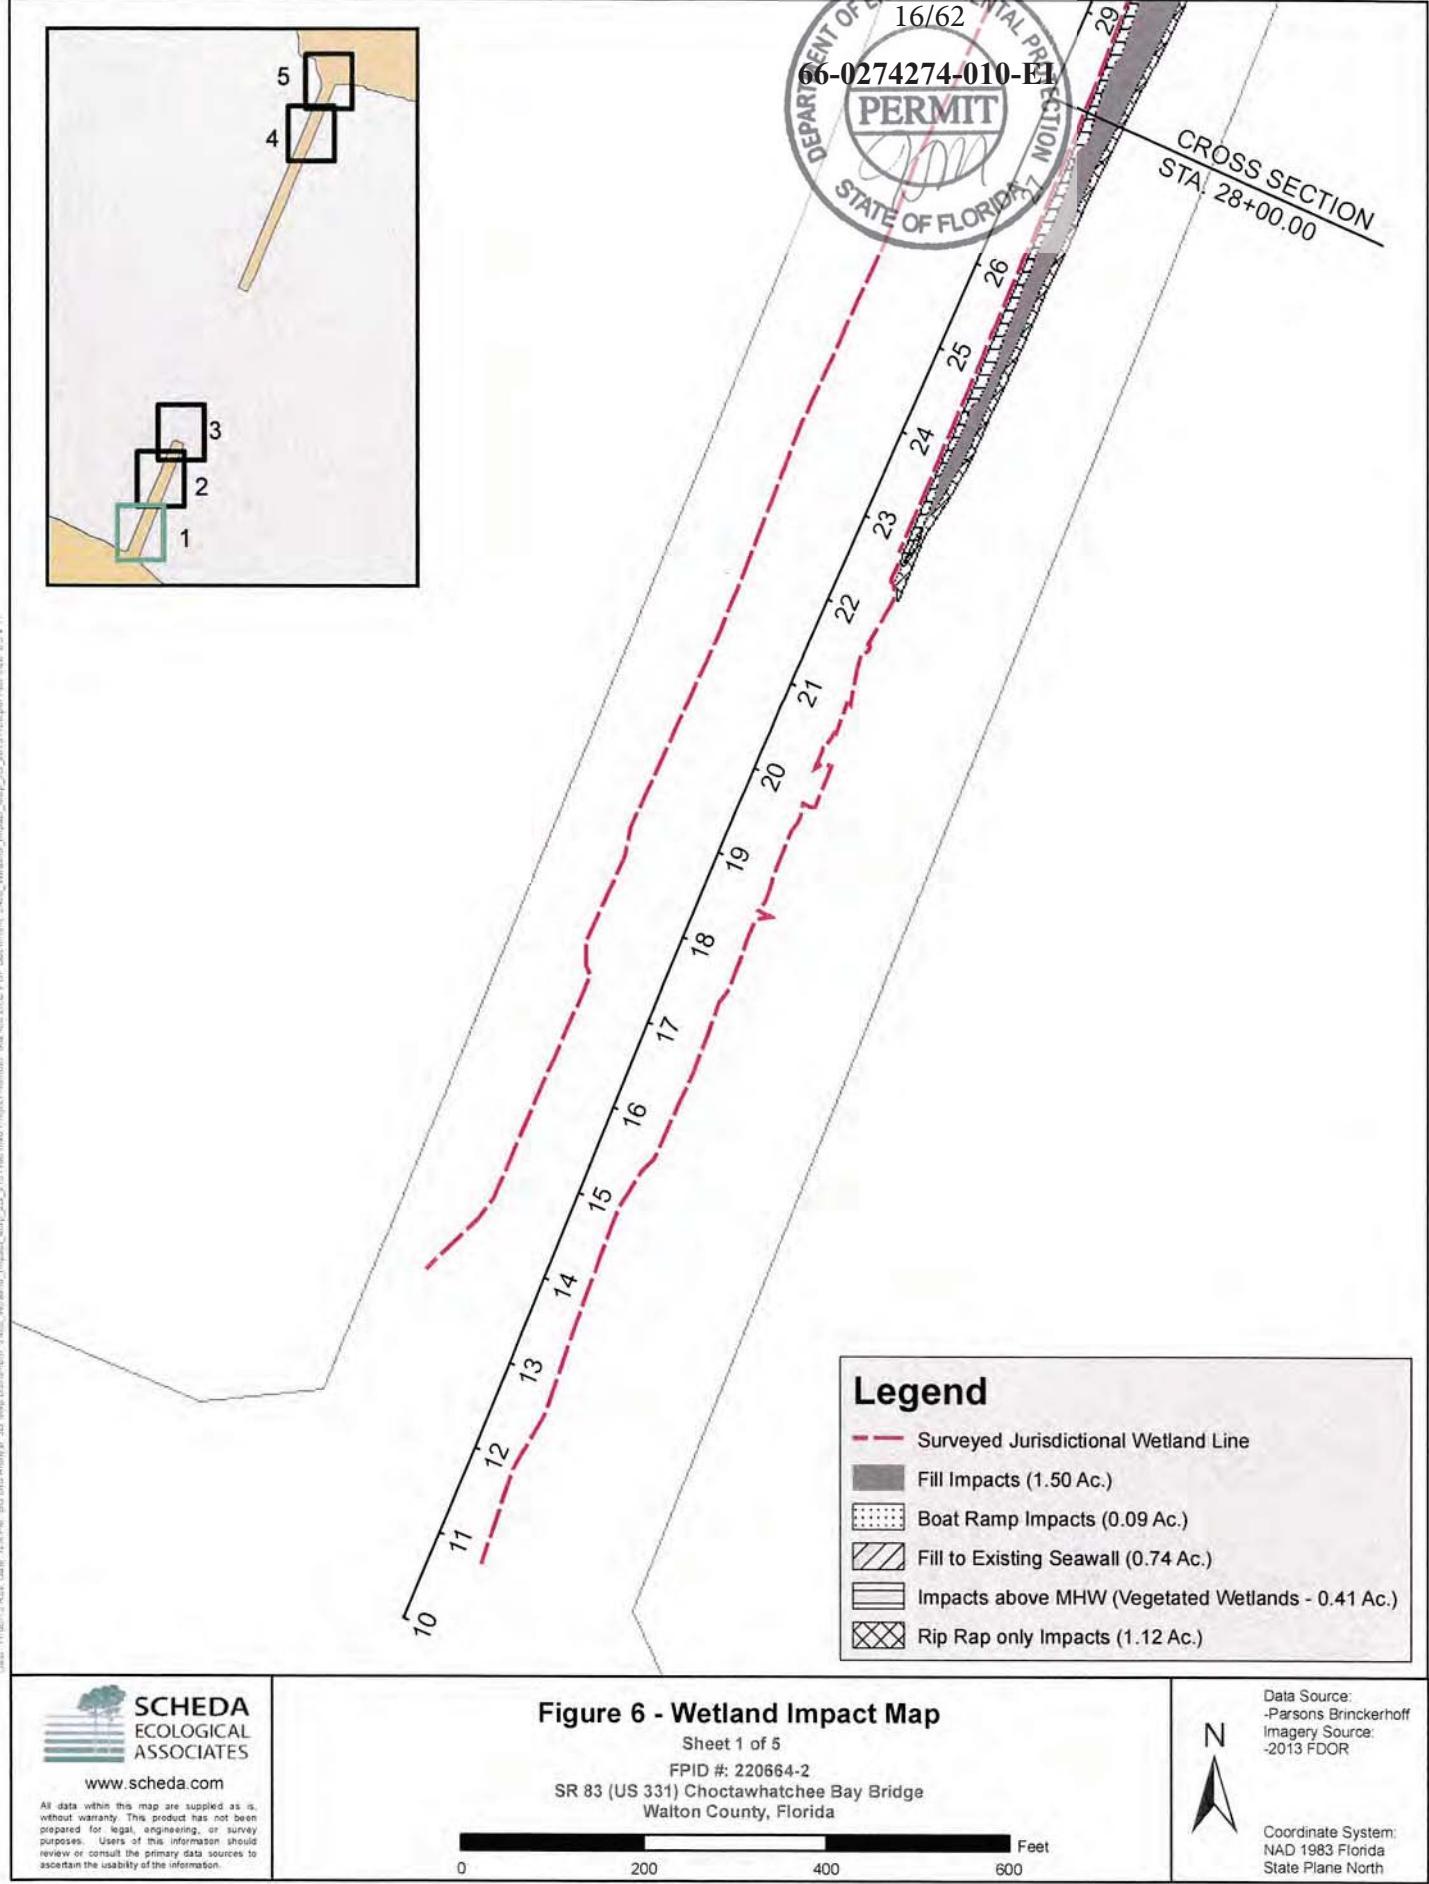

[www.scheda.com](http://www.scheda.com)

All data within this map are supplied as is, without warranty. This product has not been prepared for legal, engineering, or survey purposes. Users of this information should review or consult the primary data sources to ascertain the usability of the information.

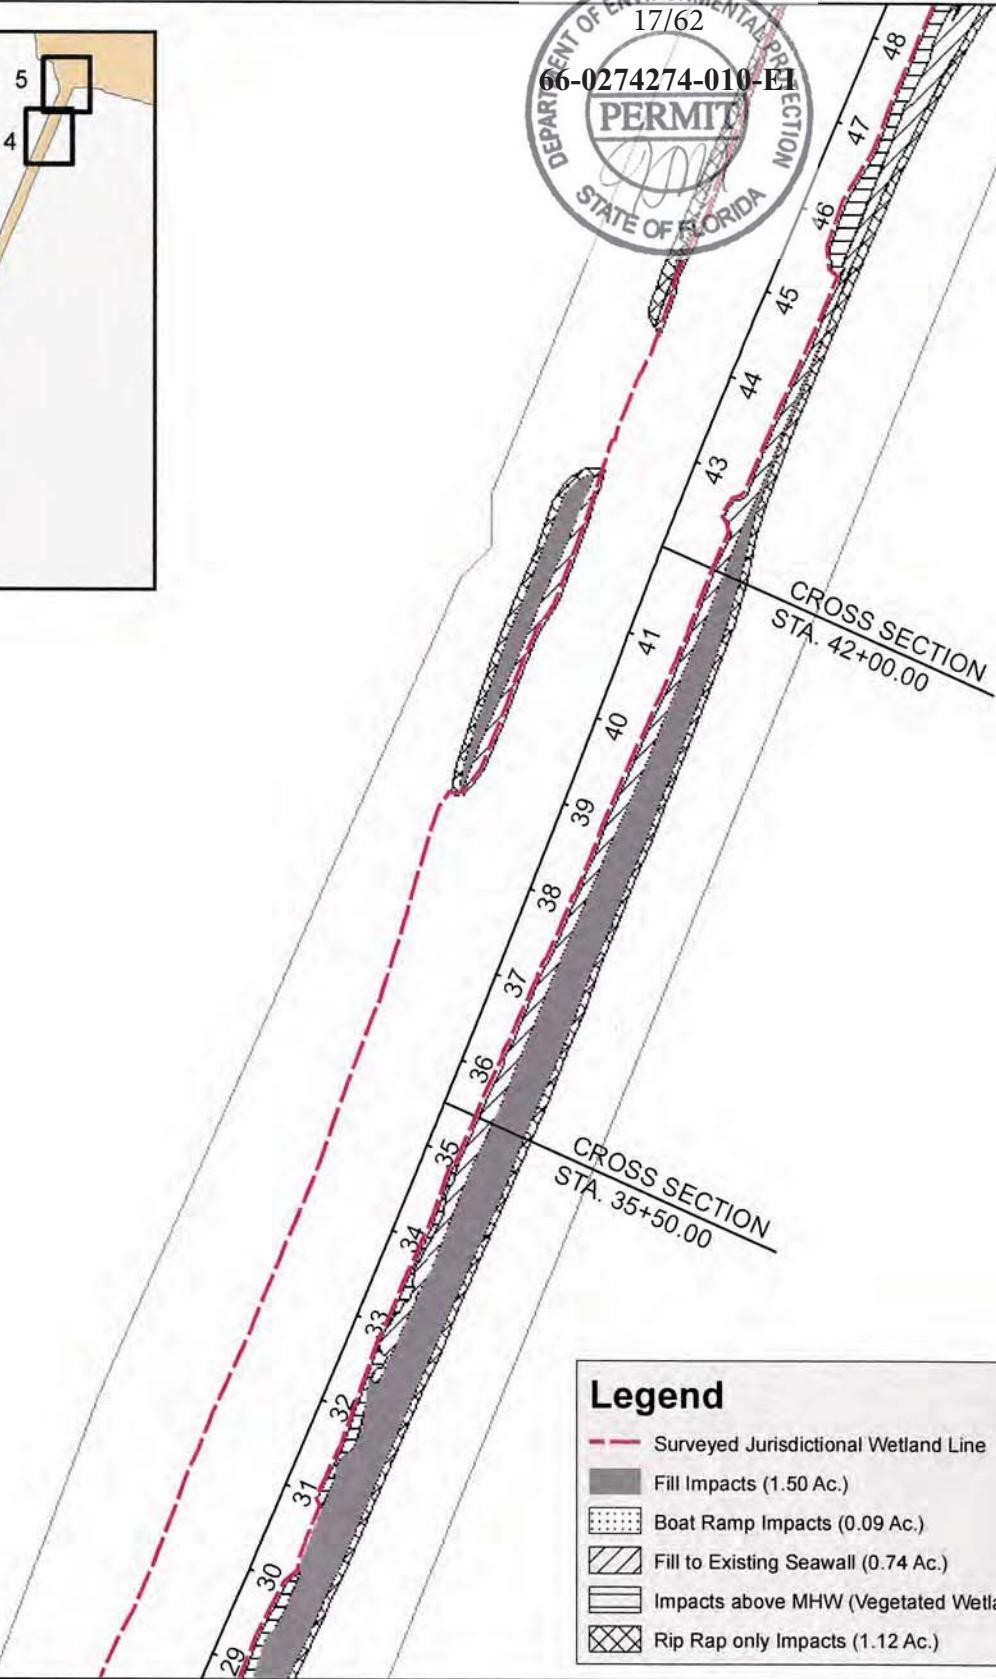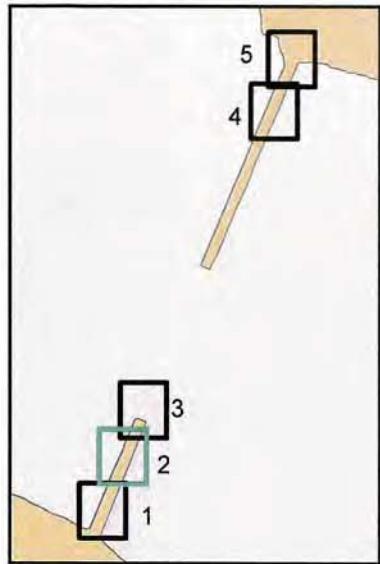

### Legend

- Surveyed Jurisdictional Wetland Line
- Fill Impacts (1.50 Ac.)
- Boat Ramp Impacts (0.09 Ac.)
- Fill to Existing Seawall (0.74 Ac.)
- Impacts above MHW (Vegetated Wetlands - 0.41 Ac.)
- Rip Rap only Impacts (1.12 Ac.)



[www.scheda.com](http://www.scheda.com)

All data within this map are supplied as is, without warranty. This report has not been prepared for legal, engineering, or survey purposes. Users of this information should review or consult the primary data sources to ascertain the usability of the information.

**Figure 6 - Wetland Impact Map**

Sheet 2 of 5

FPID #: 220664-2


SR 83 (US 331) Choctawhatchee Bay Bridge  
Walton County, Florida

0 200 400 600 Feet

Data Source:  
-Parsons Brinckerhoff  
Imagery Source:  
-2013 FDOR





Coordinate System:  
NAD 1983 Florida  
State Plane North

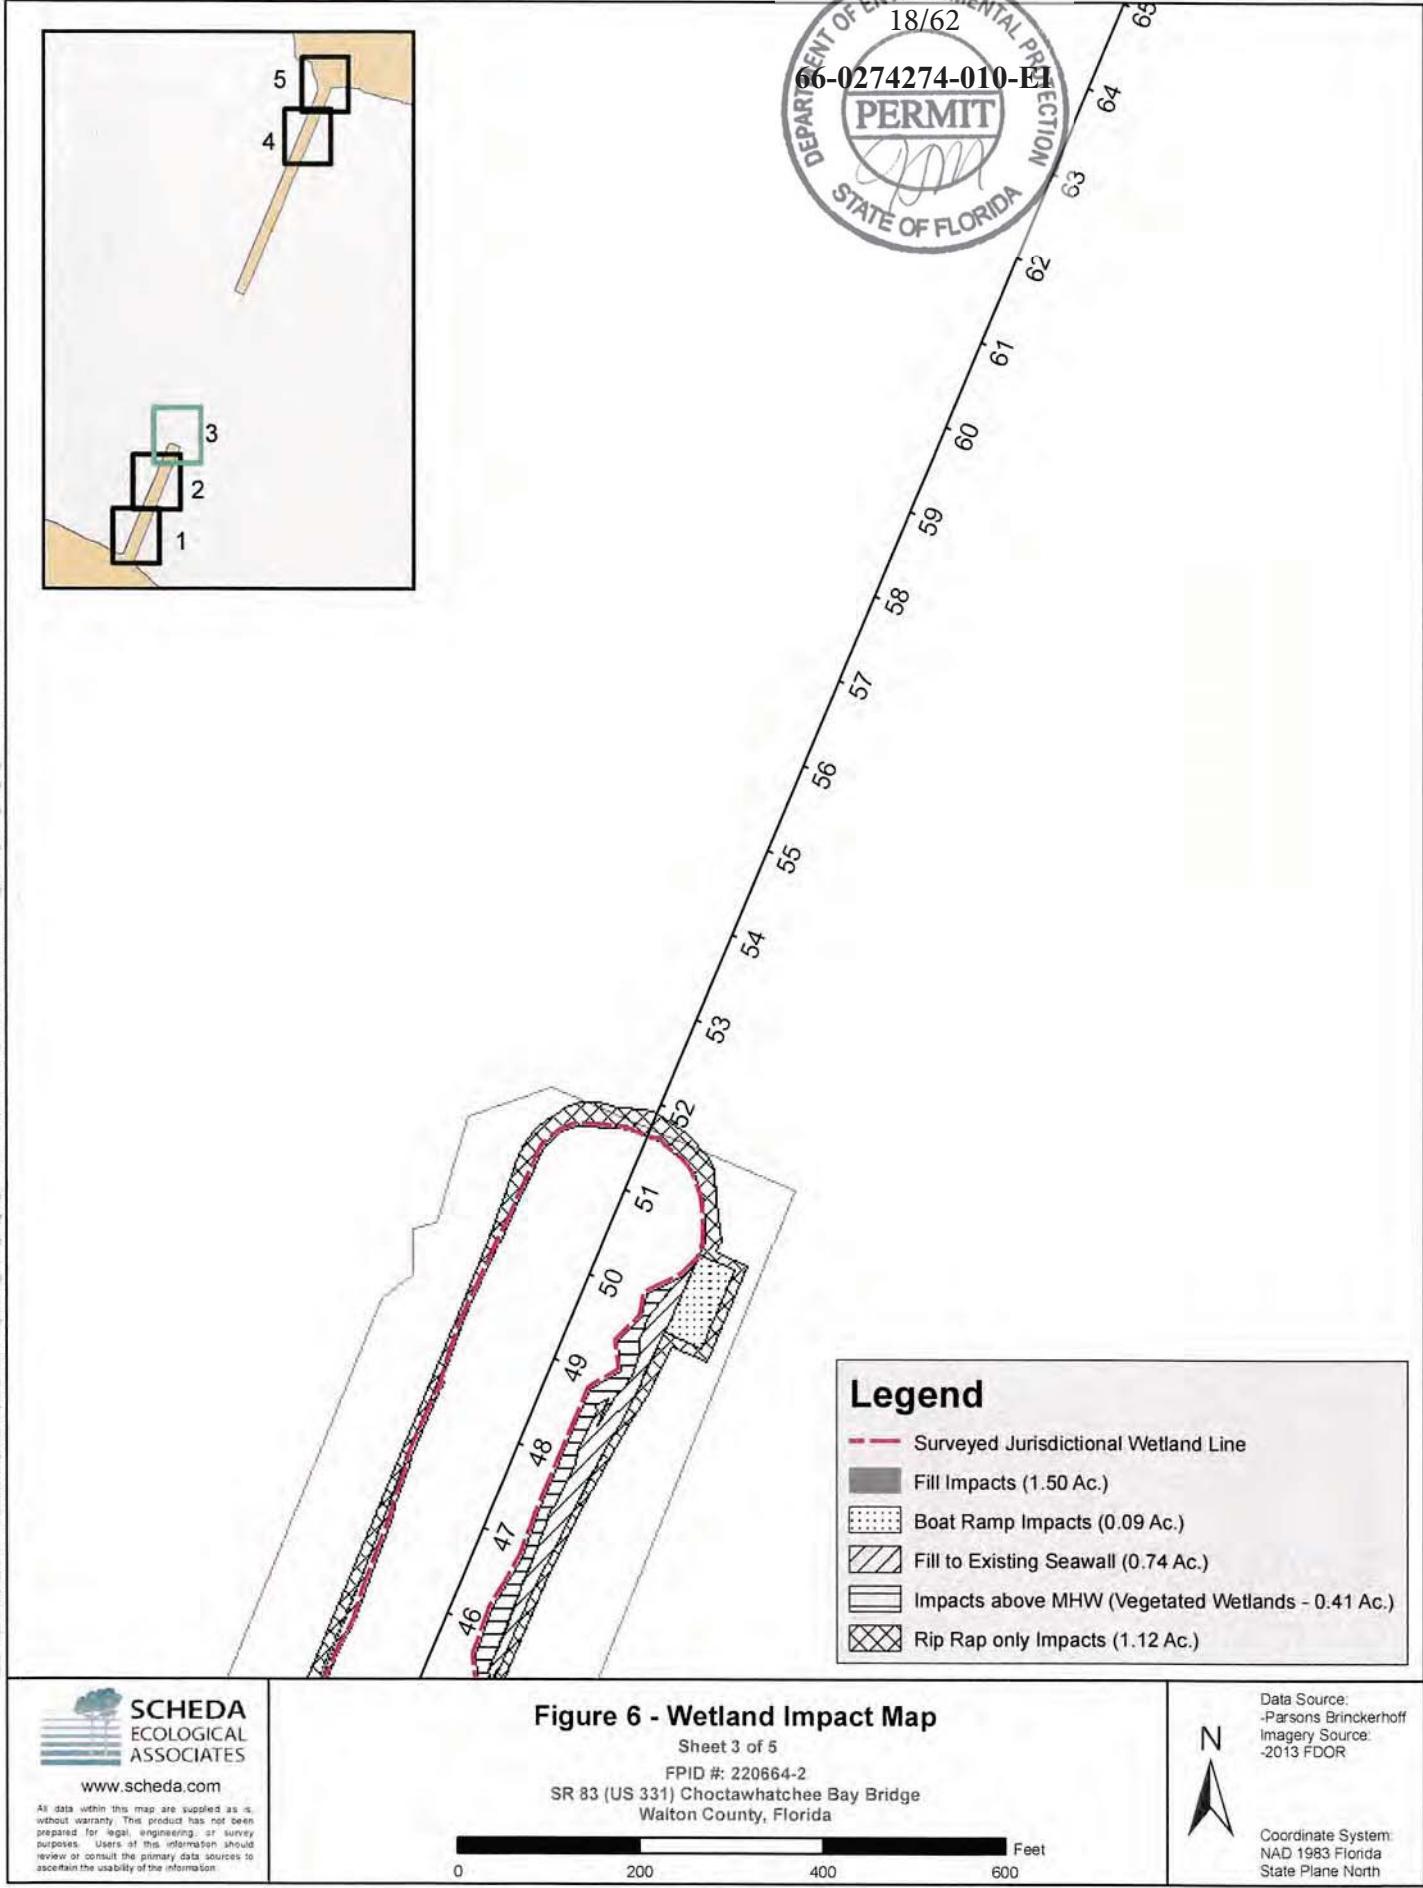

[www.scheda.com](http://www.scheda.com)

All data within this map are supplied as is.  
 Parsons Brinckerhoff has not prepared  
 this map for legal, engineering, or survey  
 purposes. Users of this information should  
 review or consult the primary data sources to  
 ascertain the usability of the information.

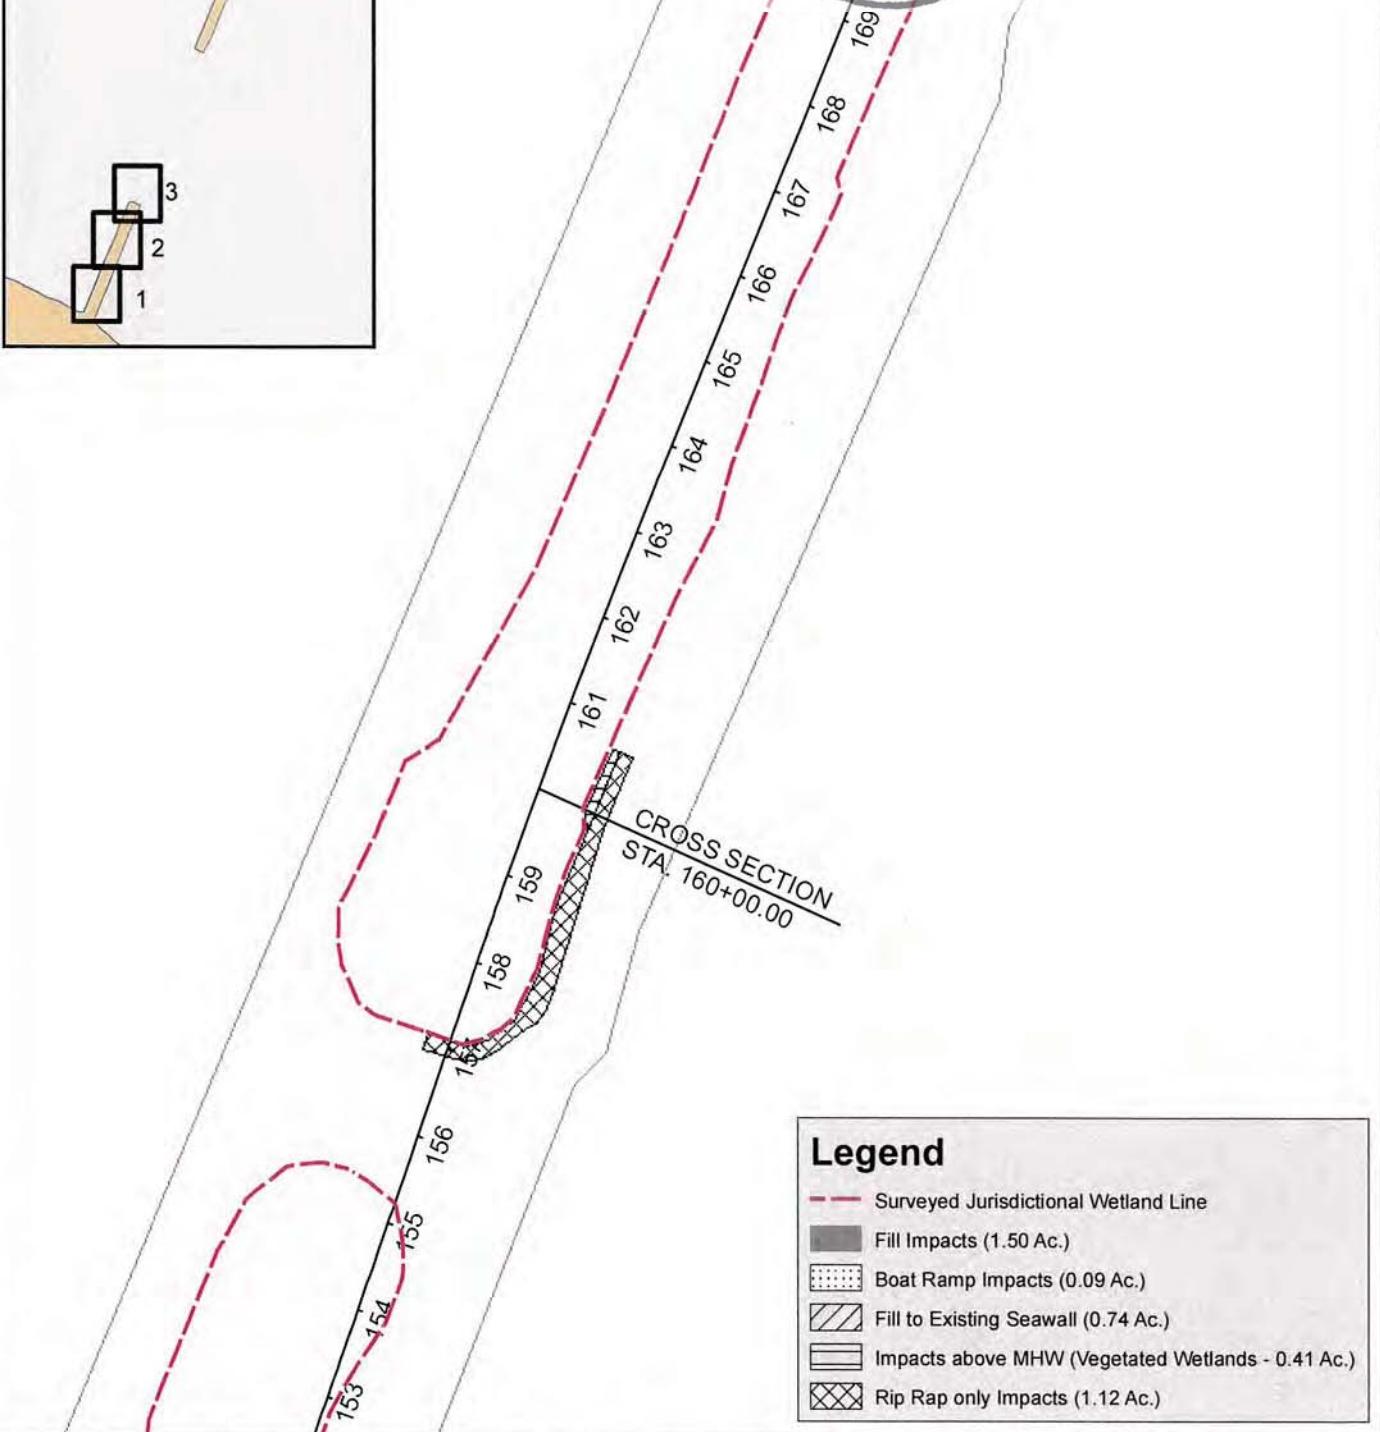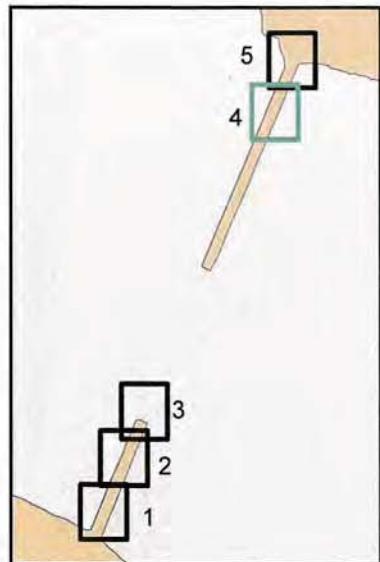

All data within this map are supplied as is, without warranty. This product has not been prepared for legal, engineering, or survey purposes. Users of this information should review or consult the primary data sources to ascertain the usability of the information.

**Figure 6 - Wetland Impact Map**

Sheet 4 of 5

FPID #: 220664-2



SR 83 (US 331) Choctawhatchee Bay Bridge  
Walton County, Florida

0 200 400 600 Feet

Data Source:  
-Parsons Brinckerhoff  
Imagery Source:  
-2013 FDOR



Coordinate System:  
NAD 1983 Florida  
State Plane North

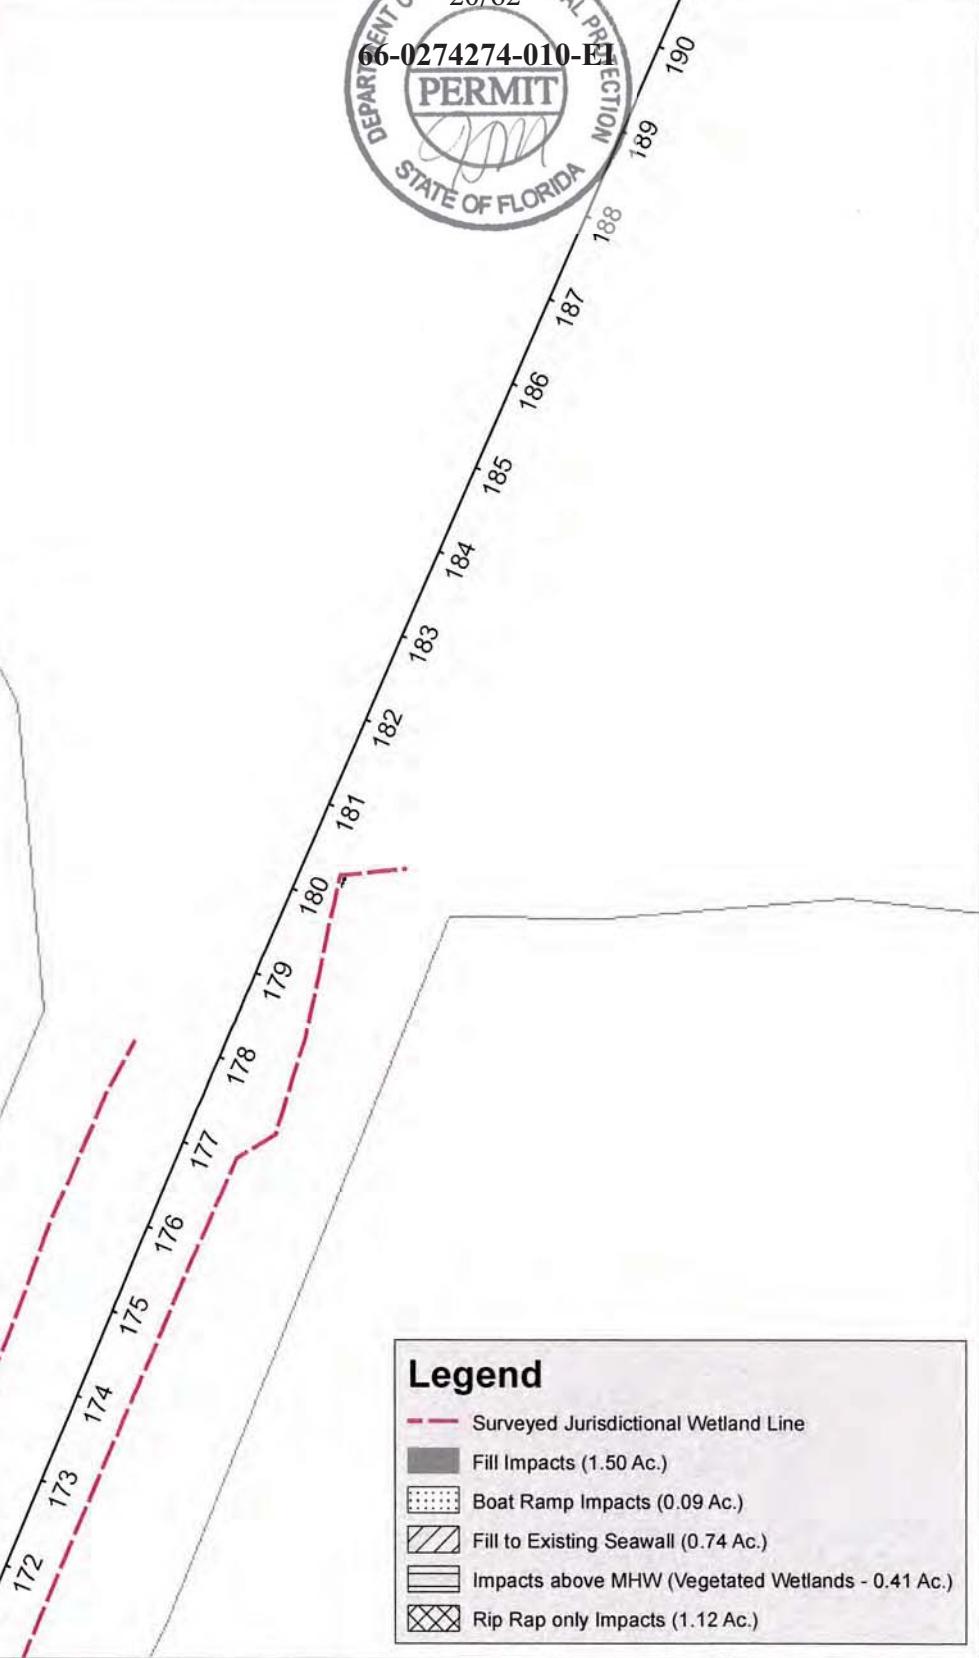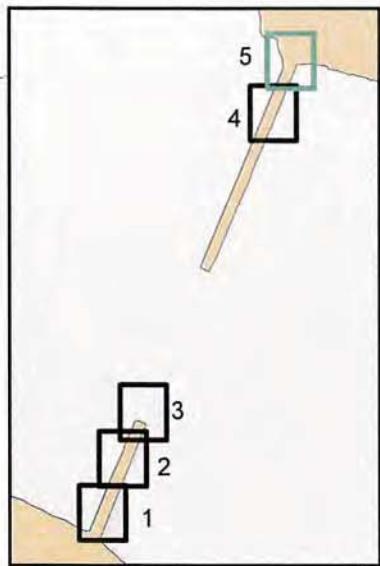

[www.scheda.com](http://www.scheda.com)

All data within this map are supplied as is, without warranty. This product has not been prepared for legal, engineering, or survey purposes. Users of this information should review or consult the primary data sources to ascertain the usability of the information.

**Figure 6 - Wetland Impact Map**

Sheet 5 of 5

FPID #: 220664-2

SR 83 (US 331) Choctawhatchee Bay Bridge  
Walton County, Florida

0 200 400 600 Feet

Data Source:  
-Parsons Brinckerhoff  
Imagery Source:  
-2013 FDOR




Coordinate System:  
NAD 1983 Florida  
State Plane North



~~1"~~ = 50'  
SCALE: 1"=50'

SEE SHEET (1)

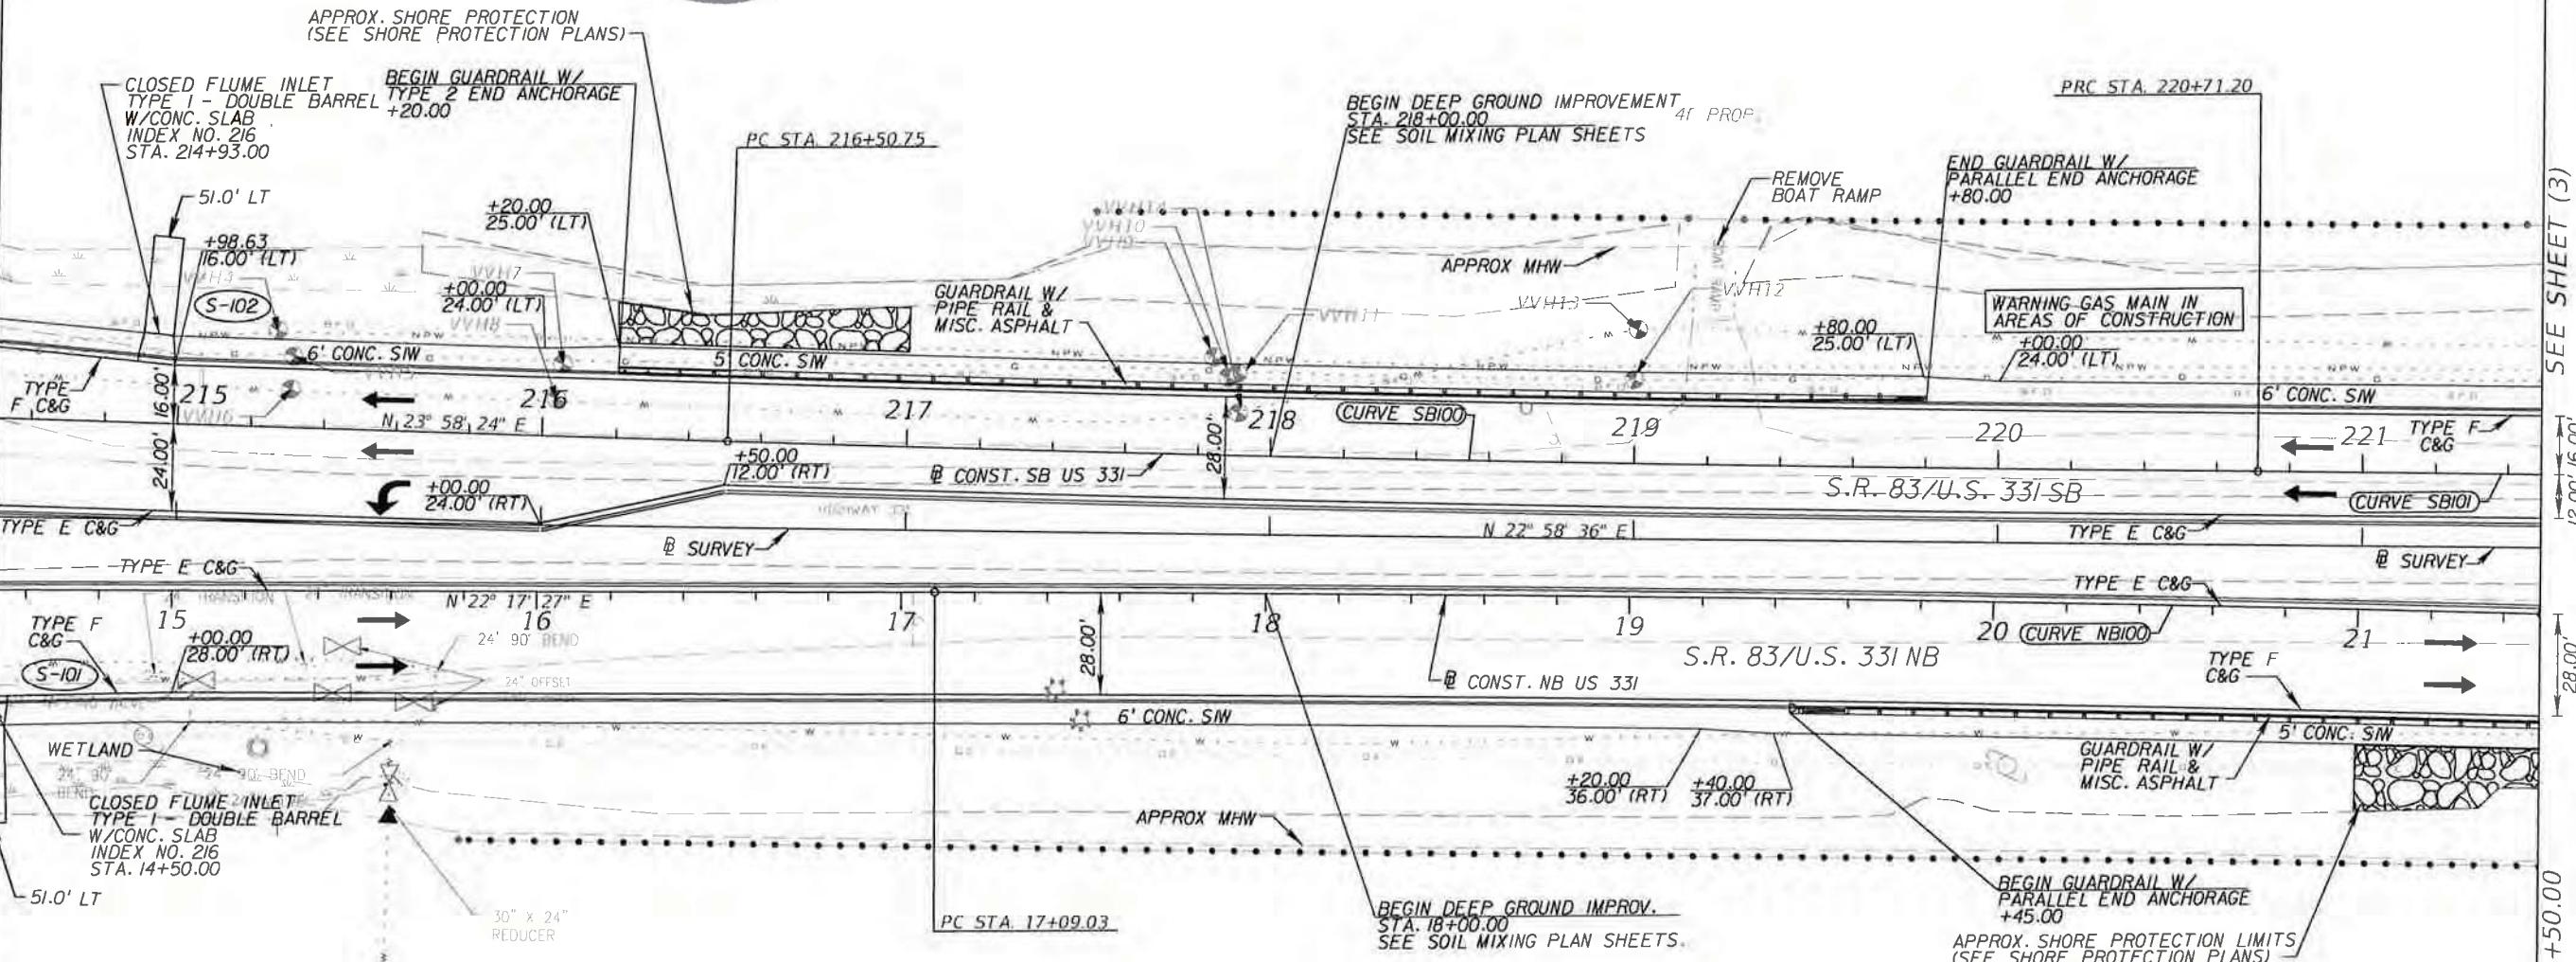

SEE SHEET (3)

12.00' 16.00'

28.00' 28.00'

SHEET  
NO.  
26

REVISIONS			
DATE	DESCRIPTION	DATE	DESCRIPTION

Parsons Brinckerhoff, Inc.  
121 W. Trade Street, Suite 1950  
Charlotte, NC 28202  
(704) 342-8469  
Cert. of Auth. No. 01462  
EOR: Christopher D Davis, P.E. No. 63070

STATE OF FLORIDA  
DEPARTMENT OF TRANSPORTATION


ROAD NO.	COUNTY	FINANCIAL PROJECT ID
83	WALTON	220664-2-52-01

PLAN (2)



SCALE: 1"=50'

SEE SHEET (2)

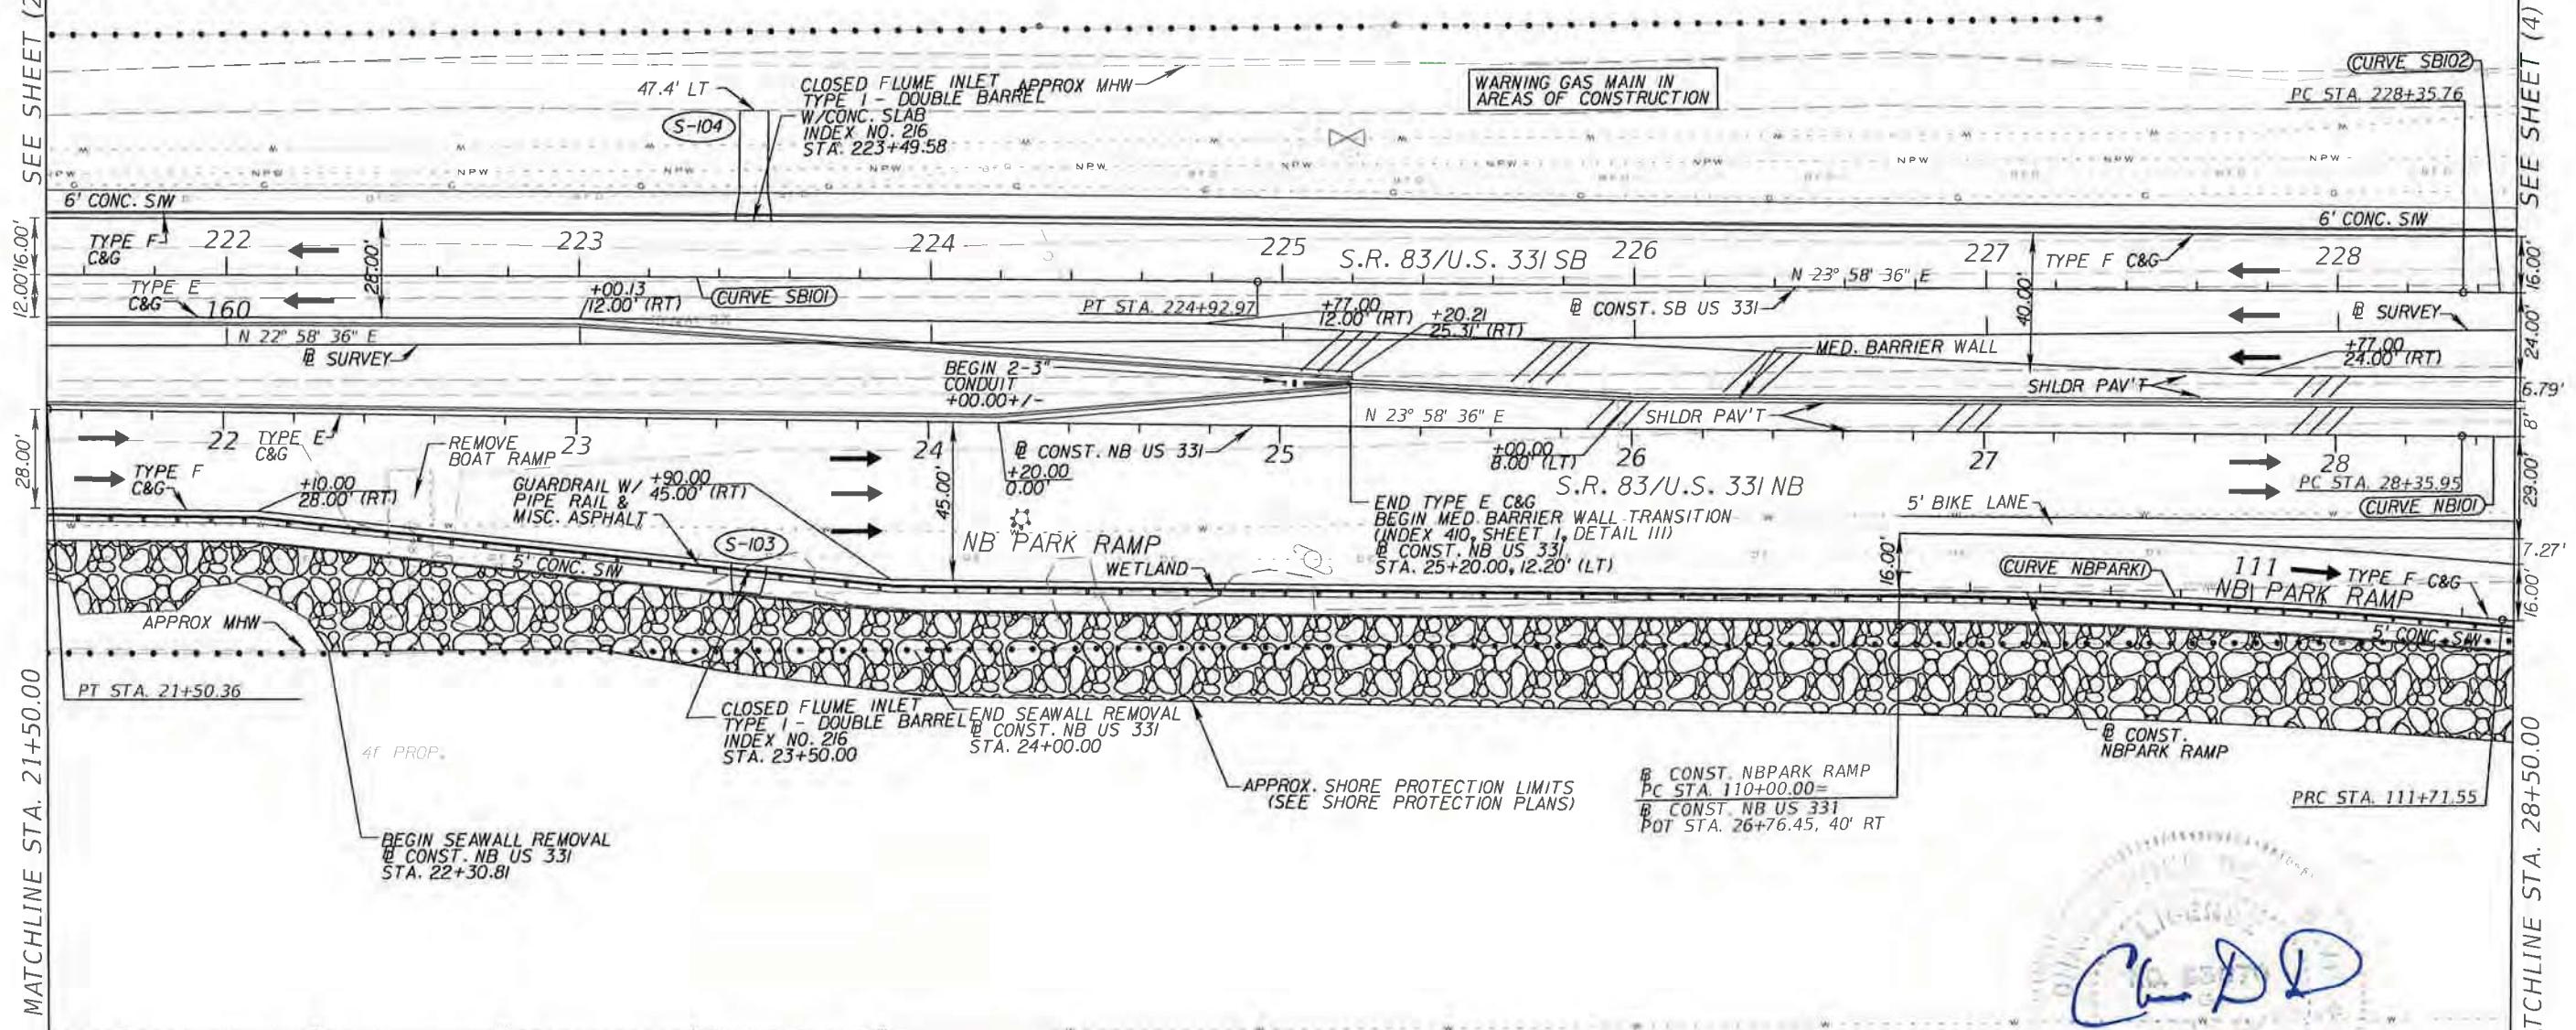

LEGEND  
 PAVED SHOULDER

REVISIONS		DESCRIPTION	
DATE	DESCRIPTION	DATE	DESCRIPTION

Parsons Brinckerhoff, Inc.  
121 W. Trade Street, Suite 1950  
Charlotte, NC 28202  
(704) 342-8469  
Cert. of Auth. No. 01462  
EOR: Christopher D Davis, P.E. No. 63070

STATE OF FLORIDA  
DEPARTMENT OF TRANSPORTATION


ROAD NO.	COUNTY	FINANCIAL PROJECT ID
83	WALTON	220664-2-52-01

PLAN (3)

SHEET NO.  
27



SCALE: 1"=50'

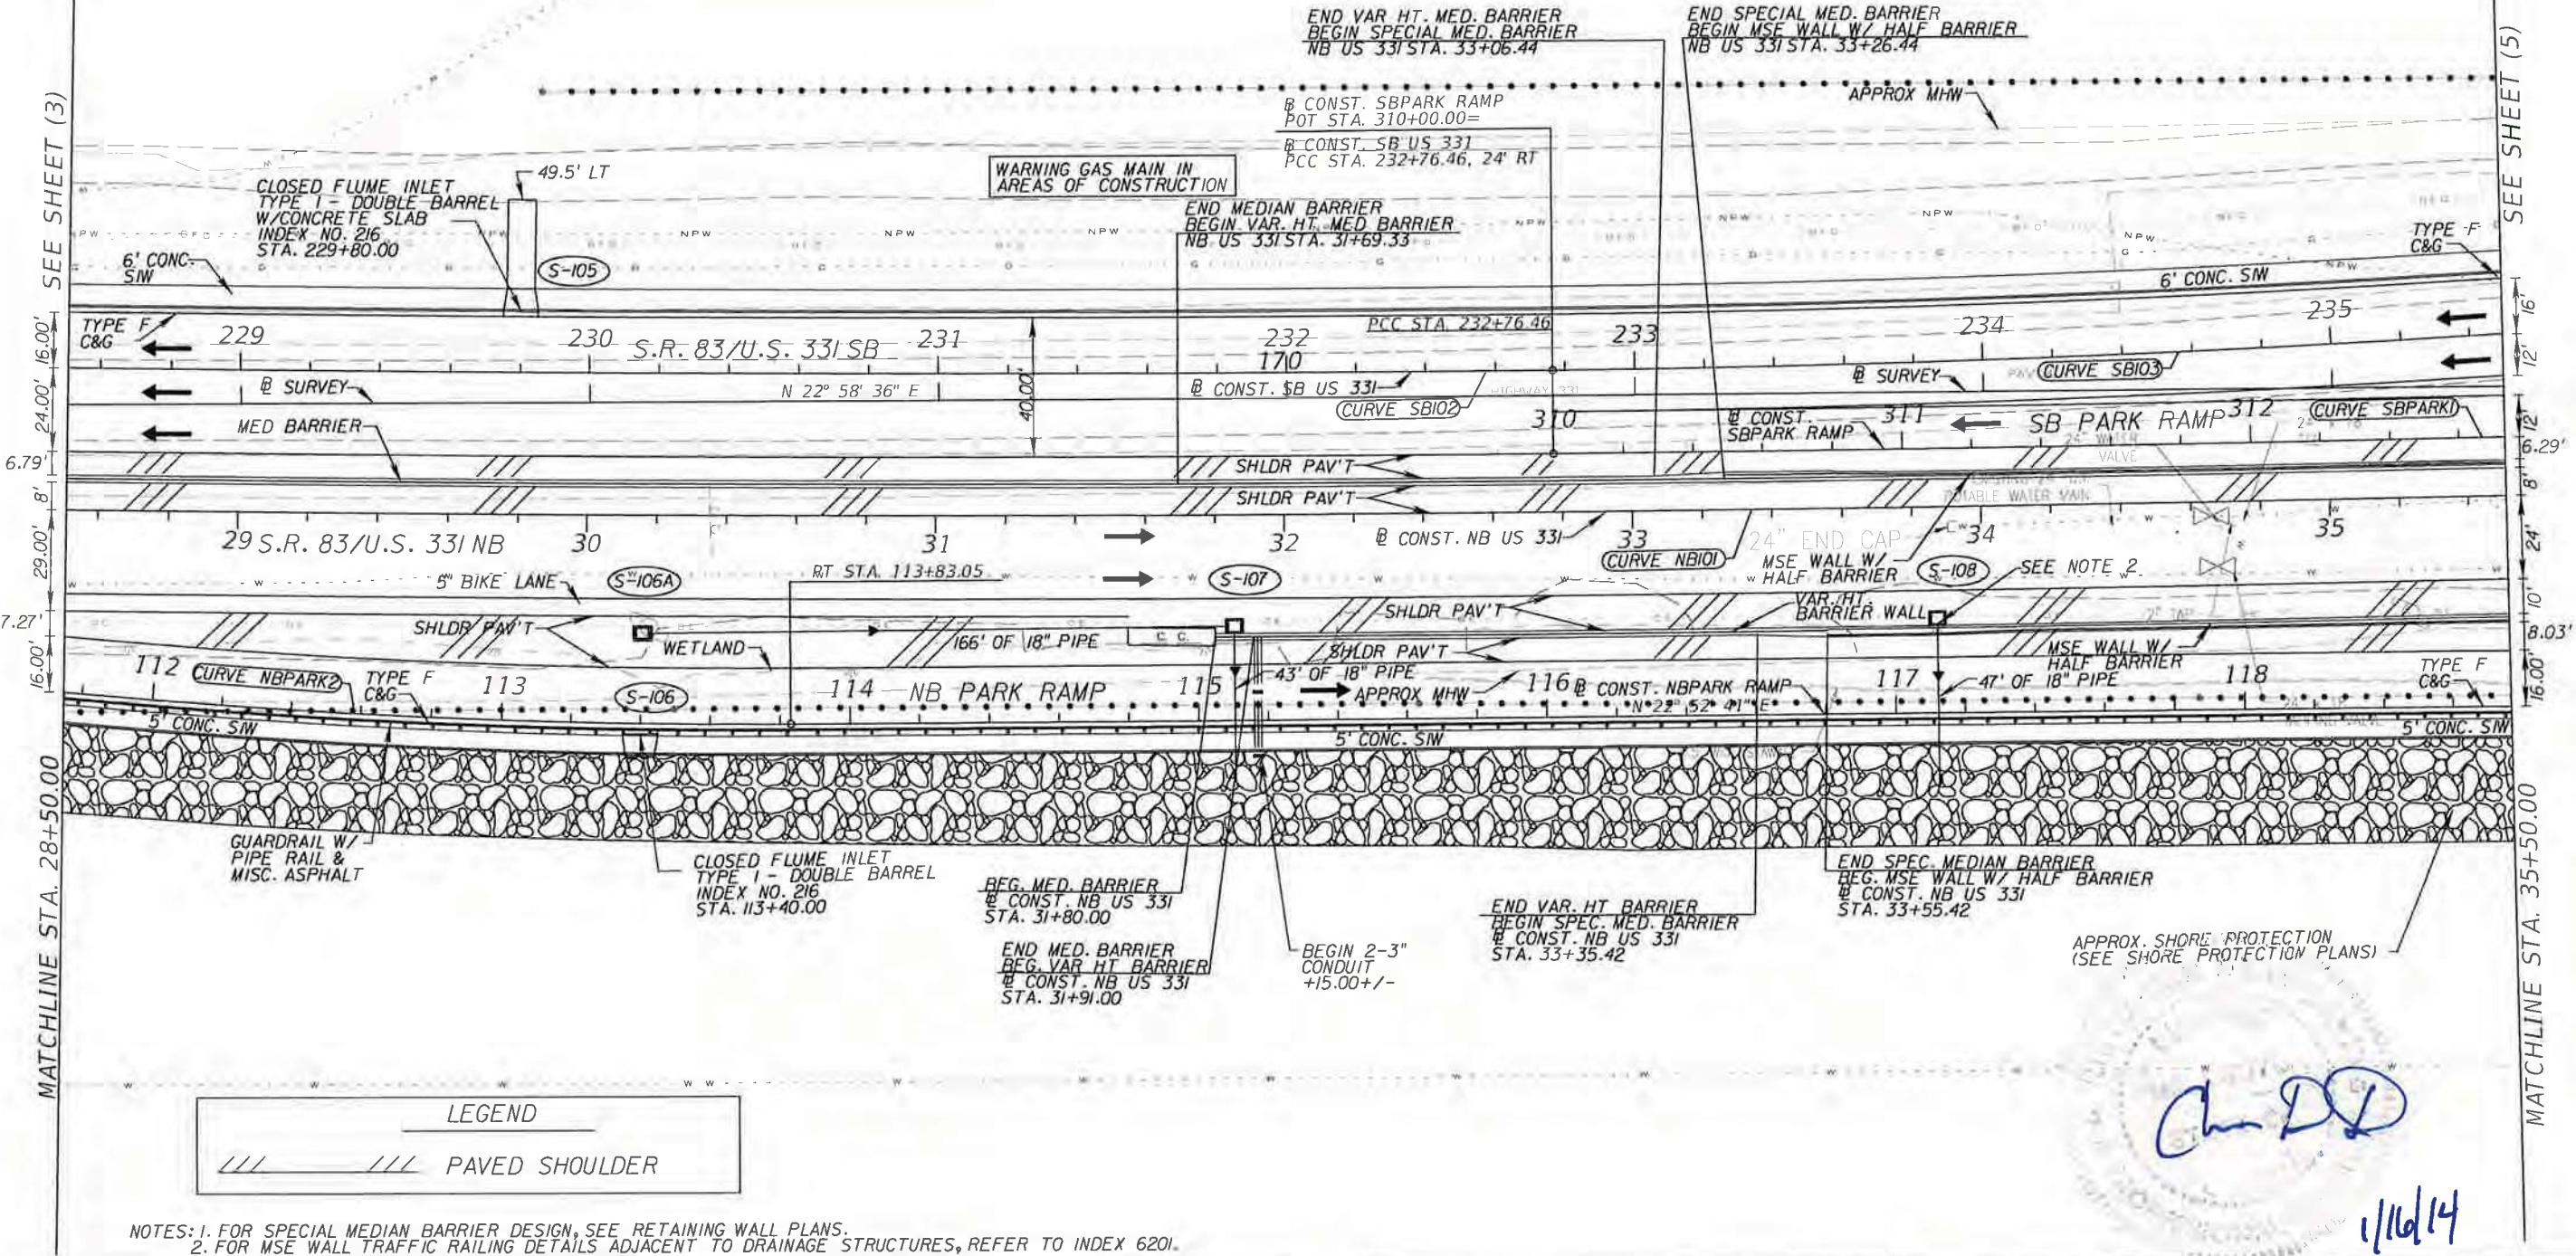




66-0274274-010-EL

PERMIT

SCALE: 1"=50'

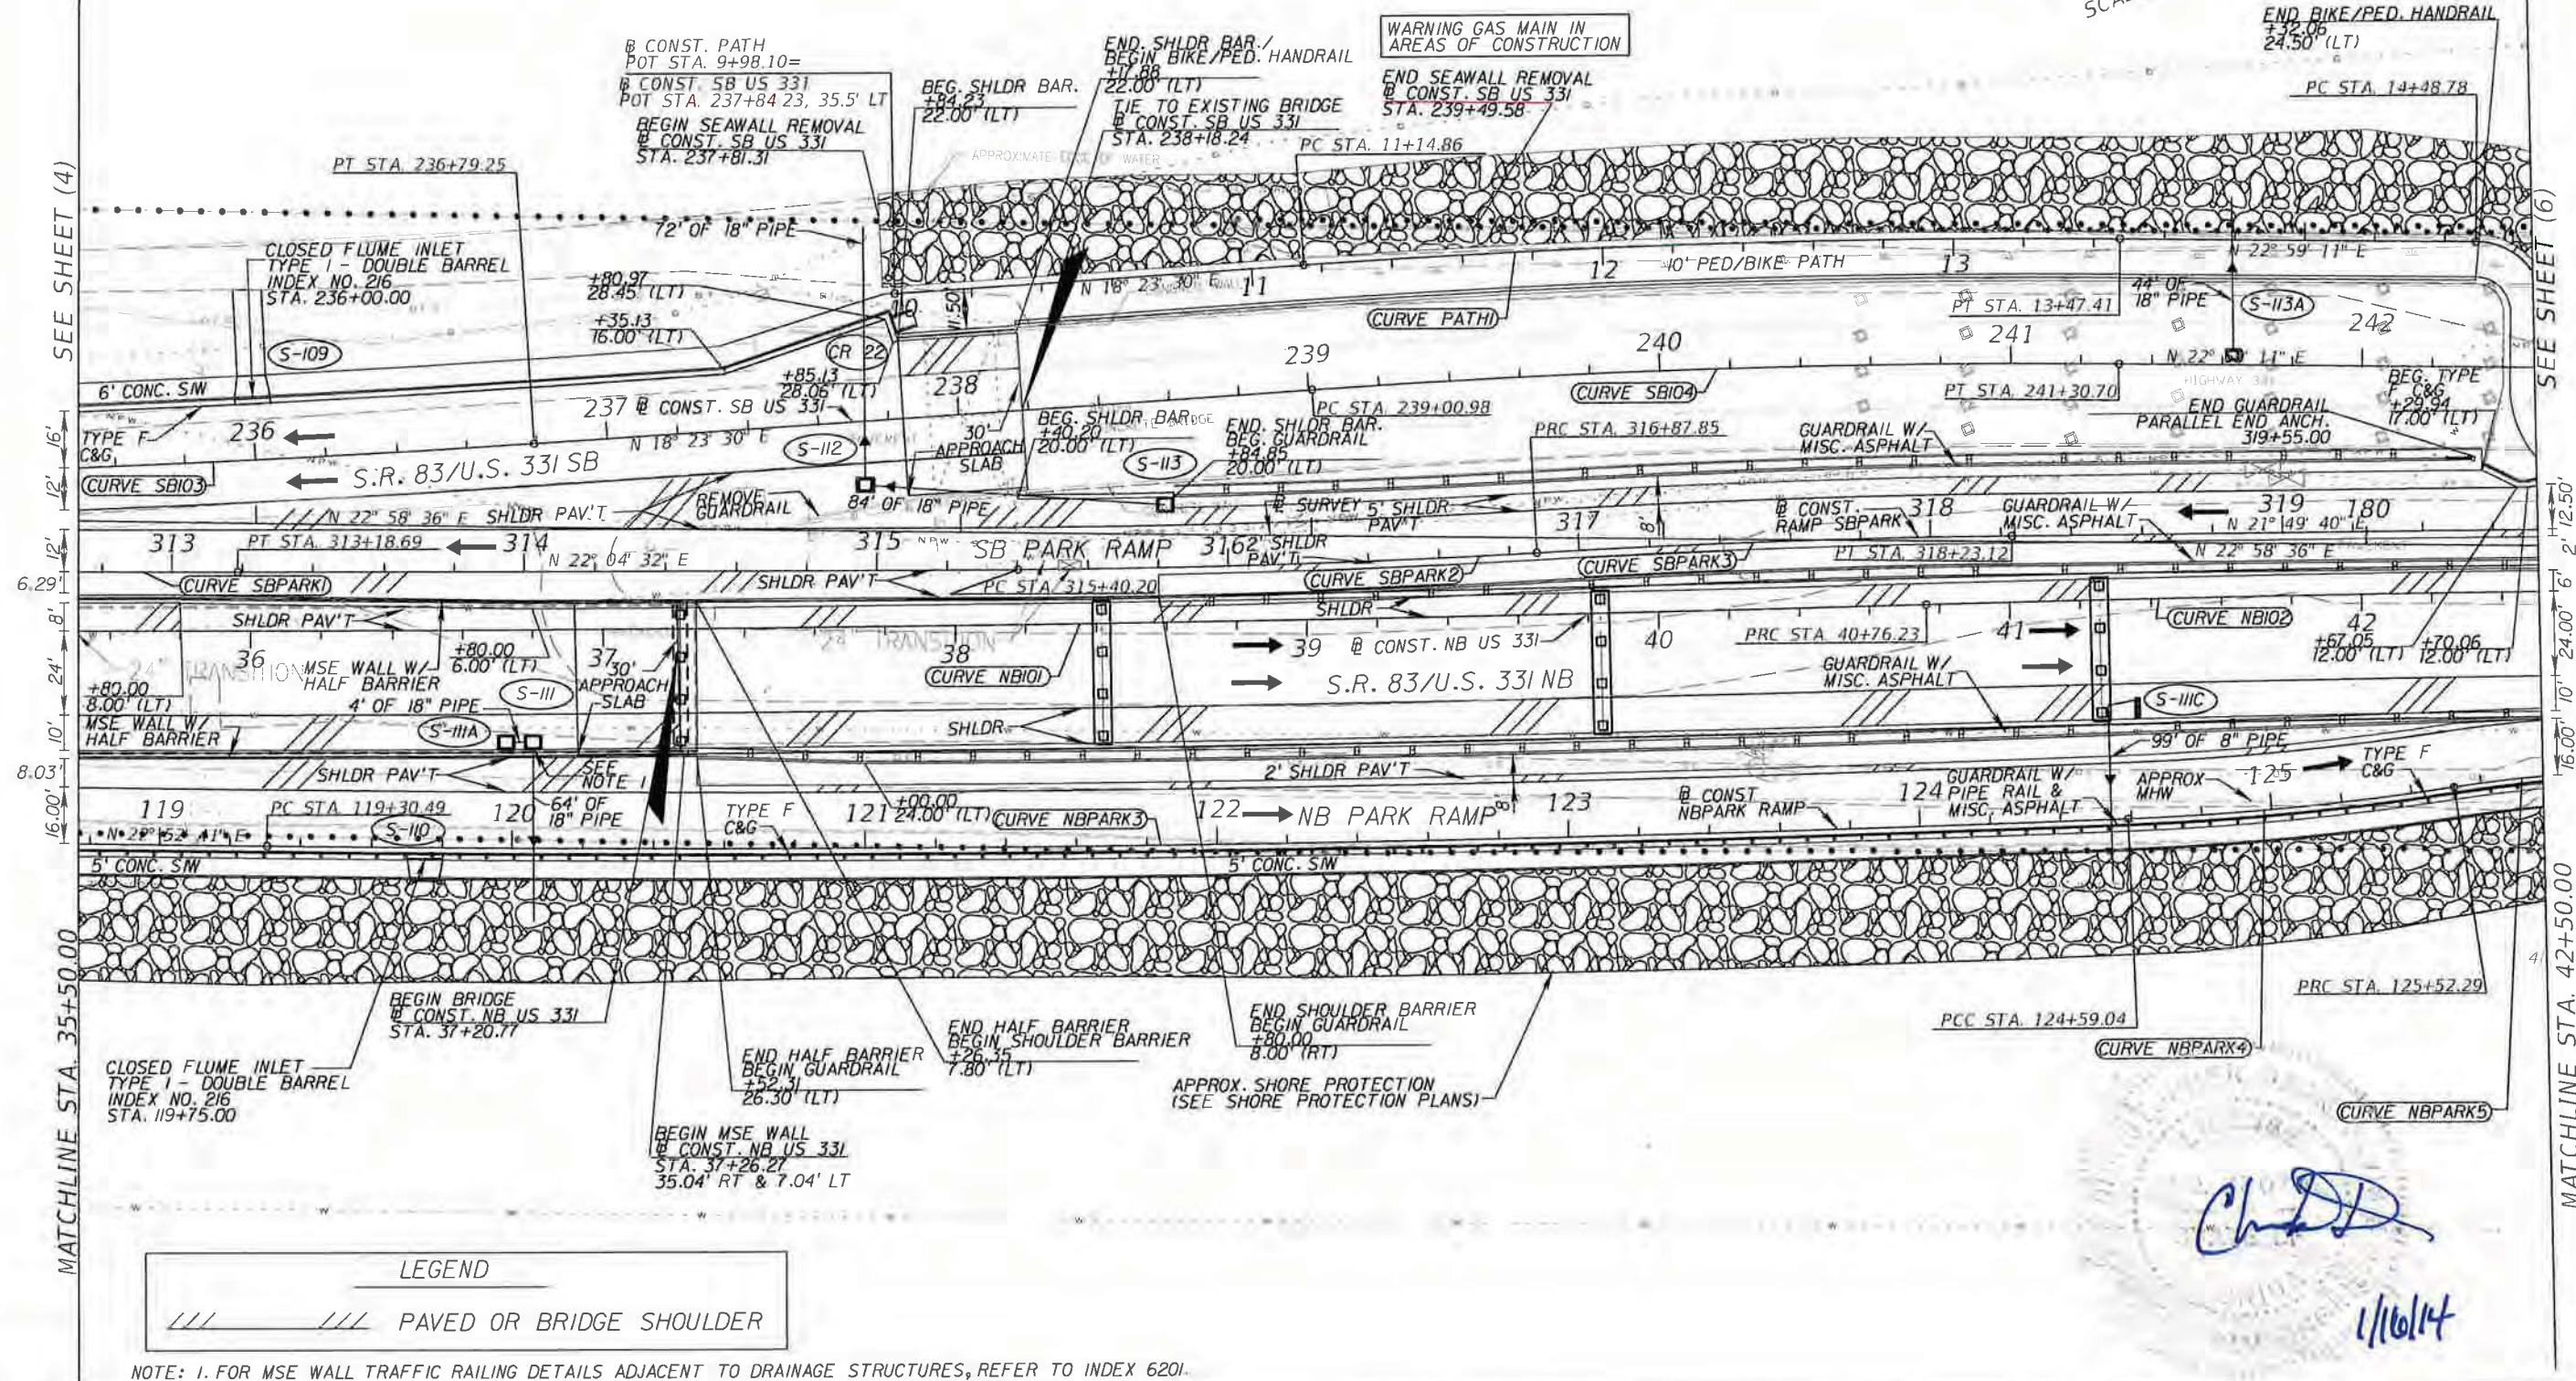

REVISIONS			
DATE	DESCRIPTION	DATE	DESCRIPTION

Parsons Brinckerhoff, Inc.  
121 W. Trade Street, Suite 1950  
Charlotte, NC 28202  
(704) 342-8469  
Cert. of Auth. No. 01462  
EOR: Christopher D Davis, P.E. No. 63070

STATE OF FLORIDA  
DEPARTMENT OF TRANSPORTATION

ROAD NO.	COUNTY	FINANCIAL PROJECT ID
83	WALTON	220664-2-52-01

SHEET NO.


29

PLAN (5)





SCALE: 1"=50'

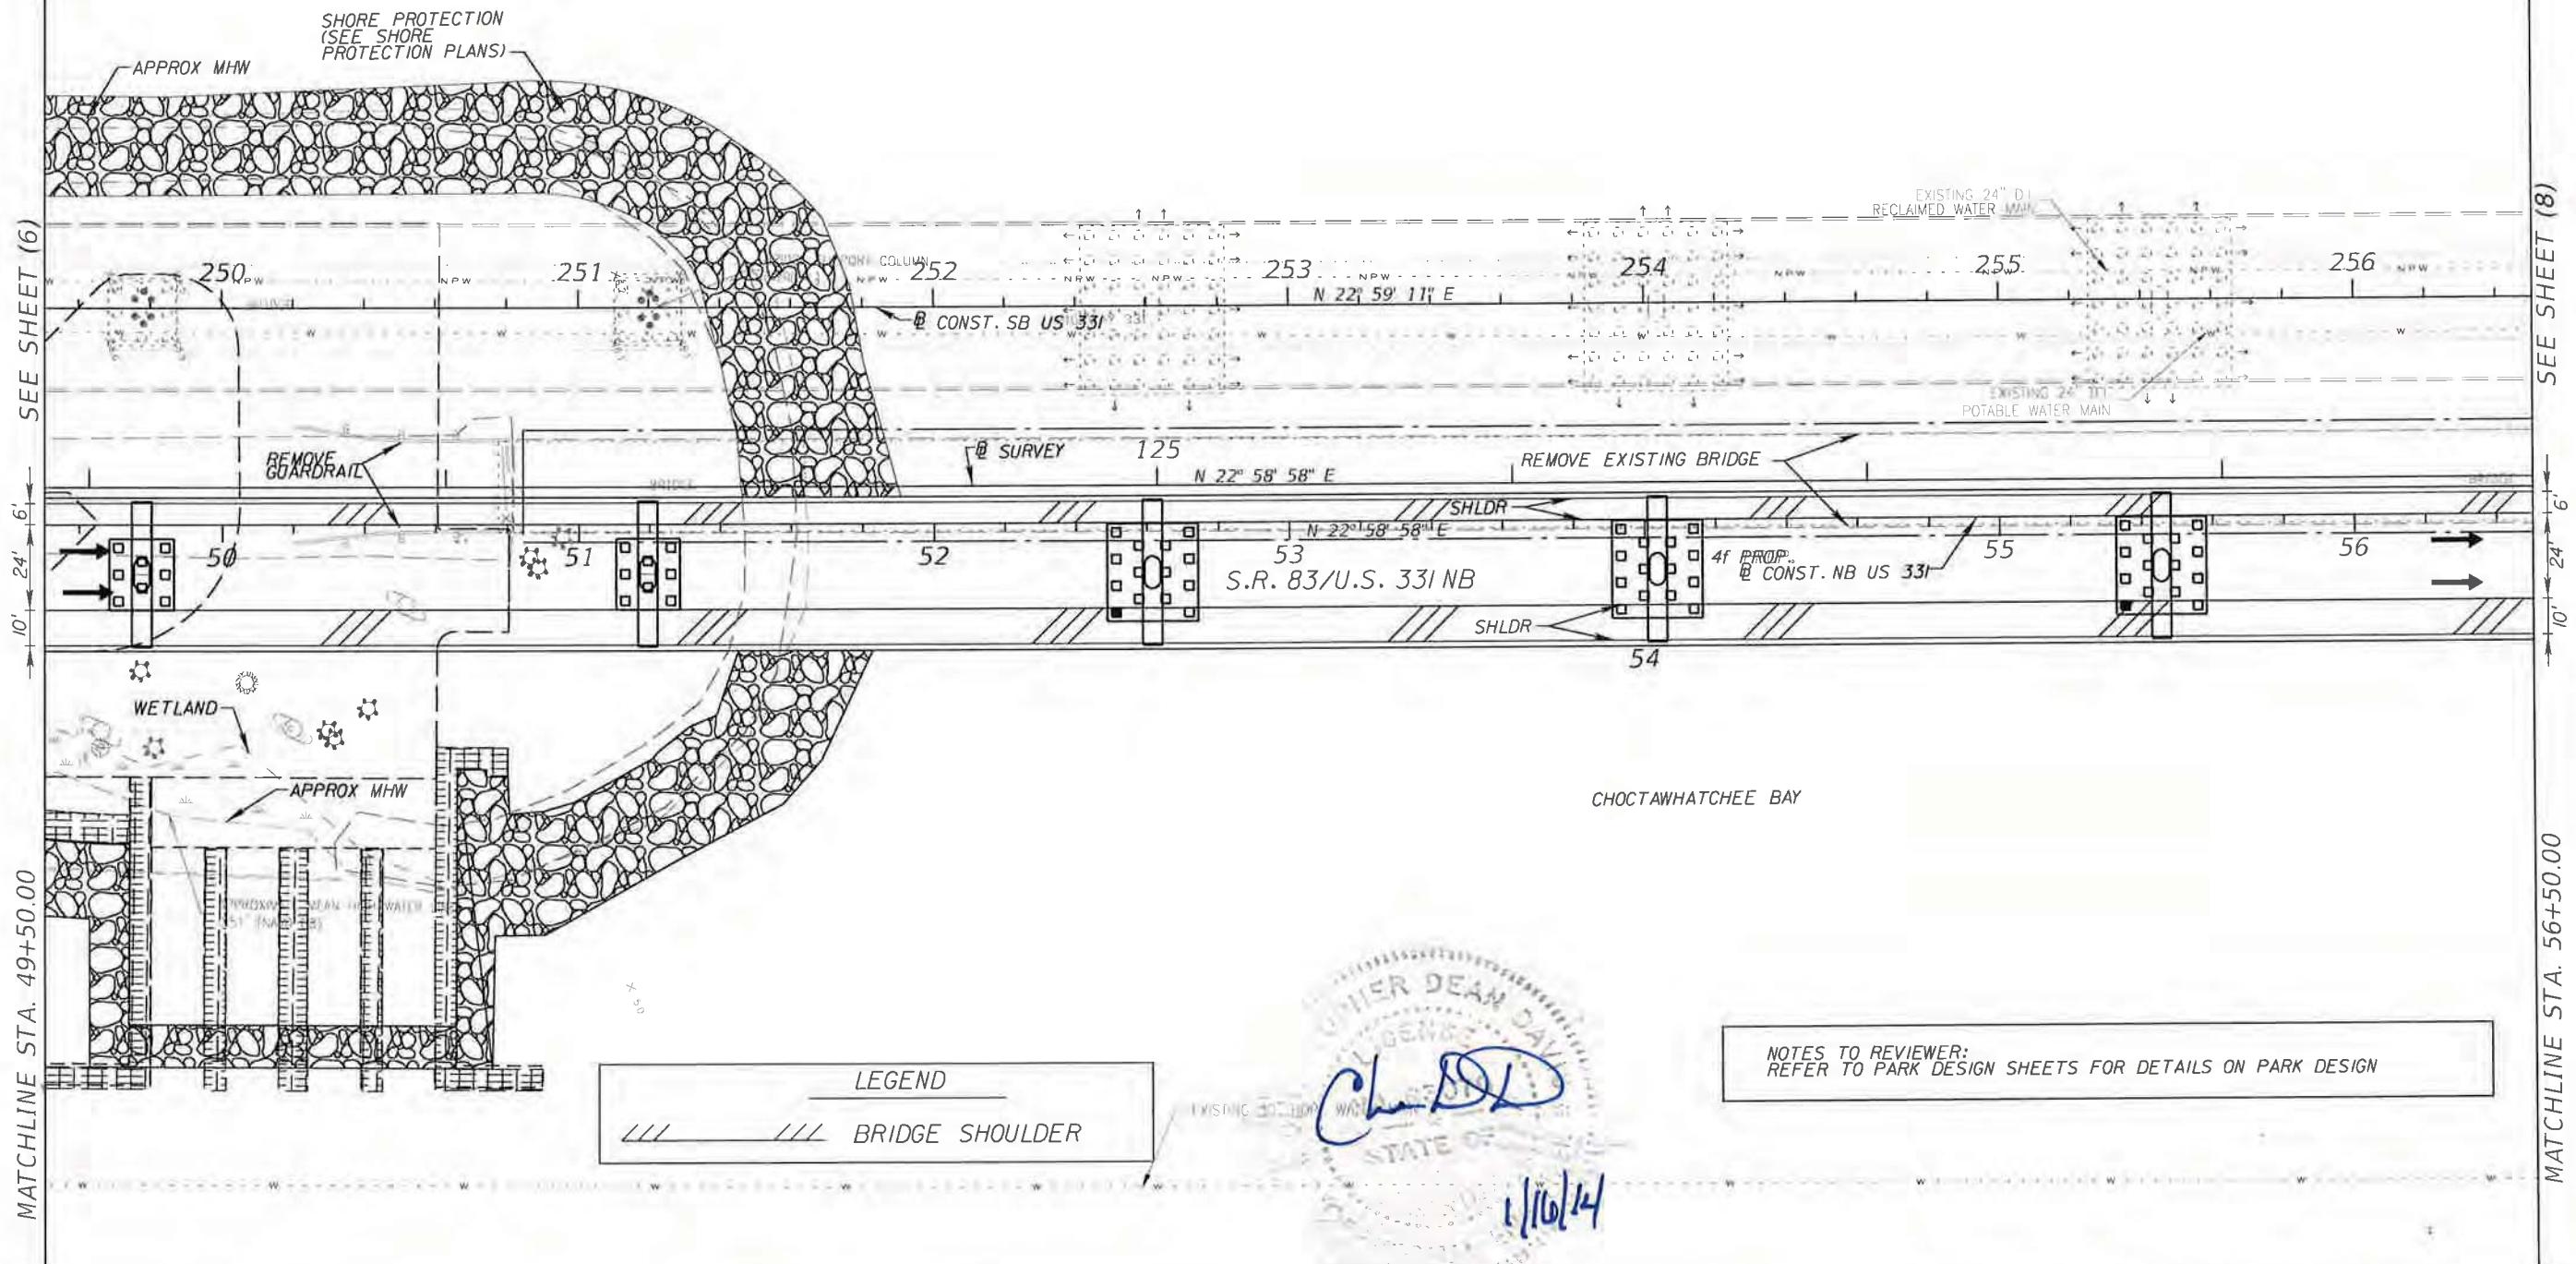


REVISIONS				Parsons Brinckerhoff, Inc. 121 W. Trade Street, Suite 1950 Charlotte, NC 28202 (704) 342-8469 Cert. of Auth. No. 01462 EOR: Christopher D Davis, P.E. No. 63070	STATE OF FLORIDA DEPARTMENT OF TRANSPORTATION	PLAN (7)	SHEET NO.
DATE	DESCRIPTION	DATE	DESCRIPTION				31
				83	WALTON	220664-2-52-01	



SCALE: 1"=50'

SEE SHEET (21)

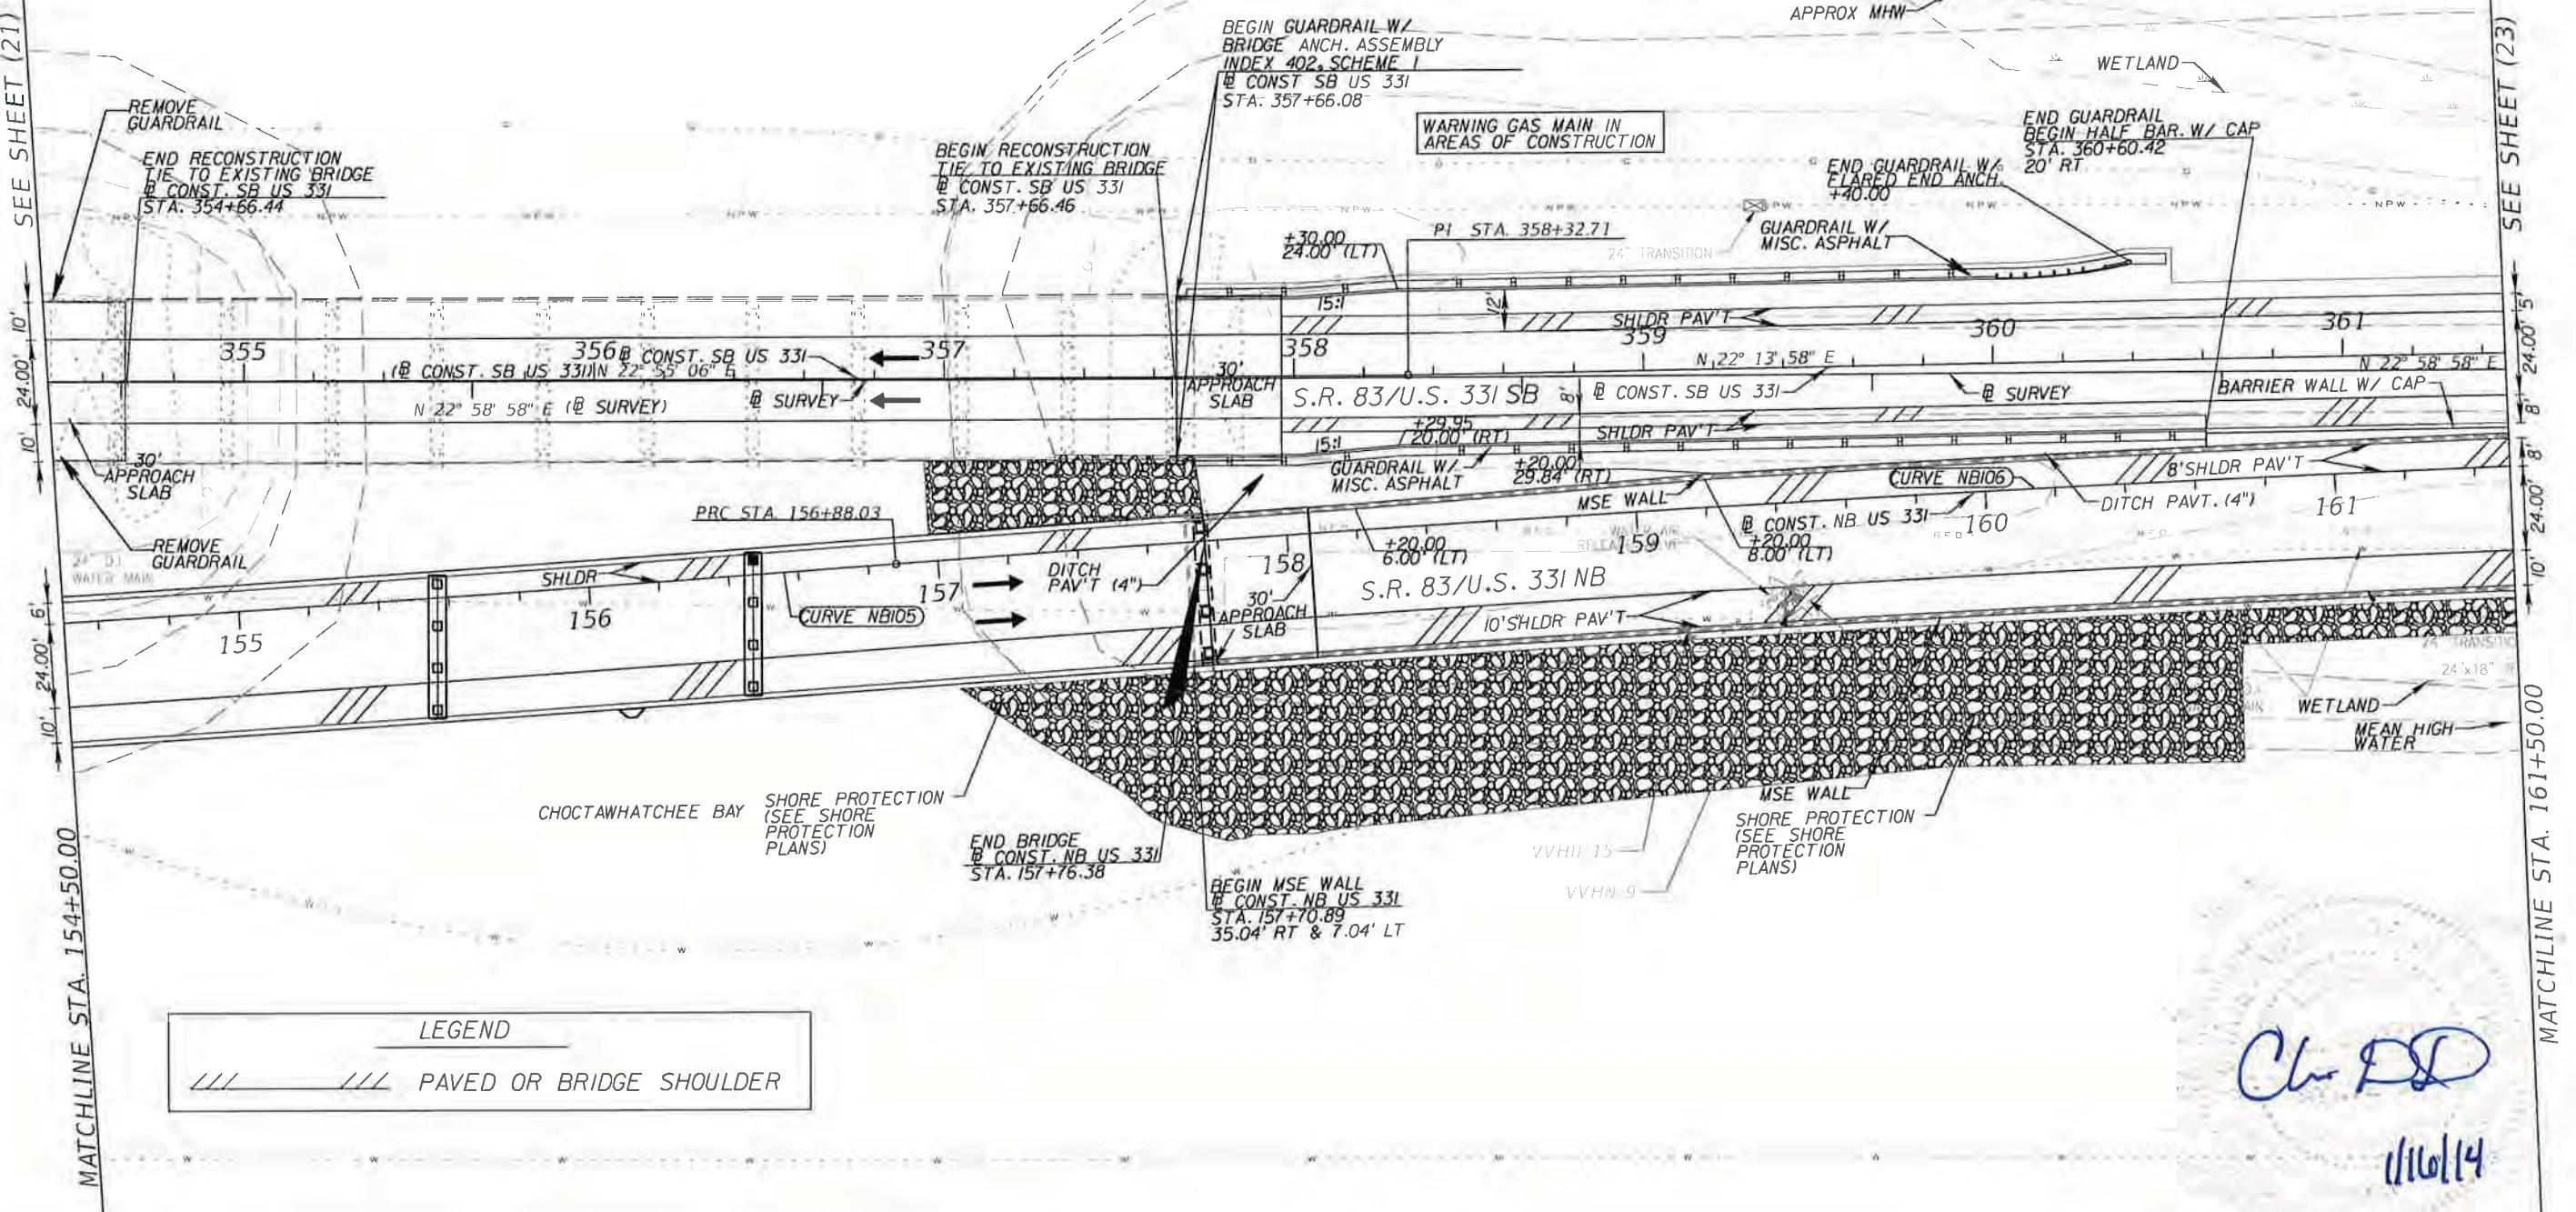

DATE	DESCRIPTION	DATE	DESCRIPTION	Parsons Brinckerhoff, Inc. 121 W. Trade Street, Suite 1950 Charlotte, NC 28202 (704) 342-8469 Cert. of Auth. No. 01462 EOR: Christopher D Davis, P.E. No. 63070	STATE OF FLORIDA DEPARTMENT OF TRANSPORTATION	ROAD NO.	COUNTY	FINANCIAL PROJECT ID	SHEET NO.
					83	WALTON	220664-2-52-01	46	




SCALE: 1"=50'

SEE SHEET (22)

24.00' 5'

MATCHLINE STA. 161+50.00

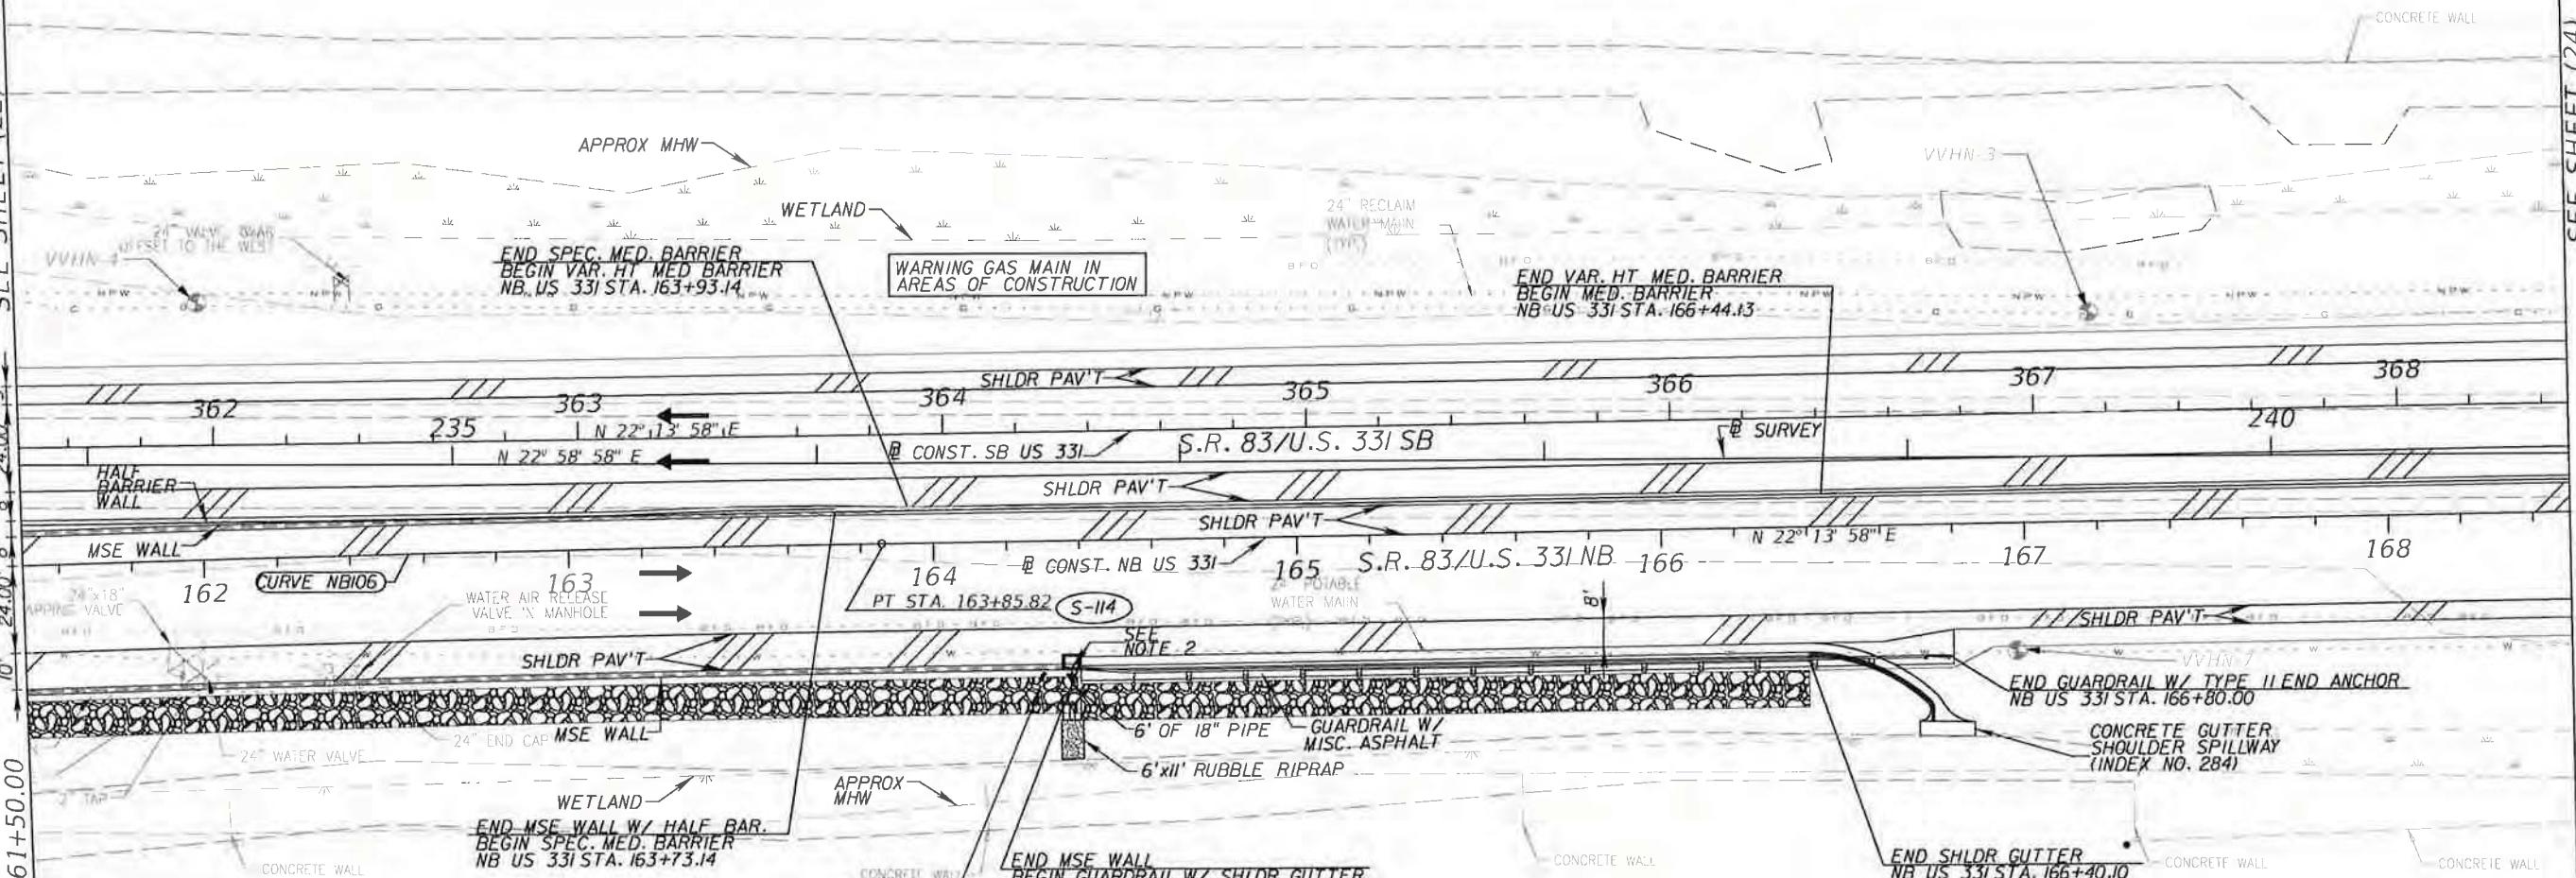

SEE SHEET (24)

MATCHLINE STA. 168+50.00

1/16/14

NOTES: 1. FOR SPECIAL MEDIAN BARRIER DESIGN, SEE RETAINING WALL PLANS  
2. FOR MSE WALL TRAFFIC RAILING DETAILS ADJACENT TO DRAINAGE STRUCTURES, REFER TO INDEX 6201.

REVISIONS			
DATE	DESCRIPTION	DATE	DESCRIPTION

Parsons Brinckerhoff, Inc.  
121 W. Trade Street, Suite 1950  
Charlotte, NC 28202  
(704) 342-8469  
Cert. of Auth. No. 01462  
EOR: Christopher D Davis, P.E. No. 63070

STATE OF FLORIDA  
DEPARTMENT OF TRANSPORTATION

ROAD NO.	COUNTY	FINANCIAL PROJECT ID
83	WALTON	220664-2-52-01

PLAN (23)

SHEET NO.

47



18  
16  
14  
12  
10  
8  
6  
4  
2  
0  
-2

18  
16  
14  
12  
10  
8  
6  
4  
2  
0  
-2

EXIST. SEAWALL

PROP. SS  
36° WAT 0 10° GAS  
FD.  
30° NPW

SEAH. 1/14/14

B SB33I  
STA. 221+39.80  
6.77

SEAH. 1/14/14

B NB33I  
STA. 221+00.00  
7.23

SEAH. 1/14/14

B NB33I  
STA. 221+50.00  
7.38

SEAH. 1/14/14

B NB33I  
STA. 221+50.00  
7.38

EXIST. SEAWALL  
MMW 0.67  
22+00.00

18  
16  
14  
12  
10  
8  
6  
4  
2  
0  
-2

18  
16  
14  
12  
10  
8  
6  
4  
2  
0  
-2

EXIST. SEAWALL

PROP. SS  
36° WAT 0 10° GAS  
FD.  
30° NPW

SEAH. 1/14/14

B SB33I  
STA. 221+49.79  
6.92

SEAH. 1/14/14

B NB33I  
STA. 21+50.00  
7.38

SEAH. 1/14/14

B NB33I  
STA. 21+50.00  
7.38

EXIST. SEAWALL  
MMW 0.67  
21+50.00

CD  
1/16/14

SCALE  
1" = 20' Horizontal  
1" = 10' Vertical

180 160 140 120 100 80 60 40 20 0 20 40 60 80 100

REVISIONS

DATE	DESCRIPTION	DATE	DESCRIPTION

Parsons Brinckerhoff, Inc.  
121 W. Trade Street, Suite 1950  
Charlotte, NC 28202  
(704) 342-8469  
Cert. of Auth. No. 01462  
EOR: Christopher D Davis, P.E. No. 63070

STATE OF FLORIDA  
DEPARTMENT OF TRANSPORTATION  
ROAD NO. COUNTY FINANCIAL PROJECT ID  
83 WALTON 220664-2-52-01

CROSS SECTIONS


SHEET NO.  
127



66-0274274-010-EL  
PERMIT


18  
16  
14  
12  
10  
8  
6  
4  
2  
0  
-2

EXIST. SEAWALL

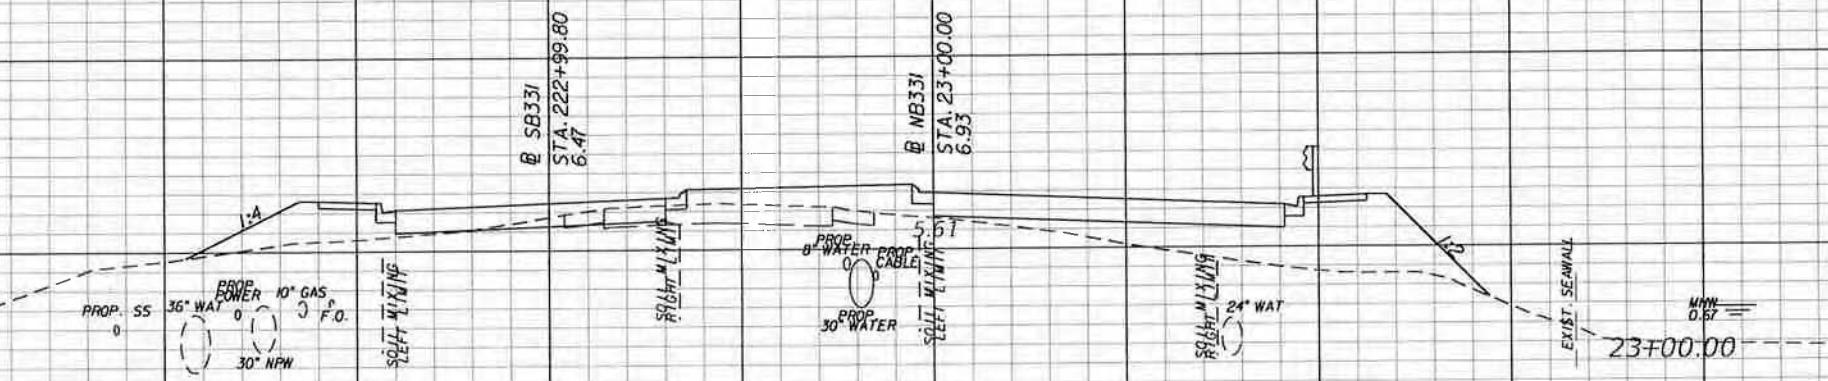

18  
16  
14  
12  
10  
8  
6  
4  
2  
0  
-2

EXIST. SEAWALL

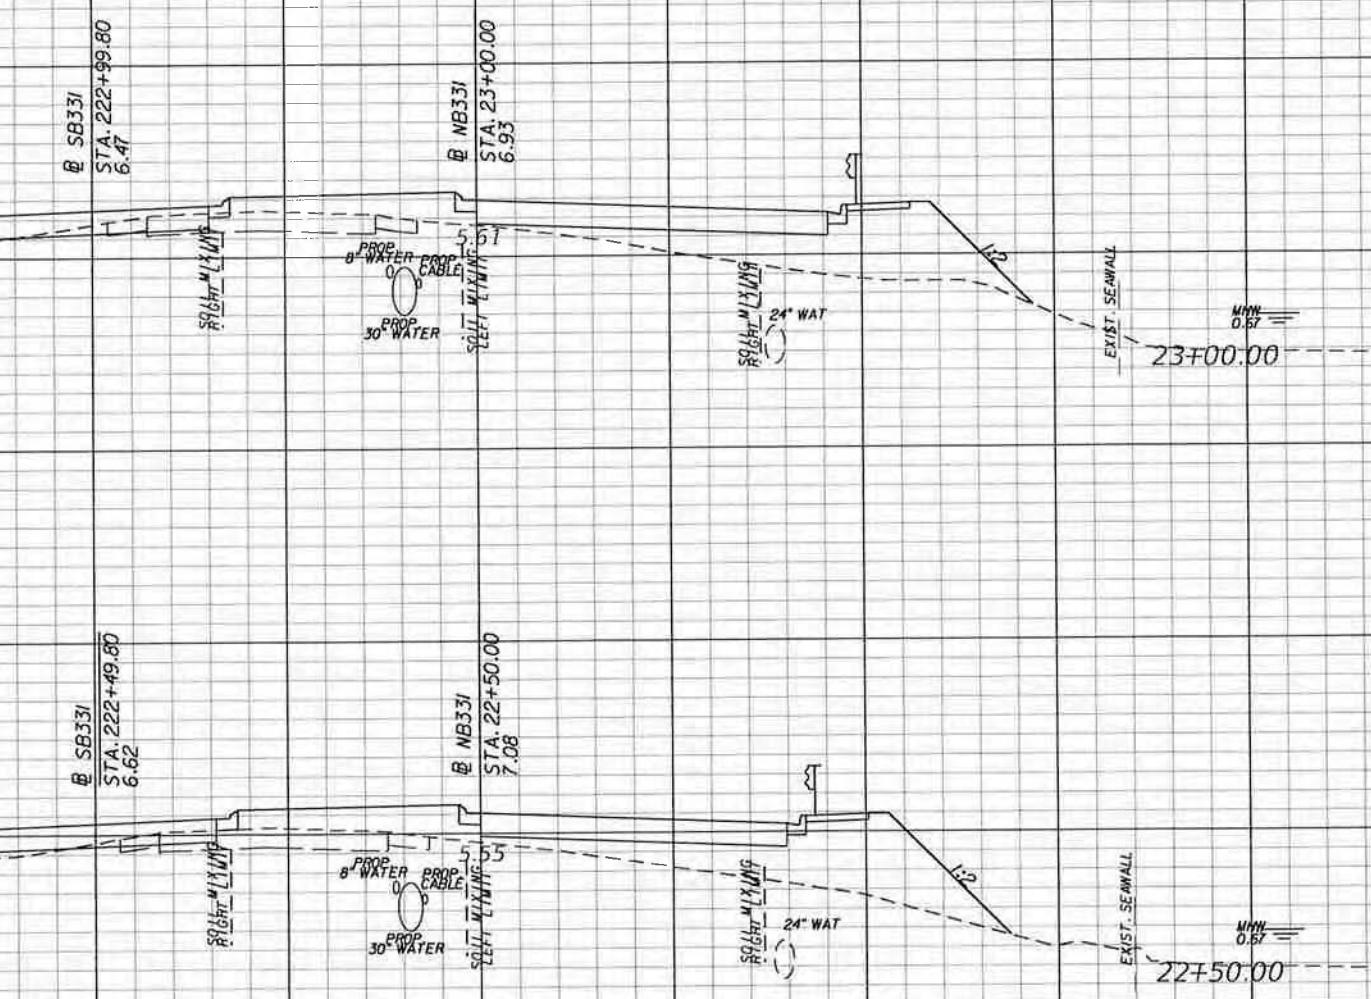

180 160 140 120 100 80 60 40 20 0 20 40 60 80 100

*CD*  
1/16/14

SCALE  
1" = 20' Horizontal  
1" = 10' Vertical

REVISIONS'			
DATE	DESCRIPTION	DATE	DESCRIPTION

Parsons Brinckerhoff, Inc.  
121 W. Trade Street, Suite 1950  
Charlotte, NC 28202  
(704) 342-8469  
Cert. of Auth. No. 01462  
EOR: Christopher D Davis, P.E. No. 63070

STATE OF FLORIDA  
DEPARTMENT OF TRANSPORTATION

ROAD NO.	COUNTY	FINANCIAL PROJECT ID
83	WALTON	220664-2-52-01

CROSS SECTIONS

SHEET NO.  
128



18  
16  
14  
12  
10  
8  
6  
4  
2  
0  
-2

18  
16  
14  
12  
10  
8  
6  
4  
2  
0  
-2

EXIST. SEAWALL

PROP. SS 0  
36° WAT 0 F.O.  
30° NPW

LEFT MIXING

@ SB33I  
STA. 223+49.8I  
6.47

RIGHT MIXING

@ NB33I  
STA. 24+00.00  
6.93

PROP. SS 0  
30° WAT

RIGHT MIXING

EXIST. SEAWALL  
MMW 0.67  
24+00.00

18  
16  
14  
12  
10  
8  
6  
4  
2  
0  
-2

18  
16  
14  
12  
10  
8  
6  
4  
2  
0  
-2

EXIST. SEAWALL

PROP. SS 36° WAT 0 F.O.  
30° NPW

LEFT MIXING

@ SB33I  
STA. 223+49.8I  
6.32

RIGHT MIXING

@ NB33I  
STA. 23+50.00  
6.78

PROP. SS 0  
30° WAT

RIGHT MIXING

EXIST. SEAWALL  
MMW 0.67  
23+50.00

CH  
1/16/14

SCALE  
1" = 20' Horizontal  
1" = 10' Vertical

180 160 140 120 100 80 60 40 20 0 20 40 60 80 100


REVISIONS			
DATE	DESCRIPTION	DATE	DESCRIPTION

Parsons Brinckerhoff, Inc.  
121 W. Trade Street, Suite 1950  
Charlotte, NC 28202  
(704) 342-8469  
Cert. of Auth. No. 01462  
EOR: Christopher D Davis, P.E. No. 63070


STATE OF FLORIDA  
DEPARTMENT OF TRANSPORTATION  
ROAD NO. COUNTY FINANCIAL PROJECT ID  
83 WALTON 220664-2-52-01

CROSS SECTIONS

SHEET NO.  
129

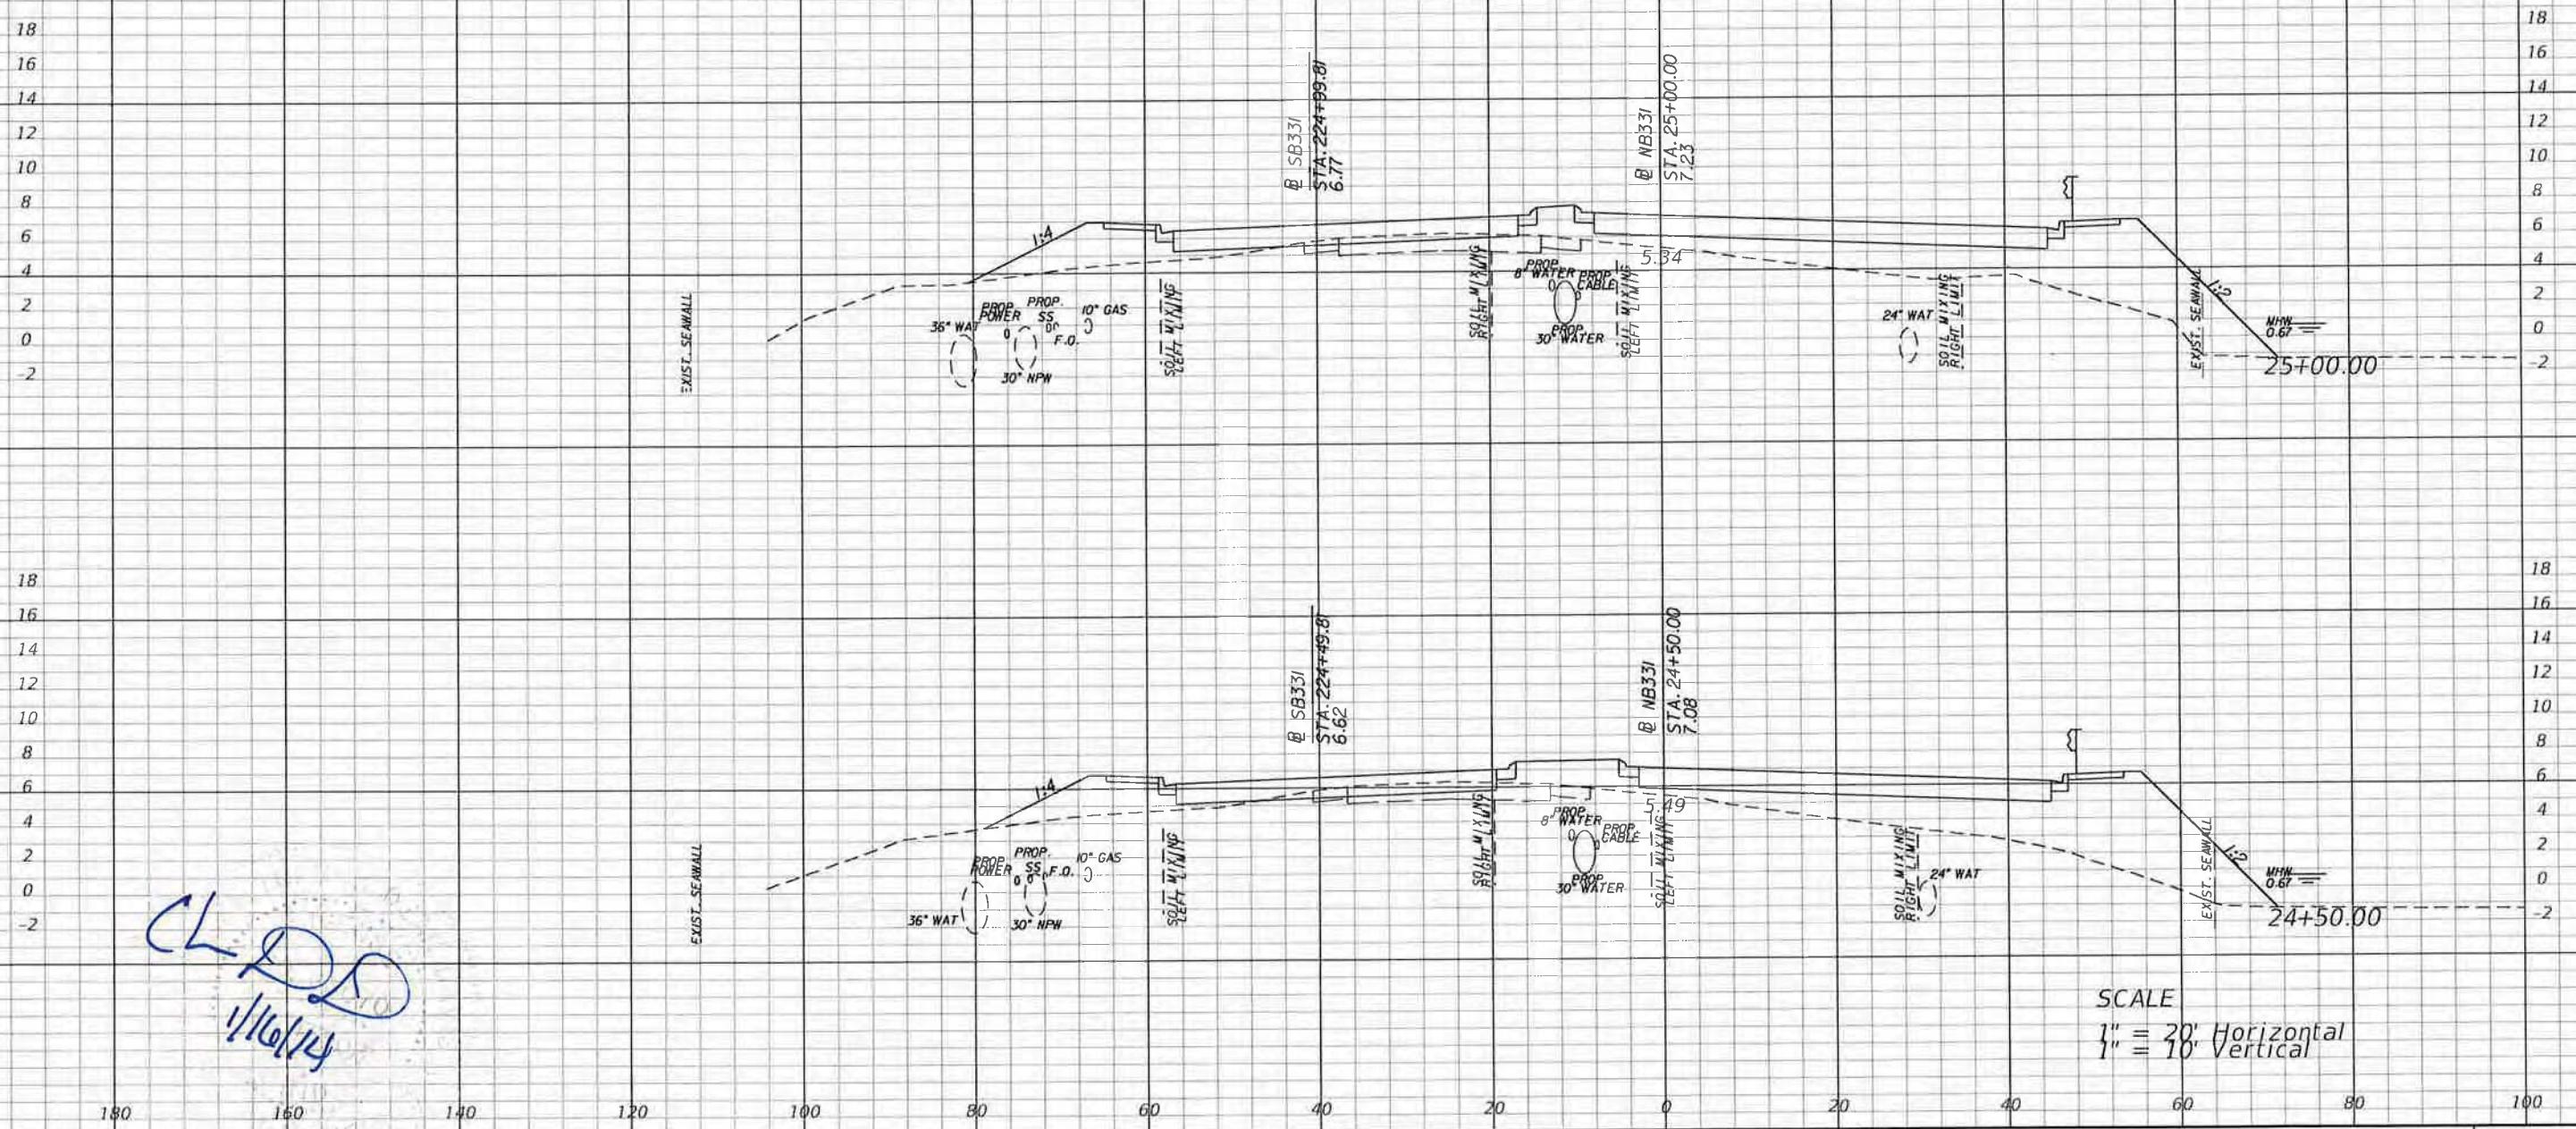

REVISIONS		Parsons Brinckerhoff, Inc. 121 W. Trade Street, Suite 1950 Charlotte, NC 28202 (704) 342-8469 Cert. of Auth. No. 01462 EOR: Christopher D Davis, P.E. No. 63070			STATE OF FLORIDA DEPARTMENT OF TRANSPORTATION			CROSS SECTIONS		SHEET NO.
DATE	DESCRIPTION	DATE	DESCRIPTION	ROAD NO.	COUNTY	FINANCIAL PROJECT ID				130
				83	WALTON	220664-2-52-01	davisch	1/16/2014	1:45:58 PM	T:\projects\B3_Choctawhatchee_Bridge_DB\roadway\RDXSRD01.DGN

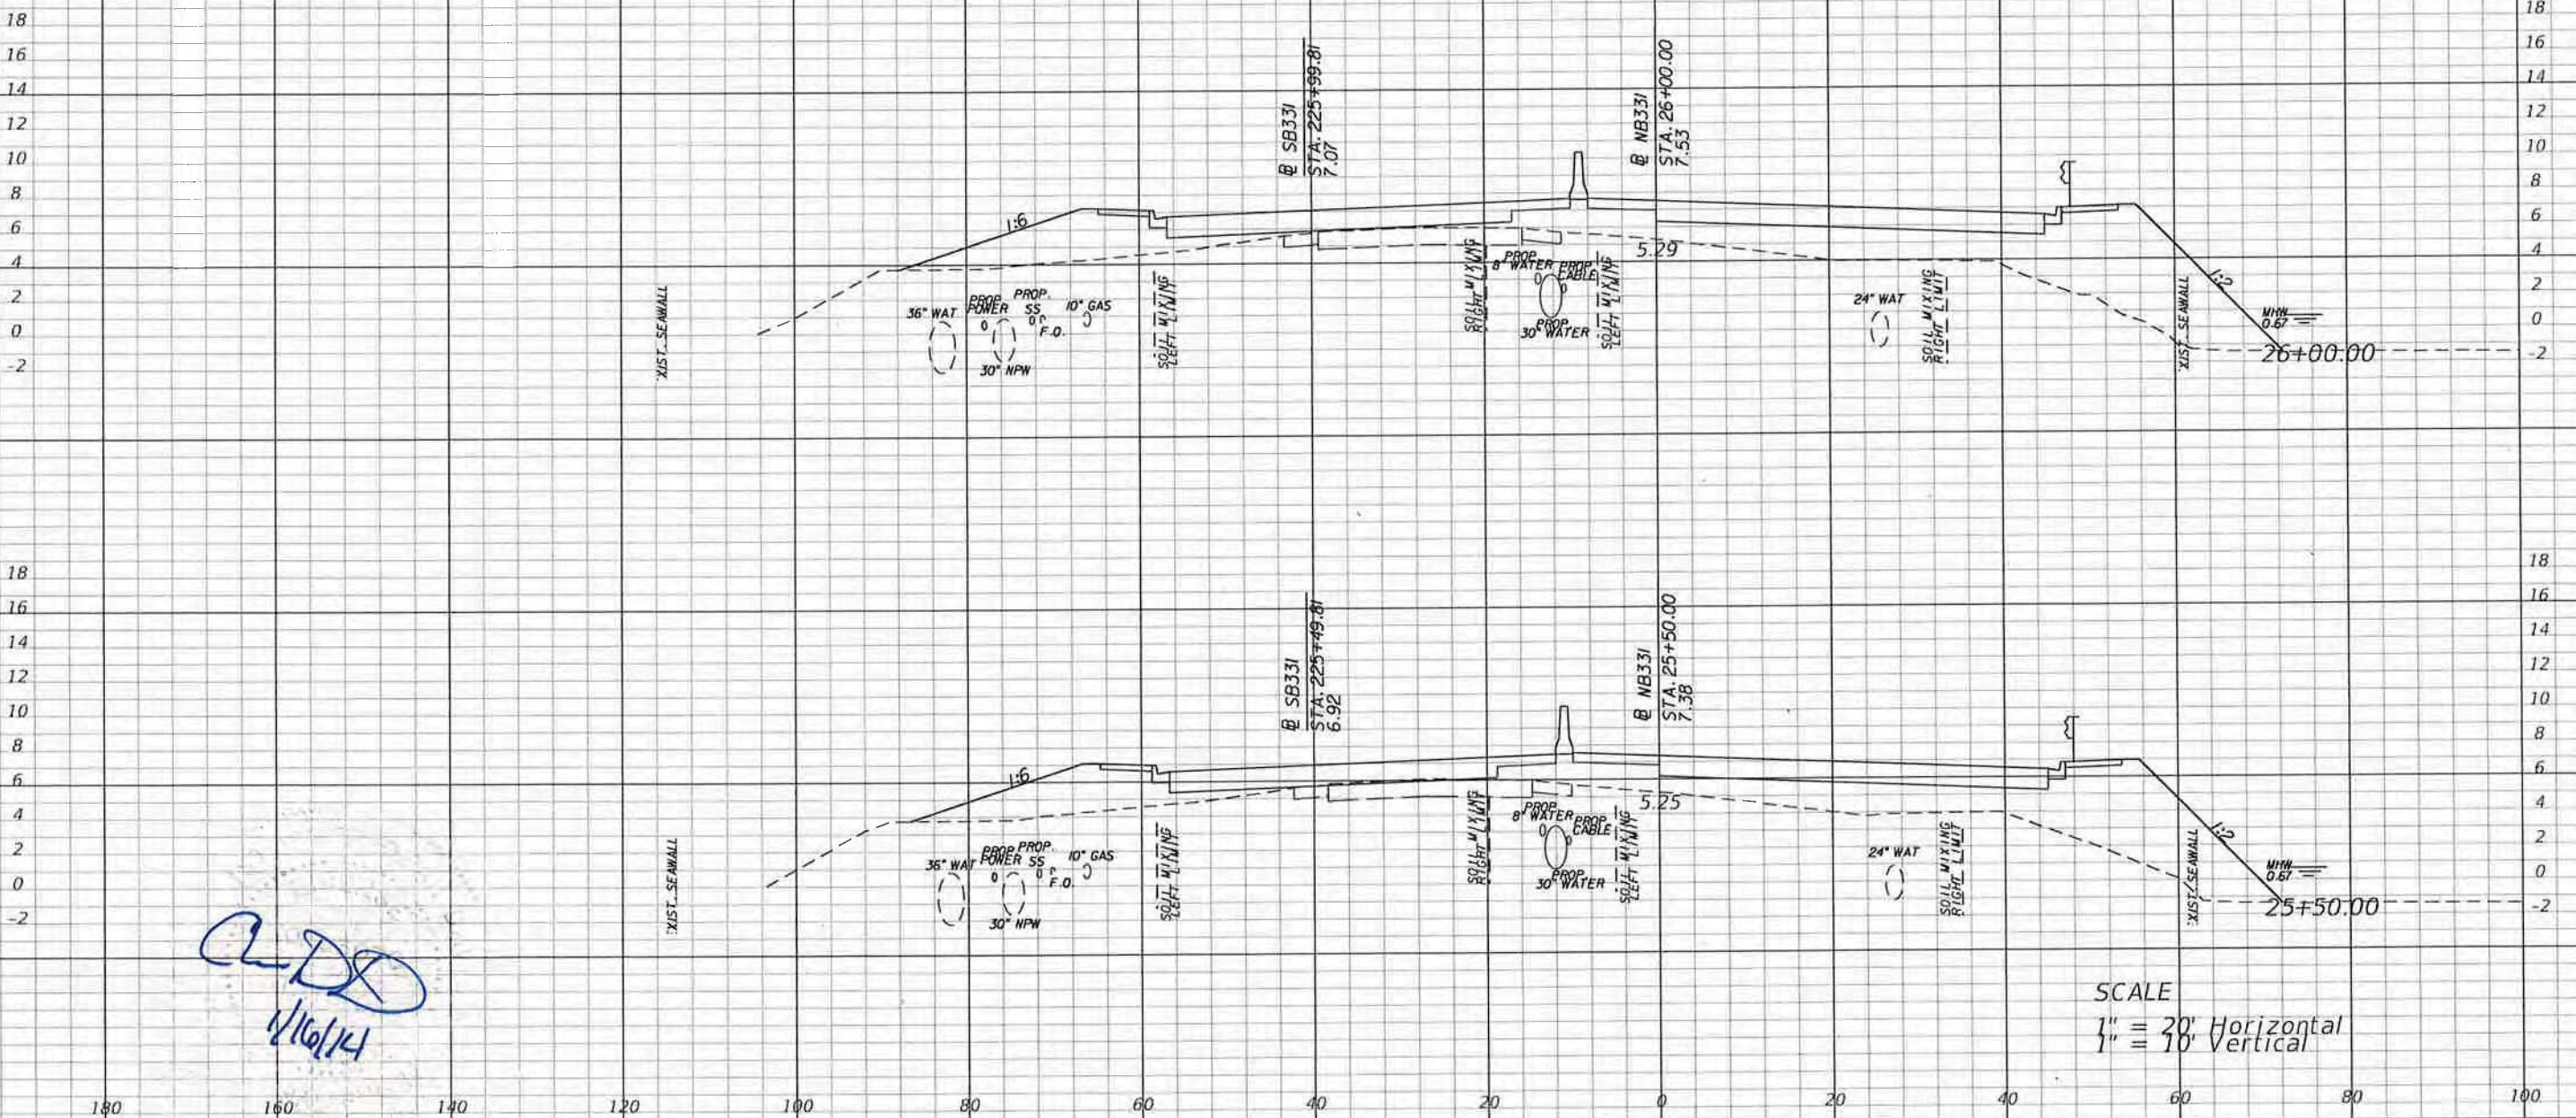

REVISIONS			
DATE	DESCRIPTION	DATE	DESCRIPTION

Parsons Brinckerhoff, Inc.  
121 W. Trade Street, Suite 1950  
Charlotte, NC 28202  
(704) 342-8469  
Cert. of Auth. No. 01462  
EOR: Christopher D Davis, P.E. No. 63070


STATE OF FLORIDA  
DEPARTMENT OF TRANSPORTATION  
ROAD NO. COUNTY FINANCIAL PROJECT ID  
83 WALTON 220664-2-52-01

### CROSS SECTIONS

SHEET NO.  
131



66-0274274-010-EL  
PERMIT

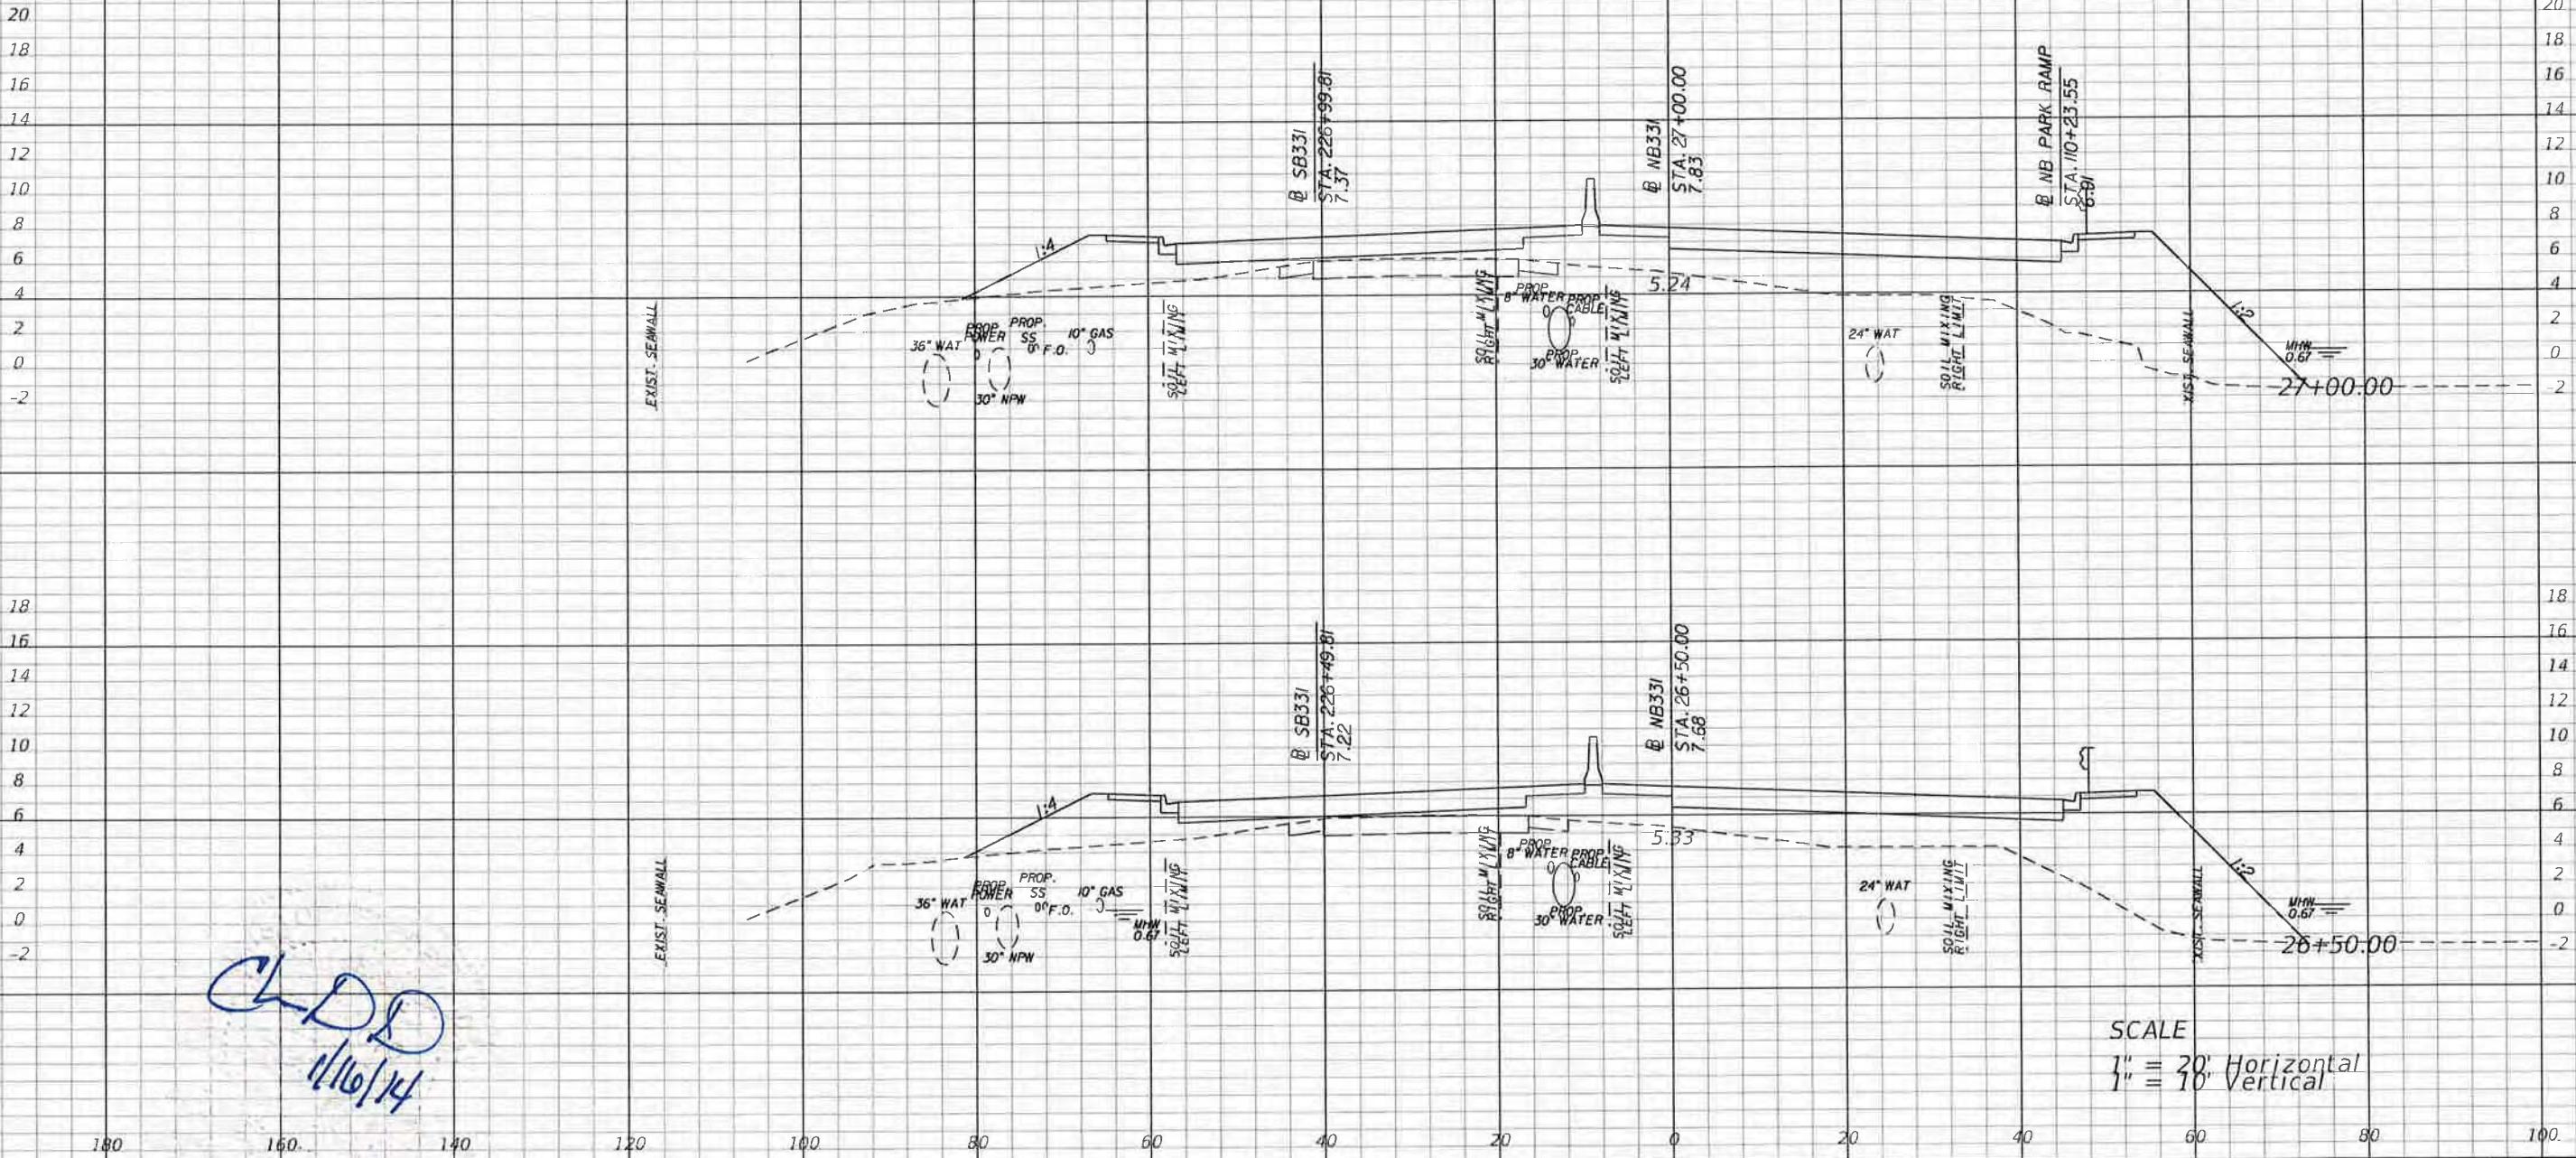

DATE	DESCRIPTION	DATE	DESCRIPTION



Parsons Brinckerhoff, Inc.  
121 W. Trade Street, Suite 1950  
Charlotte, NC 28202  
(704) 342-8469  
Cert. of Auth. No. 01462  
EOR: Christopher D Davis, P.E. No. 63070

STATE OF FLORIDA  
DEPARTMENT OF TRANSPORTATION




ROAD NO.	COUNTY	FINANCIAL PROJECT ID
83	WALTON	220664-2-52-01

CROSS SECTIONS

SHEET NO.  
132

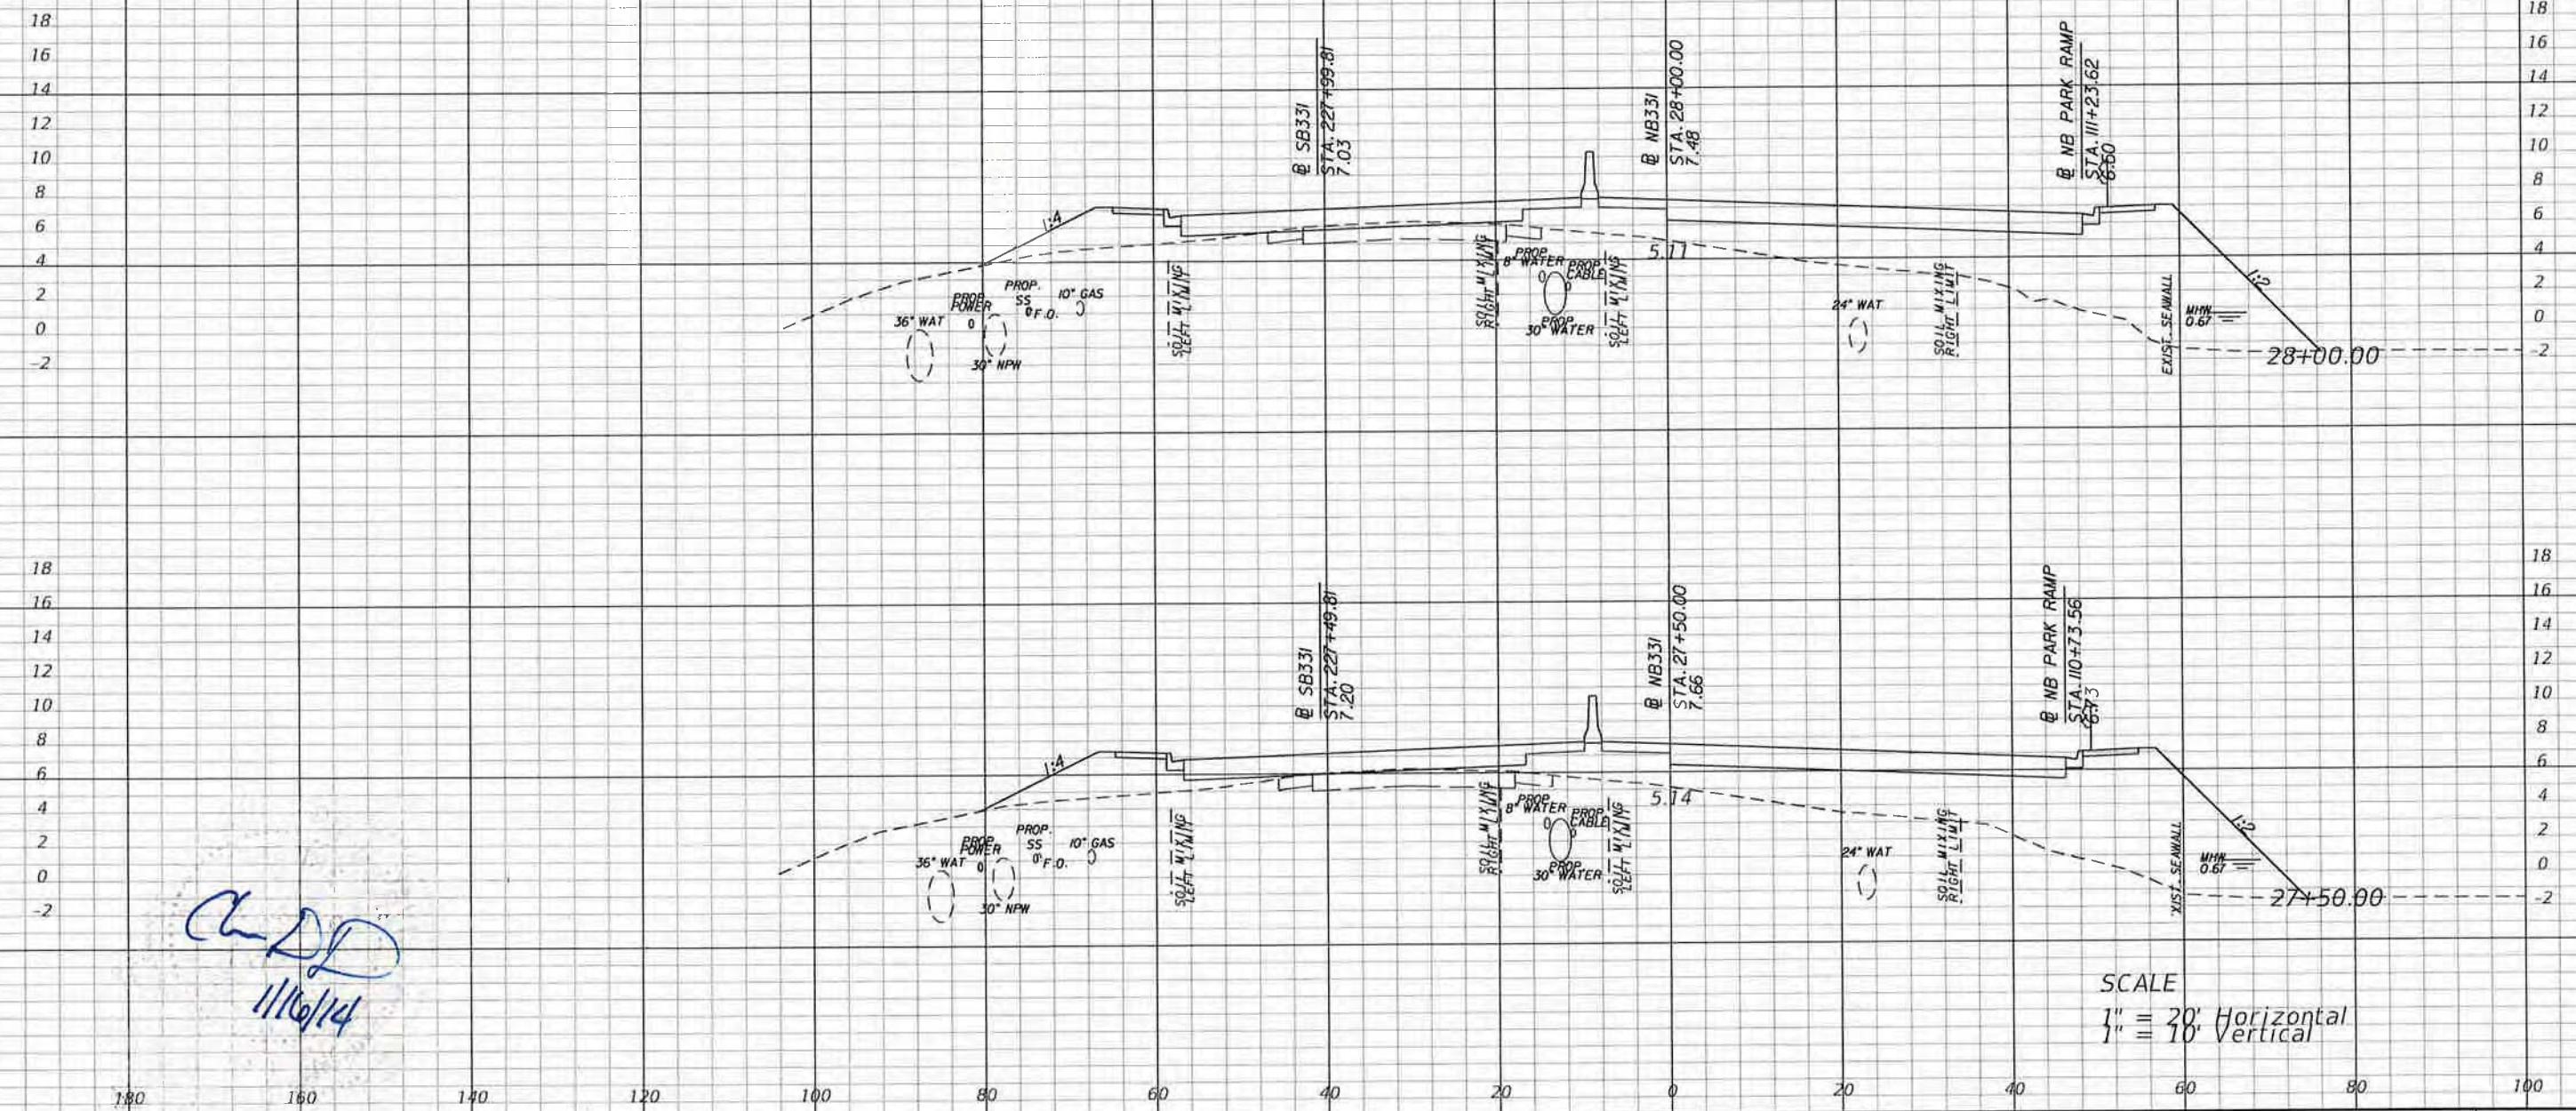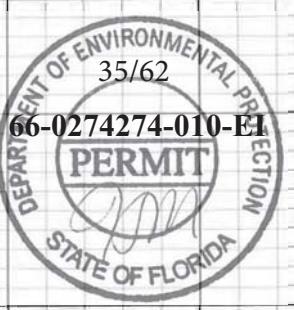

REVISIONS				STATE OF FLORIDA DEPARTMENT OF TRANSPORTATION			CROSS SECTIONS			SHEET NO.
DATE	DESCRIPTION	DATE	DESCRIPTION	ROAD NO.	COUNTY	FINANCIAL PROJECT ID				133
				83	WALTON	220664-2-52-01	davisch	1/16/2014	1:45:59 PM	T:\projects\d3_Cheetahatchee_Bridge_DB\roadway\RDXSRD01.DGN

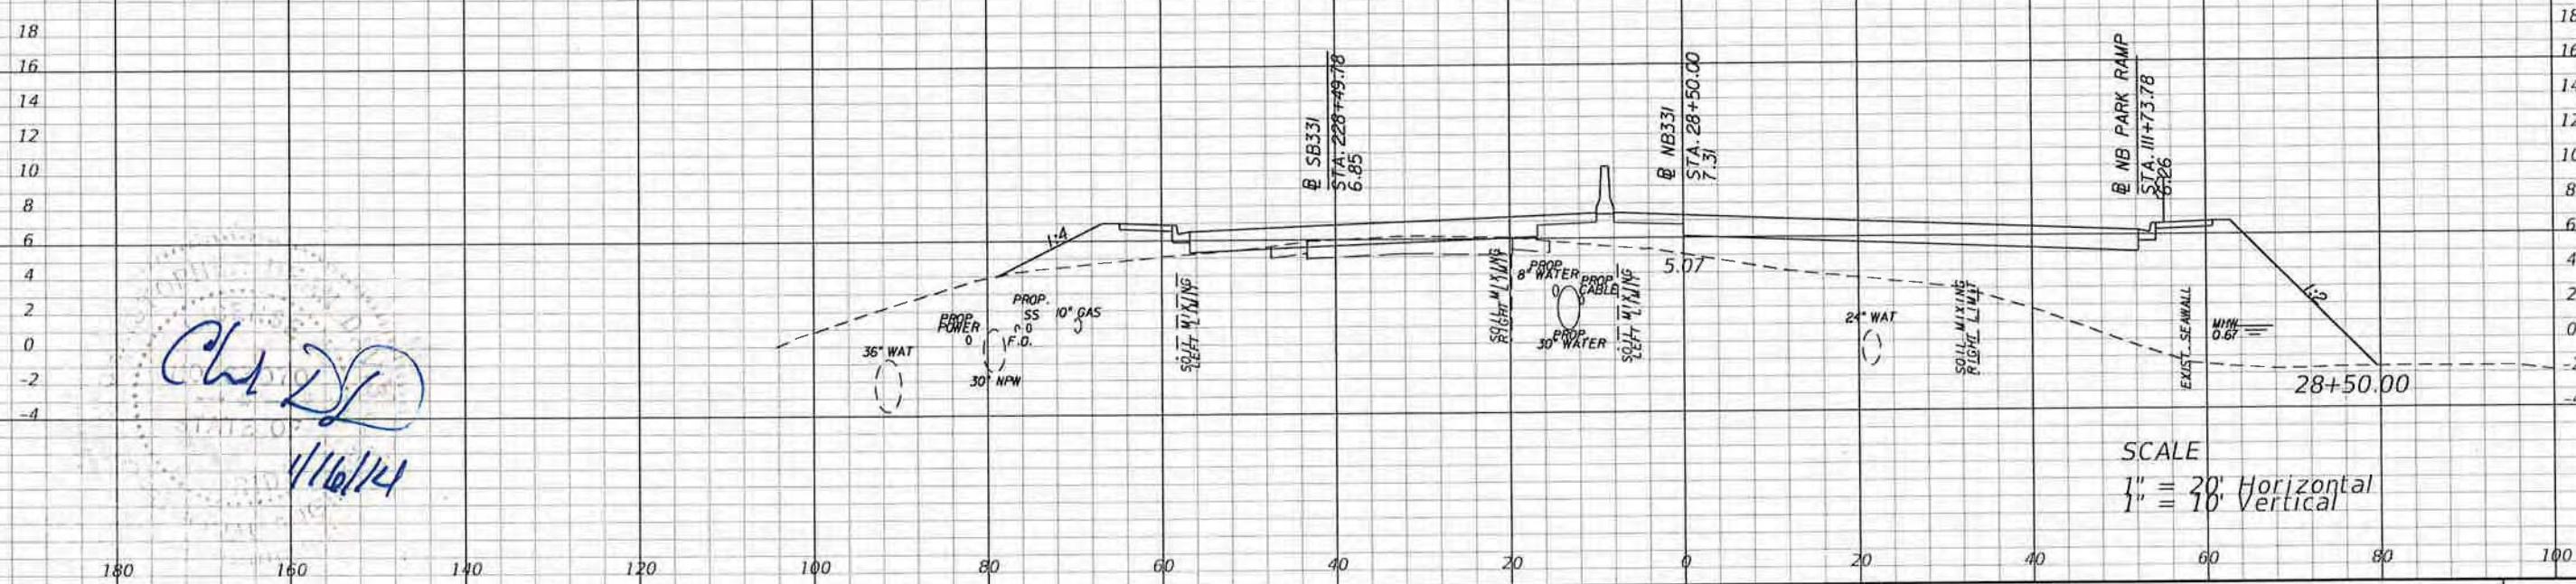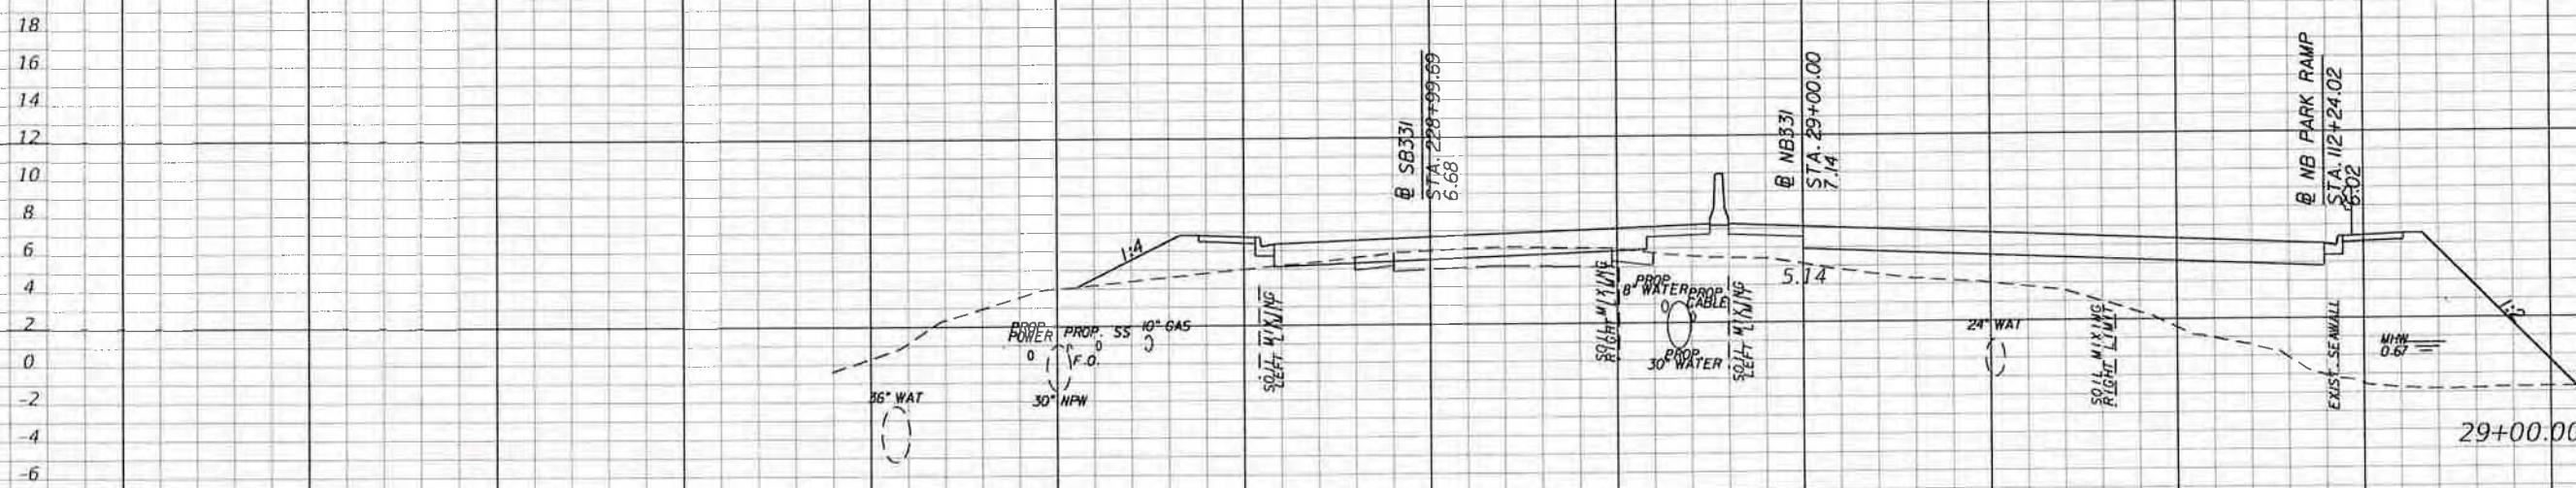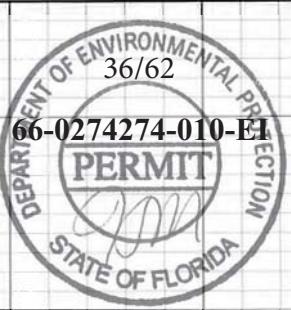


REVISIONS		Parsons Brinckerhoff, Inc. 121 W. Trade Street, Suite 1950 Charlotte, NC 28202 (704) 342-8469 Cert. of Auth. No. 01462 EOR: Christopher D Davis, P.E. No. 63070			STATE OF FLORIDA DEPARTMENT OF TRANSPORTATION			CROSS SECTIONS
DATE	DESCRIPTION	DATE	DESCRIPTION	ROAD NO.	COUNTY	FINANCIAL PROJECT ID		
				83	WALTON	220664-2-52-01		
davisch	1/16/2014	1:45:59 PM	T:\projects\D3_Chestatee_Bridge_DB\roadway\RDXSRD01.DGN	134				



66-0274274-010-EL

PERMIT

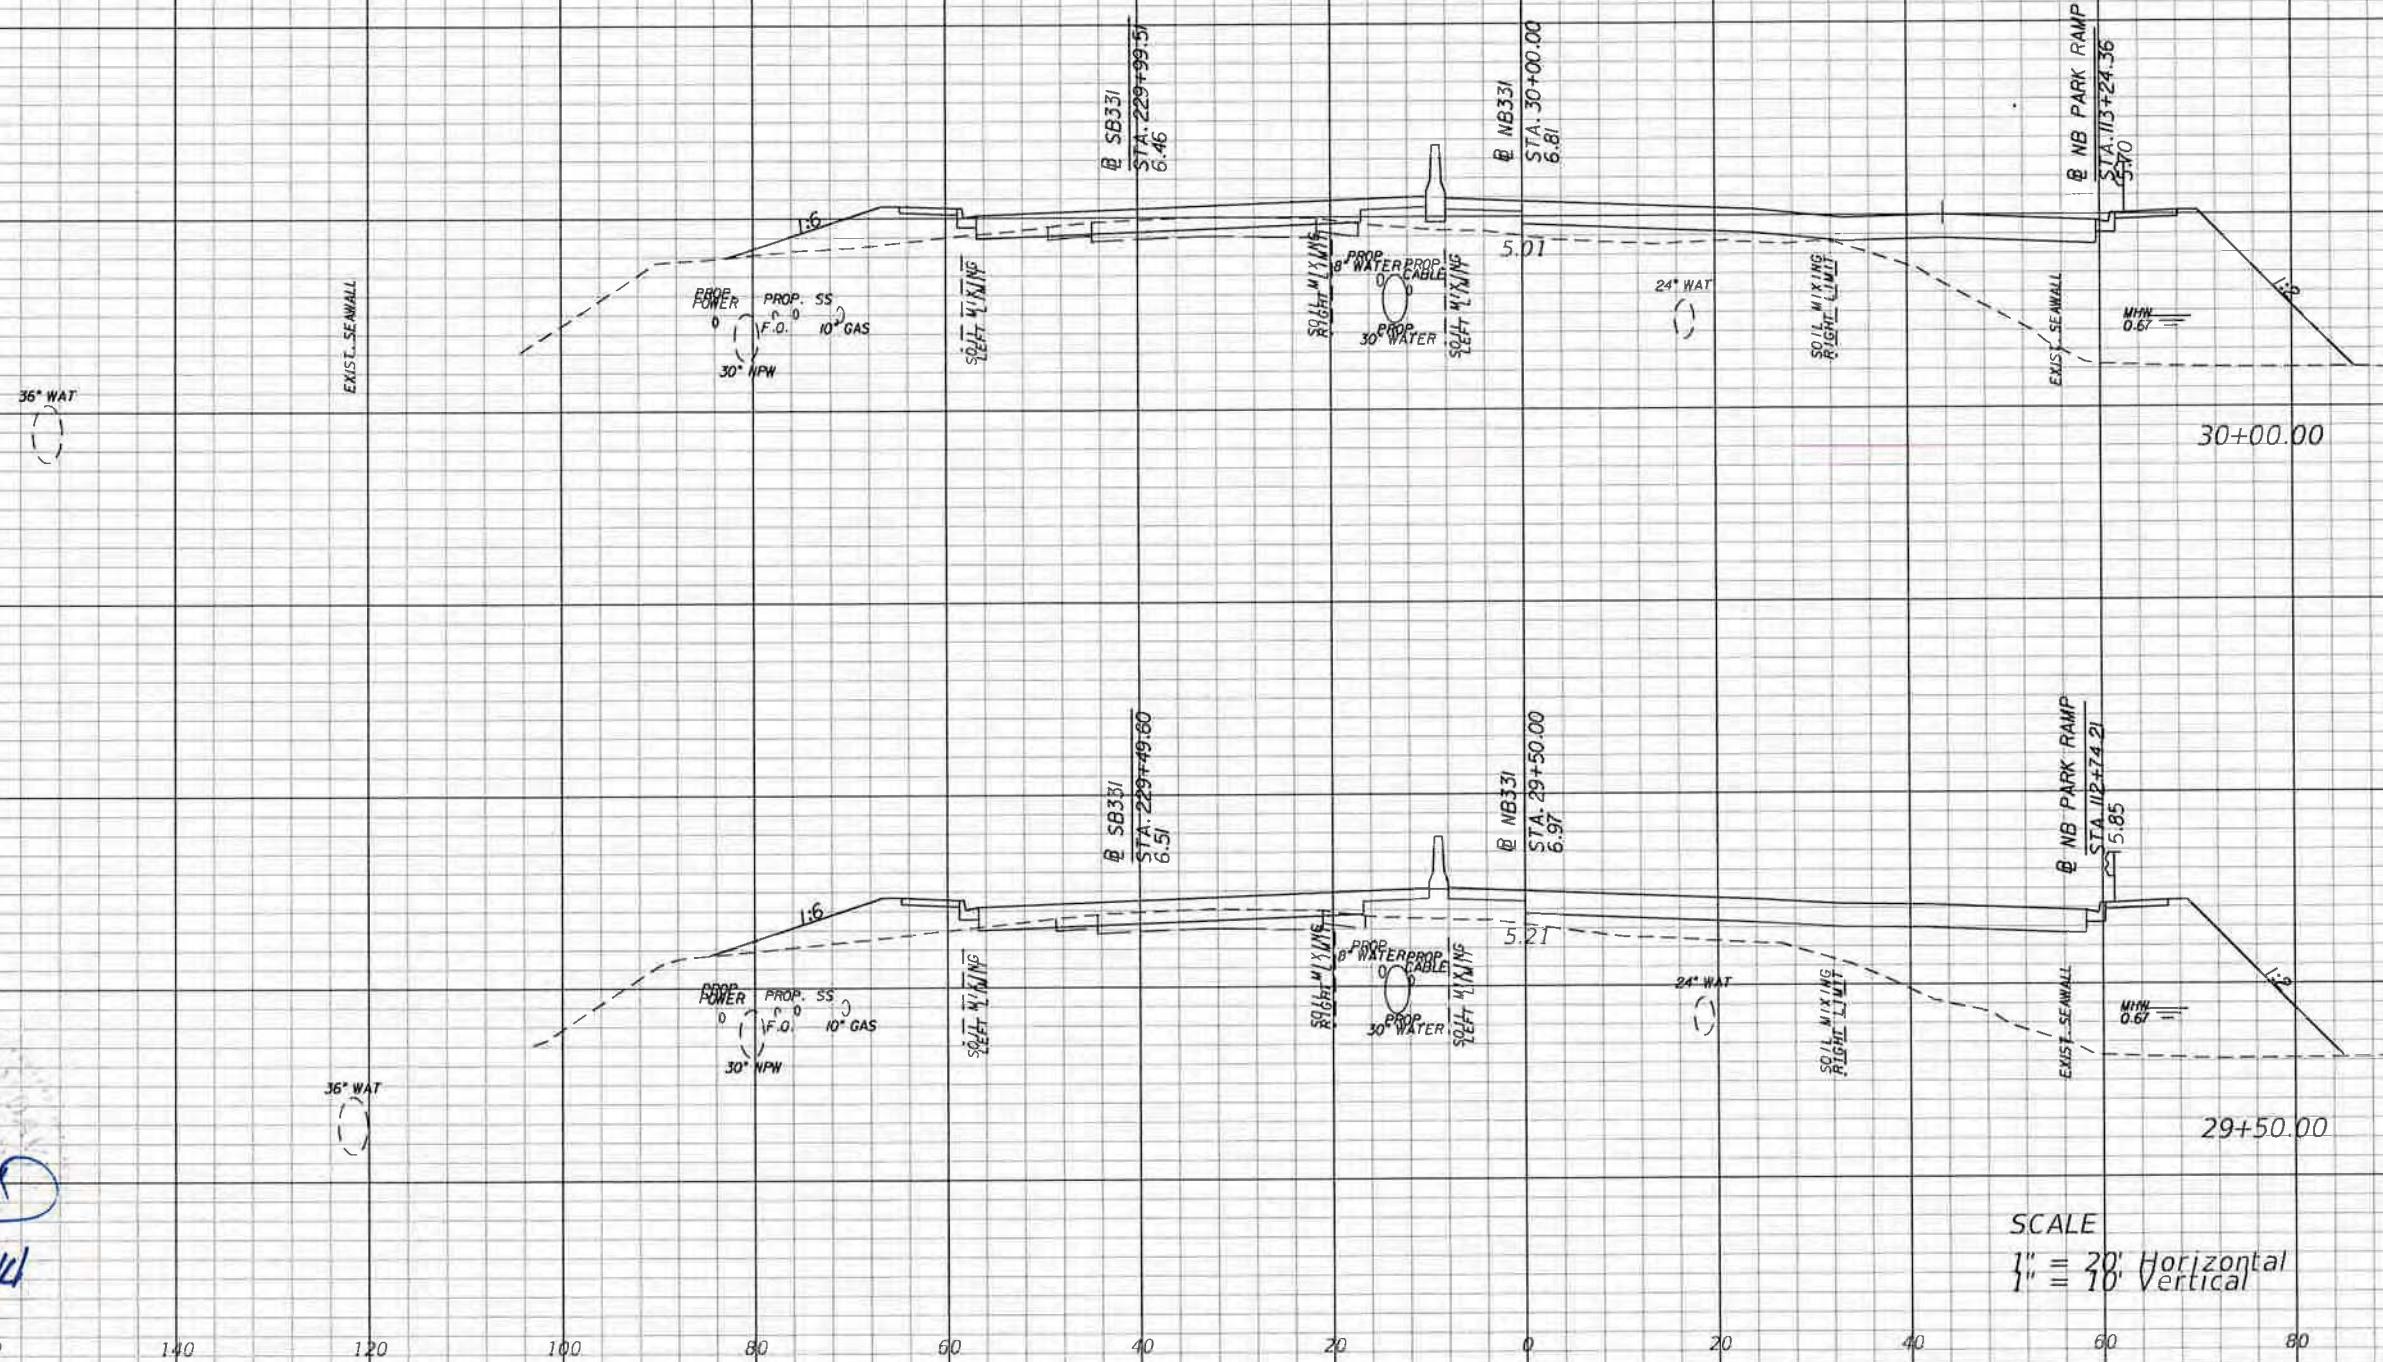

REVISIONS

DATE	DESCRIPTION	DATE	DESCRIPTION

Parsons Brinckerhoff, Inc.  
121 W. Trade Street, Suite 1950  
Charlotte, NC 28202  
(704) 342-8469  
Cert. of Auth. No. 01462  
EOR: Christopher D Davis, P.E. No. 63070

STATE OF FLORIDA  
DEPARTMENT OF TRANSPORTATION  
ROAD NO. COUNTY FINANCIAL PROJECT ID  
83 WALTON 220664-2-52-01

CROSS SECTIONS

SHEET NO.

135




66-0274274-010-EL

18  
16  
14  
12  
10  
8  
6  
4  
2  
0  
-2  
-4

18  
16  
14  
12  
10  
8  
6  
4  
2  
0  
-2  
-4

EXIST. SEAWALL

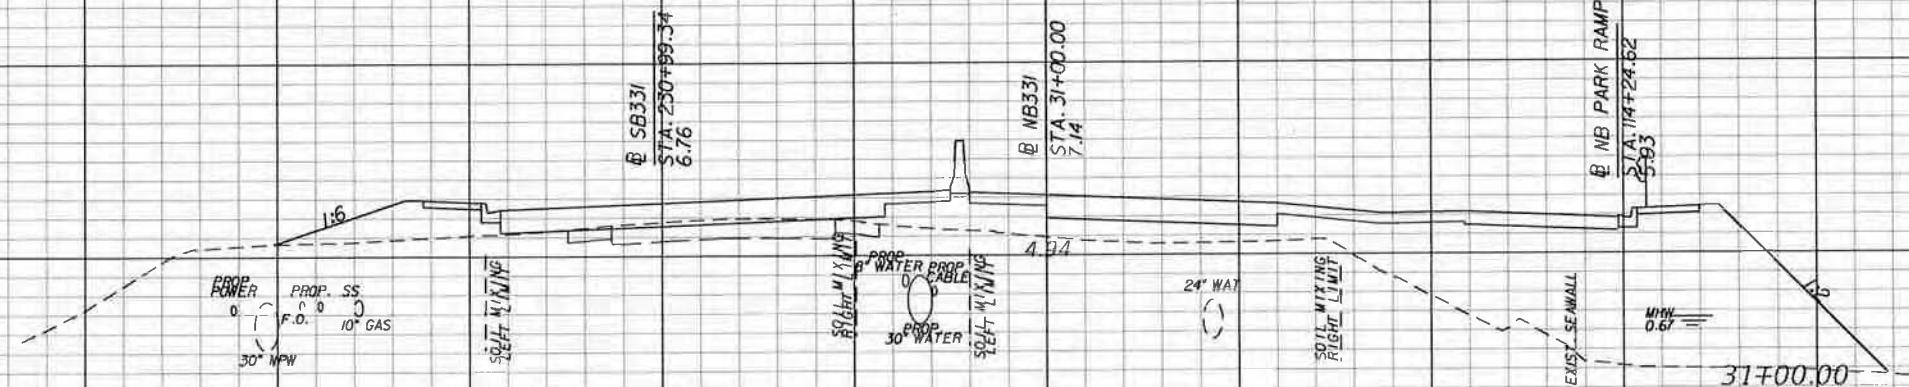


18  
16  
14  
12  
10  
8  
6  
4  
2  
0  
-2  
-4

18  
16  
14  
12  
10  
8  
6  
4  
2  
0  
-2  
-4

EXIST. SEAWALL

*Ch DD*  
1/16/14

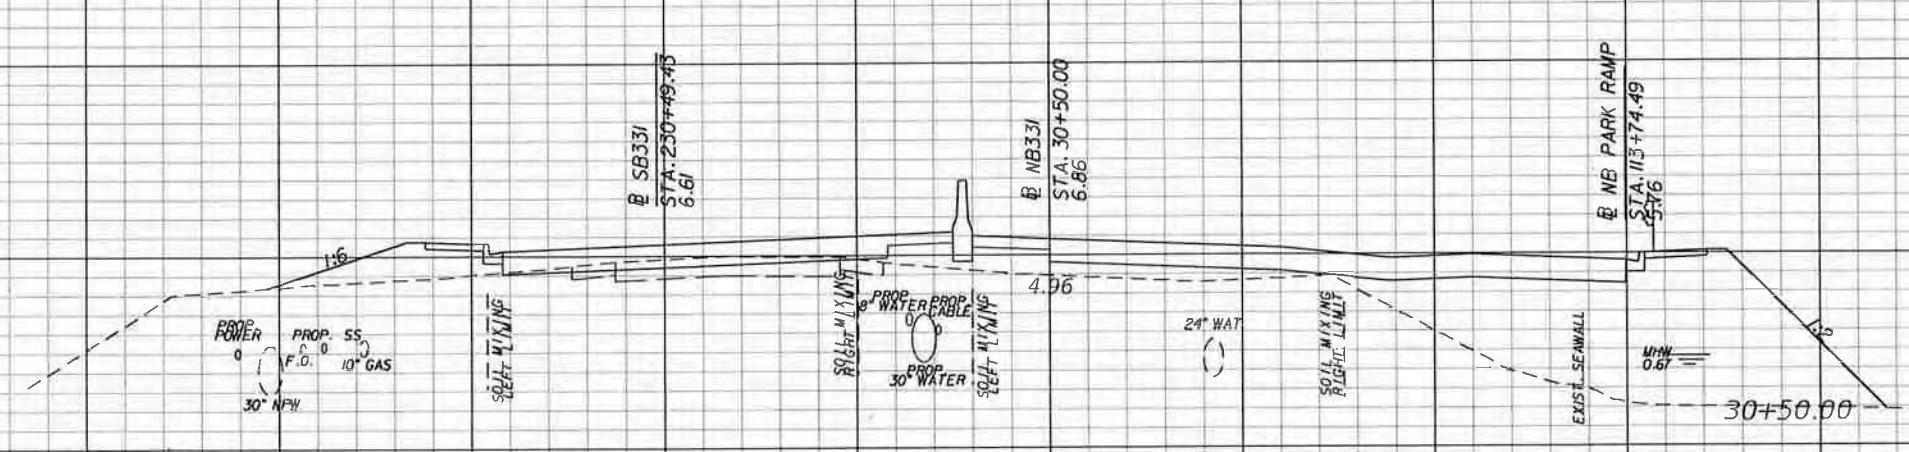

SCALE  
1" = 20' Horizontal  
1" = 10' Vertical

180 160 140 120 100 80 60 40 20 0 20 40 60 80 100

REVISIONS			
DATE	DESCRIPTION	DATE	DESCRIPTION

Parsons Brinckerhoff, Inc.  
121 W. Trade Street, Suite 1950  
Charlotte, NC 28202  
(704) 342-8469  
Cert. of Auth. No. 01462  
EOR: Christopher D Davis, P.E. No. 63070

STATE OF FLORIDA  
DEPARTMENT OF TRANSPORTATION  
ROAD NO. COUNTY FINANCIAL PROJECT ID  
83 WALTON 220664-2-52-01

CROSS SECTIONS

SHEET NO.  
136



66-0274274-010-EL

20  
18  
16  
14  
12  
10  
8  
6  
4  
2  
0  
-2  
-4

20  
18  
16  
14  
12  
10  
8  
6  
4  
2  
0  
-2  
-4

EXIST. SEAWALL

PROP POWER  
0 F.O. 10° GAS  
30° HFW

SOFT LINING

@ SB331  
STA. 23+49.25  
6.91

7.06

SOFT LINING

PROP WATERPROOF CABLE  
30° PROP WATER  
SOFT LINING

7.68  
8.58  
5.25

@ NB331

STA. 32+00.00  
8.42

24° WAT

( )

EXIST. SEAWALL

PROP WATERPROOF CABLE  
30° PROP WATER  
SOFT LINING

7.34  
6.71

EXIST. SEAWALL

@ NB PARK RAMP  
STA. 11+52+83  
6.25

32+00.00

18  
16  
14  
12  
10  
8  
6  
4  
2  
0  
-2  
-4

18  
16  
14  
12  
10  
8  
6  
4  
2  
0  
-2  
-4

EXIST. SEAWALL

PROP POWER  
0 F.O. 10° GAS  
30° HFW

SOFT LINING

@ SB331  
STA. 23+49.25  
6.91

7.06

SOFT LINING

PROP WATERPROOF CABLE  
30° PROP WATER  
SOFT LINING

5.08

@ NB331

STA. 31+50.00  
7.66

24° WAT

( )

EXIST. SEAWALL

@ NB PARK RAMP  
STA. 11+52+75  
6.09

31+50.00

SCALE

1" = 20' Horizontal  
1" = 10' Vertical

11/16/14

140

120

100

80

60

40

20

0

20

40

60

80

100

REVISIONS

DATE	DESCRIPTION	DATE	DESCRIPTION

Parsons Brinckerhoff, Inc.  
121 W. Trade Street, Suite 1950  
Charlotte, NC 28202  
(704) 342-8469  
Cert. of Auth. No. 01462  
EOR: Christopher D Davis, P.E. No. 63070

STATE OF FLORIDA  
DEPARTMENT OF TRANSPORTATION  
ROAD NO. COUNTY FINANCIAL PROJECT ID  
83 WALTON 220664-2-52-01

CROSS SECTIONS

SHEET NO.  
137



66-0274274-010-EL

PERMIT

*[Signature]*

22  
20  
18  
16  
14  
12  
10  
8  
6  
4  
2  
0  
-2  
-4

22  
20  
18  
16  
14  
12  
10  
8  
6  
4  
2  
0  
-2  
-4

EXIST. SEAWALL

PROP POWER  
0 1 1 0.0 10° GAS  
30° NPM

SEFT. W/ XING

@ SB33/  
STA. 232+96.96  
7.04

@ SB PARK RAMP  
STA. 310+22.55  
7.52  
7.66  
10.81  
@ NB33/  
STA. 33+00.00  
10.65

24° WAT  
5.47  
7.04  
8.57  
7.04  
MMH 0.67  
33+00.00

EXIST. SEAWALL  
@ NB PARK RAMP  
STA. #6+25.74  
6.58

20  
18  
16  
14  
12  
10  
8  
6  
4  
2  
0  
-2  
-4

20  
18  
16  
14  
12  
10  
8  
6  
4  
2  
0  
-2  
-4

EXIST. SEAWALL

PROP POWER  
0 1 1 0.0 10° GAS  
30° NPM

SEFT. W/ XING

@ SB33/  
STA. 232+99.07  
7.20

@ NB33/  
STA. 32+50.00  
9.41  
7.82  
9.57  
5.50  
24° WAT  
B.33  
6.87  
MMH 0.67  
32+50.00

EXIST. SEAWALL  
@ NB PARK RAMP  
STA. #5+75.01  
6.42

180 160 140 120 100 80 60 40 20 0 20 40 60 80 100

11/10/14

SCALE  
1" = 20' Horizontal  
1" = 10' Vertical

Parsons Brinckerhoff, Inc.  
121 W. Trade Street, Suite 1950  
Charlotte, NC 28202  
(704) 342-8469  
Cert. of Auth. No. 01462  
EOR: Christopher D Davis, P.E. No. 63070

STATE OF FLORIDA  
DEPARTMENT OF TRANSPORTATION

ROAD NO.	COUNTY	FINANCIAL PROJECT ID
83	WALTON	220664-2-52-01

CROSS SECTIONS

SHEET NO.


138

REVISIONS			
DATE	DESCRIPTION	DATE	DESCRIPTION



**66-027427**

ART PERIOD

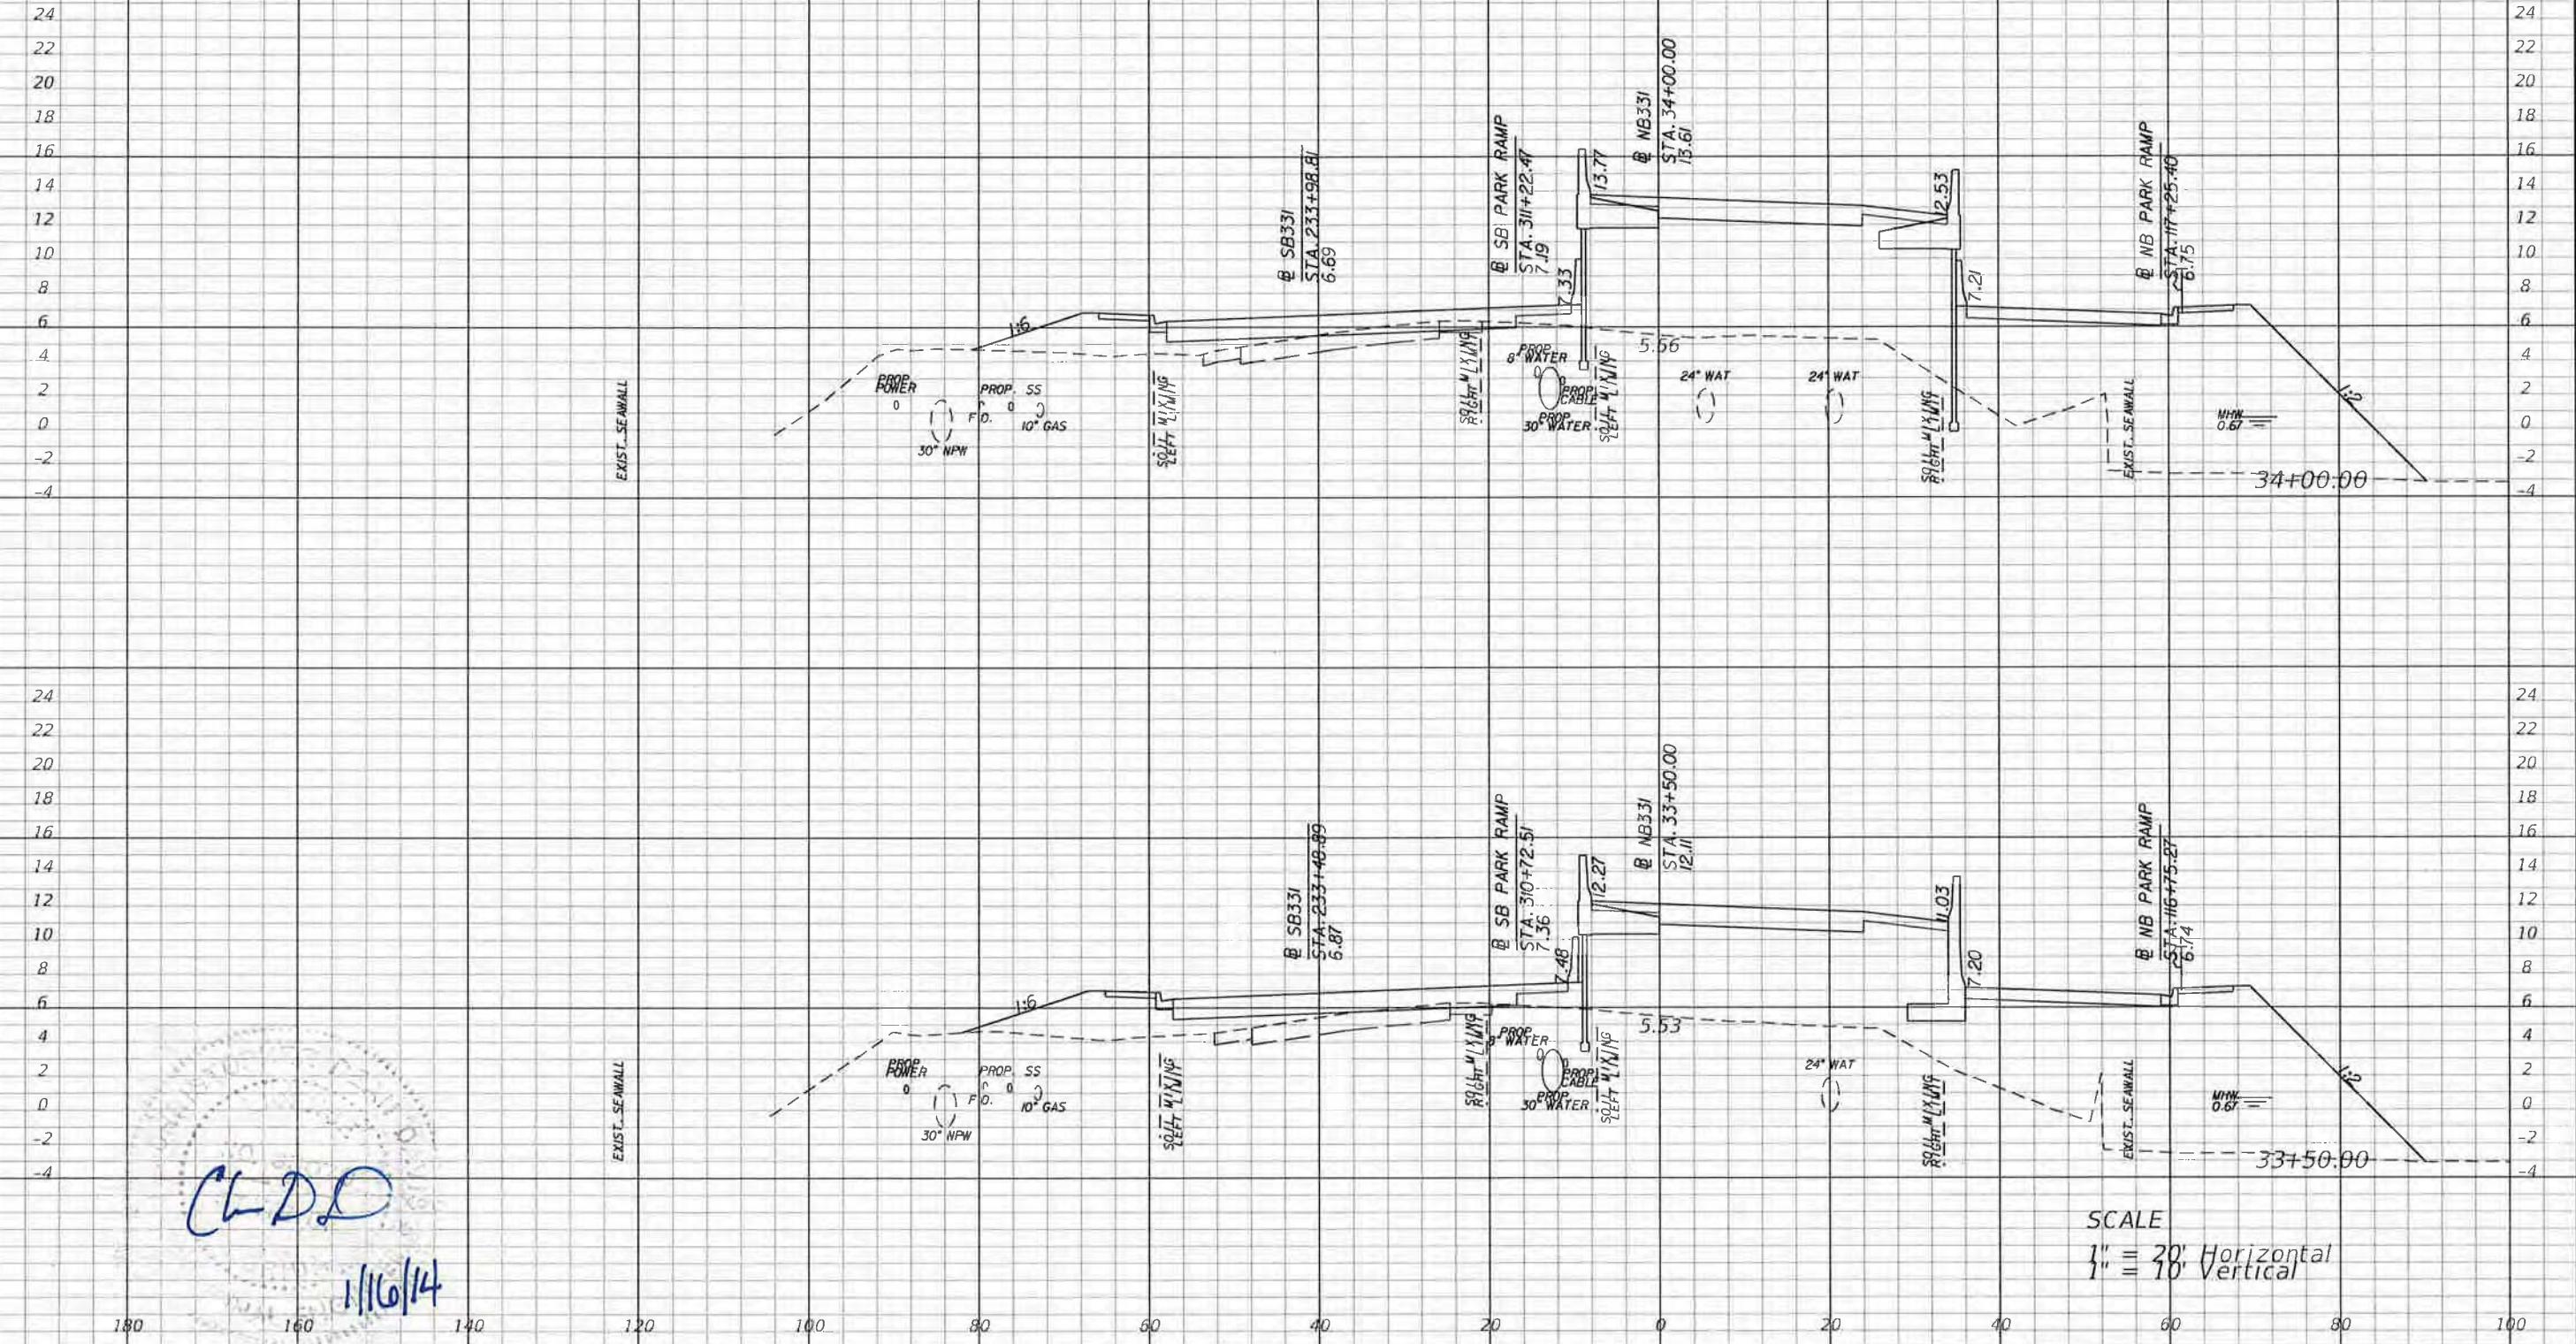

SCALE

$\frac{1}{16}$ " = 20' Horizontal  
 $\frac{1}{16}$ " = 10' Vertical

REVISIONS				Parsons Brinckerhoff, Inc. 121 W. Trade Street, Suite 1950 Charlotte, NC 28202 (704) 342-8469 Cert. of Auth. No. 01462 EOR: Christopher D Davis, P.E. No. 63070	STATE OF FLORIDA DEPARTMENT OF TRANSPORTATION			CROSS SECTIONS	SHEET NO. 139
DATE	DESCRIPTION	DATE	DESCRIPTION		ROAD NO.	COUNTY	FINANCIAL PROJECT ID		
					83	WALTON	220664-2-52-01		




EXIST. SEAWALL

EXIST. SEAWALL

*CD*  
1/16/14

180 160 140 120 100 80 60 40 20 0 20 40 60 80 100

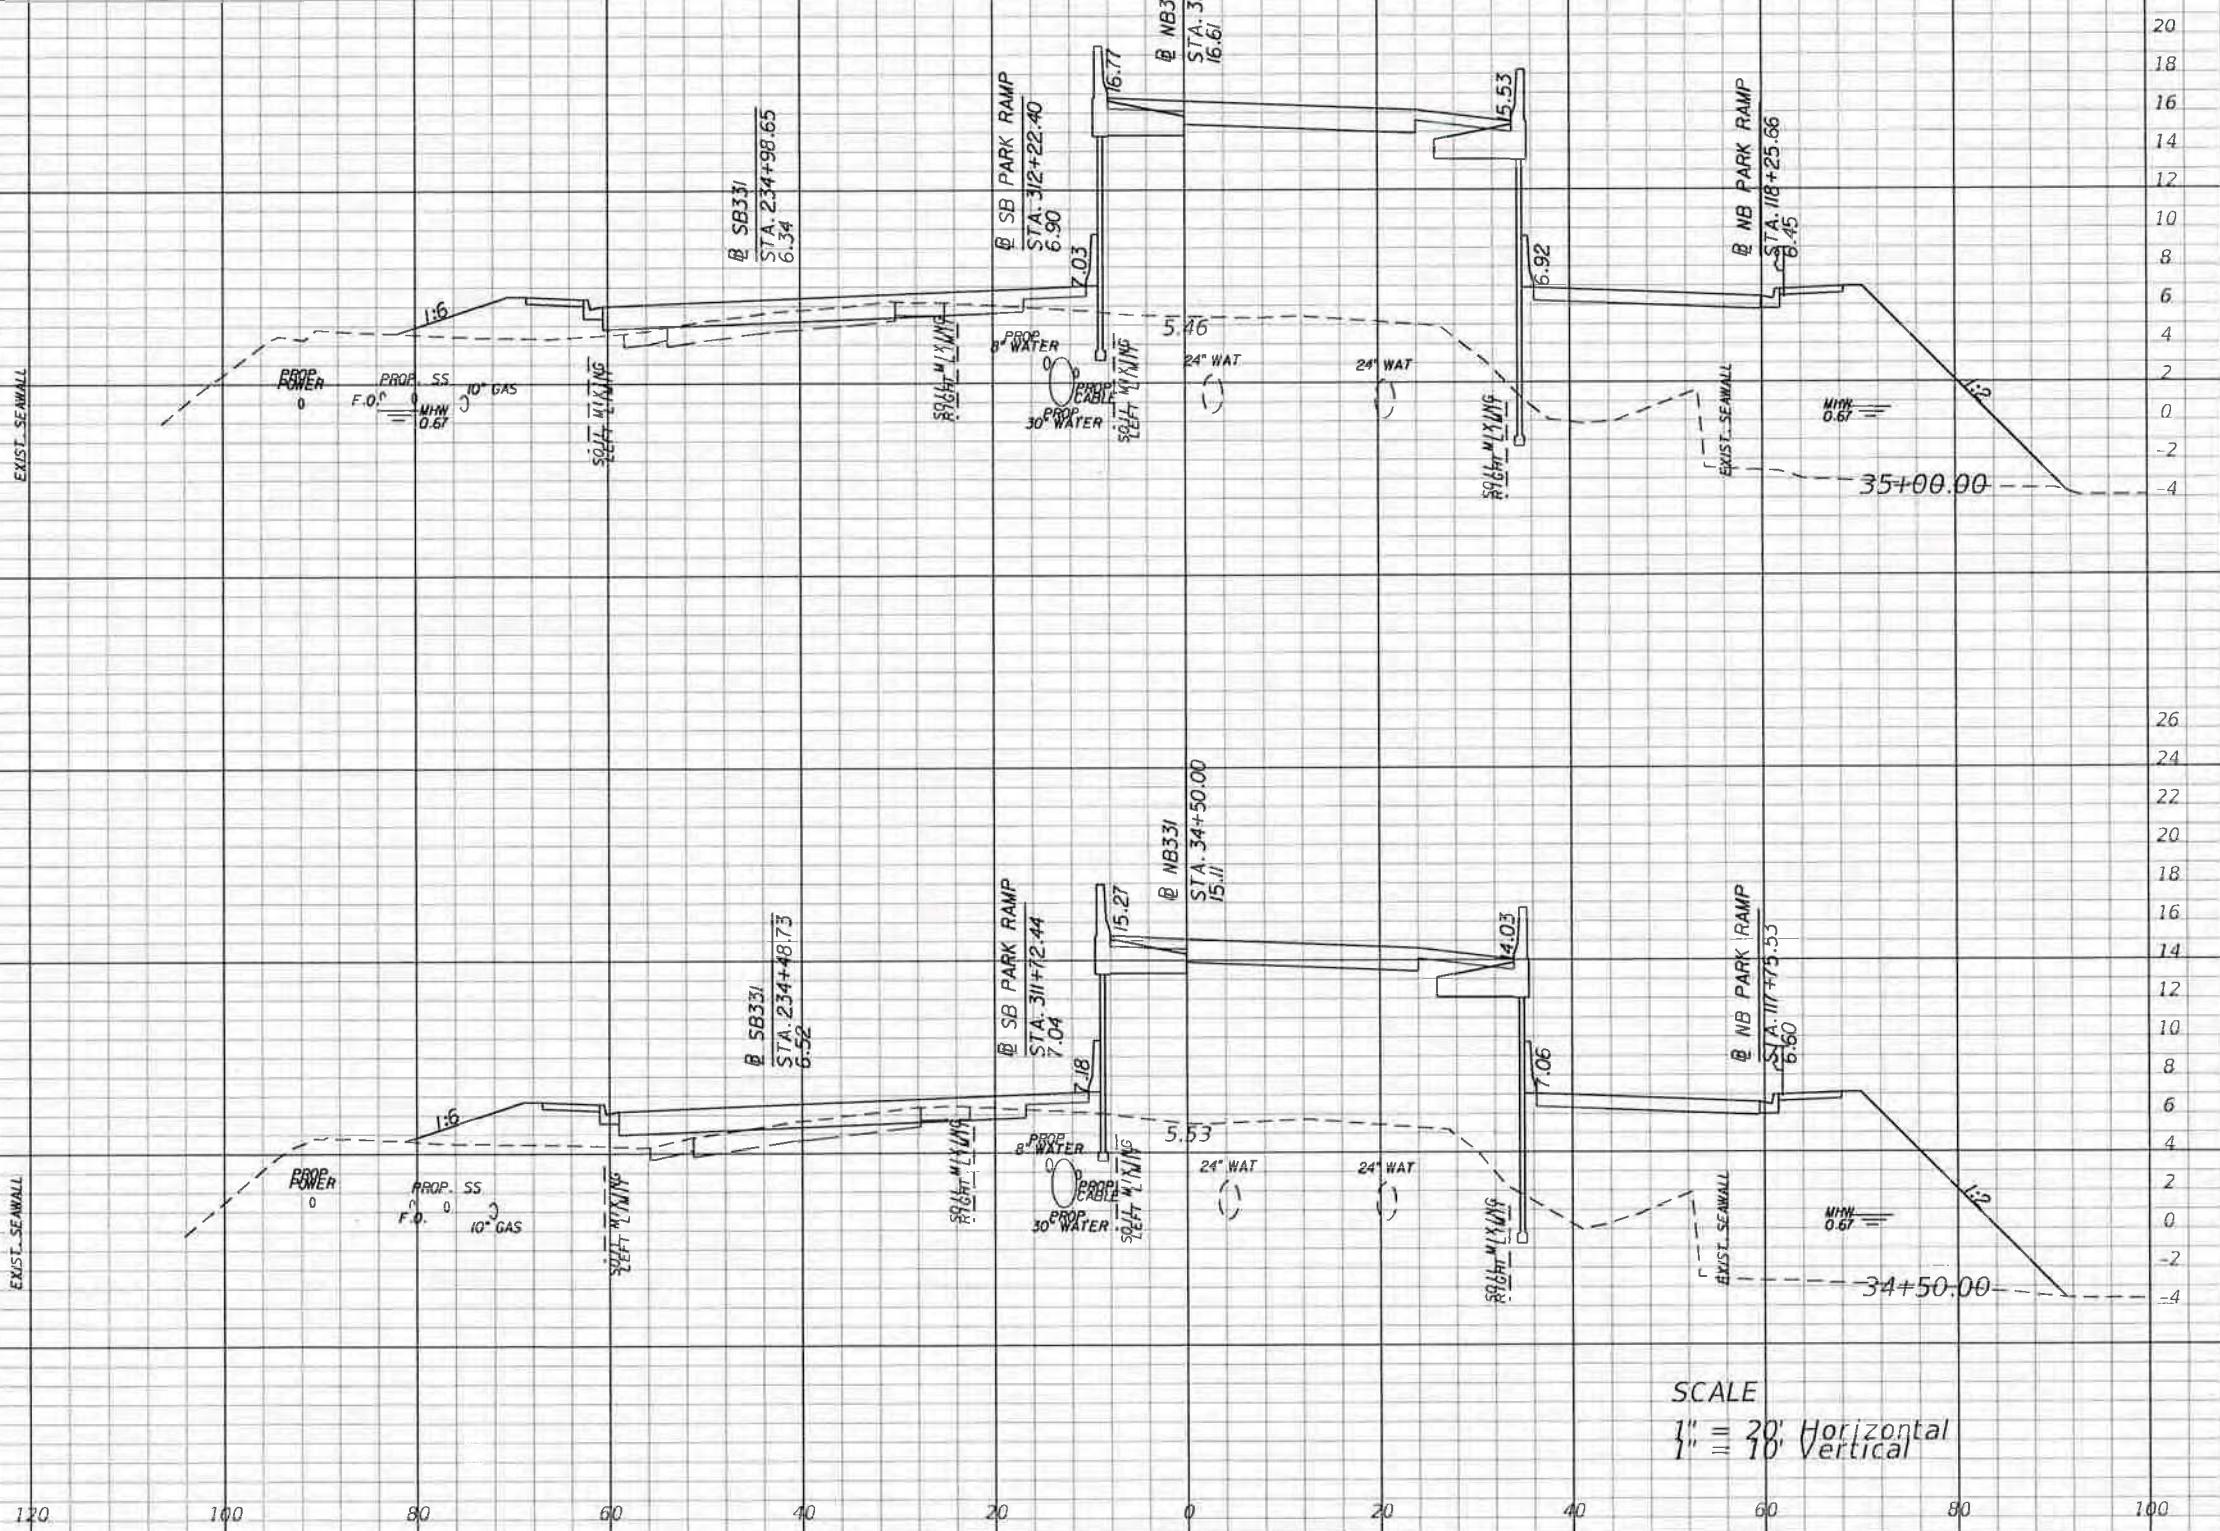

REVISIONS			
DATE	DESCRIPTION	DATE	DESCRIPTION


Parsons Brinckerhoff, Inc.  
121 W. Trade Street, Suite 1950  
Charlotte, NC 28202  
(704) 342-8469  
Cert. of Auth. No. 01462  
EOR: Christopher D Davis, P.E. No. 63070

STATE OF FLORIDA  
DEPARTMENT OF TRANSPORTATION

ROAD NO.	COUNTY	FINANCIAL PROJECT ID
83	WALTON	220664-2-52-01

CROSS SECTIONS

SHEET NO.  
140

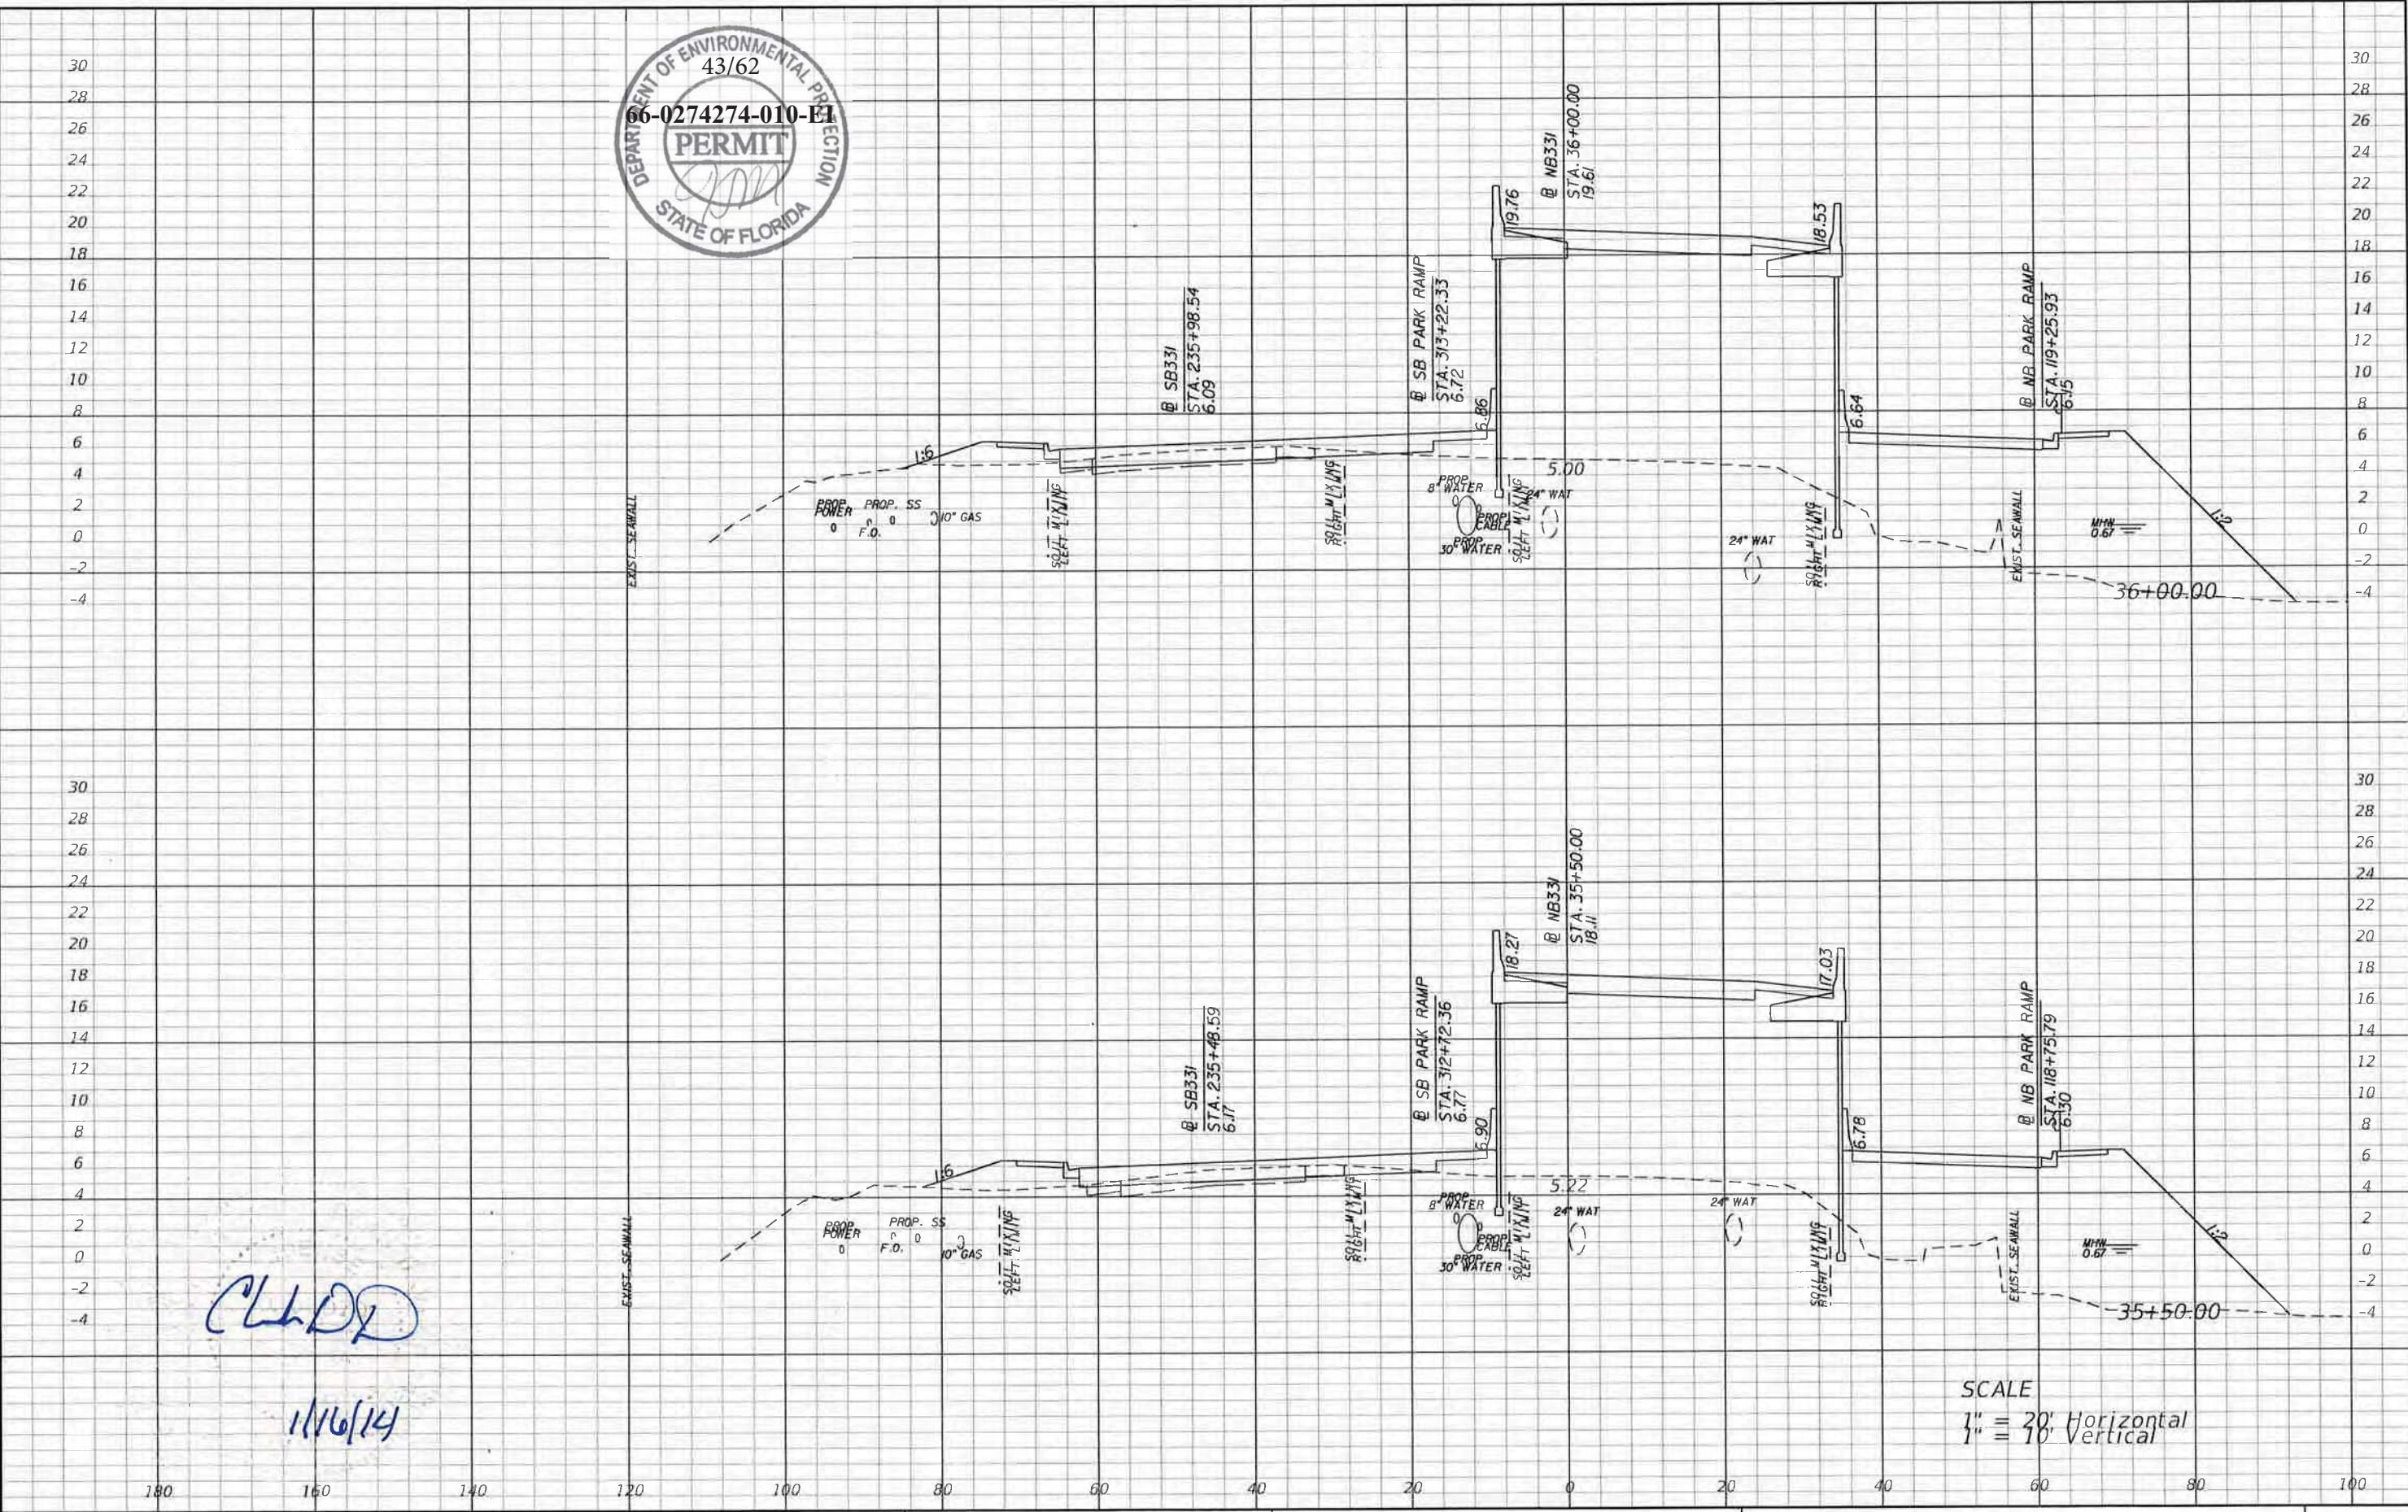

CLHD

1/16/14

180

160

140

120

100

80

60

40

20

0

20

40

60

80

100

REVISIONS

DATE	DESCRIPTION	DATE	DESCRIPTION

Parsons Brinckerhoff, Inc.  
121 W. Trade Street, Suite 1950  
Charlotte, NC 28202  
(704) 342-8469  
Cert. of Auth. No. 01462  
EOR: Christopher D Davis, P.E. No. 63070

STATE OF FLORIDA  
DEPARTMENT OF TRANSPORTATION

ROAD NO.	COUNTY	FINANCIAL PROJECT ID
83	WALTON	220664-2-52-01

davisch

1/16/2014


1:46:01 PM

T:\projects\D3\_Cheetahatchee\_Bridge\_DB\roadway\RDXR01.DGN


CROSS SECTIONS

SHEET NO.

141

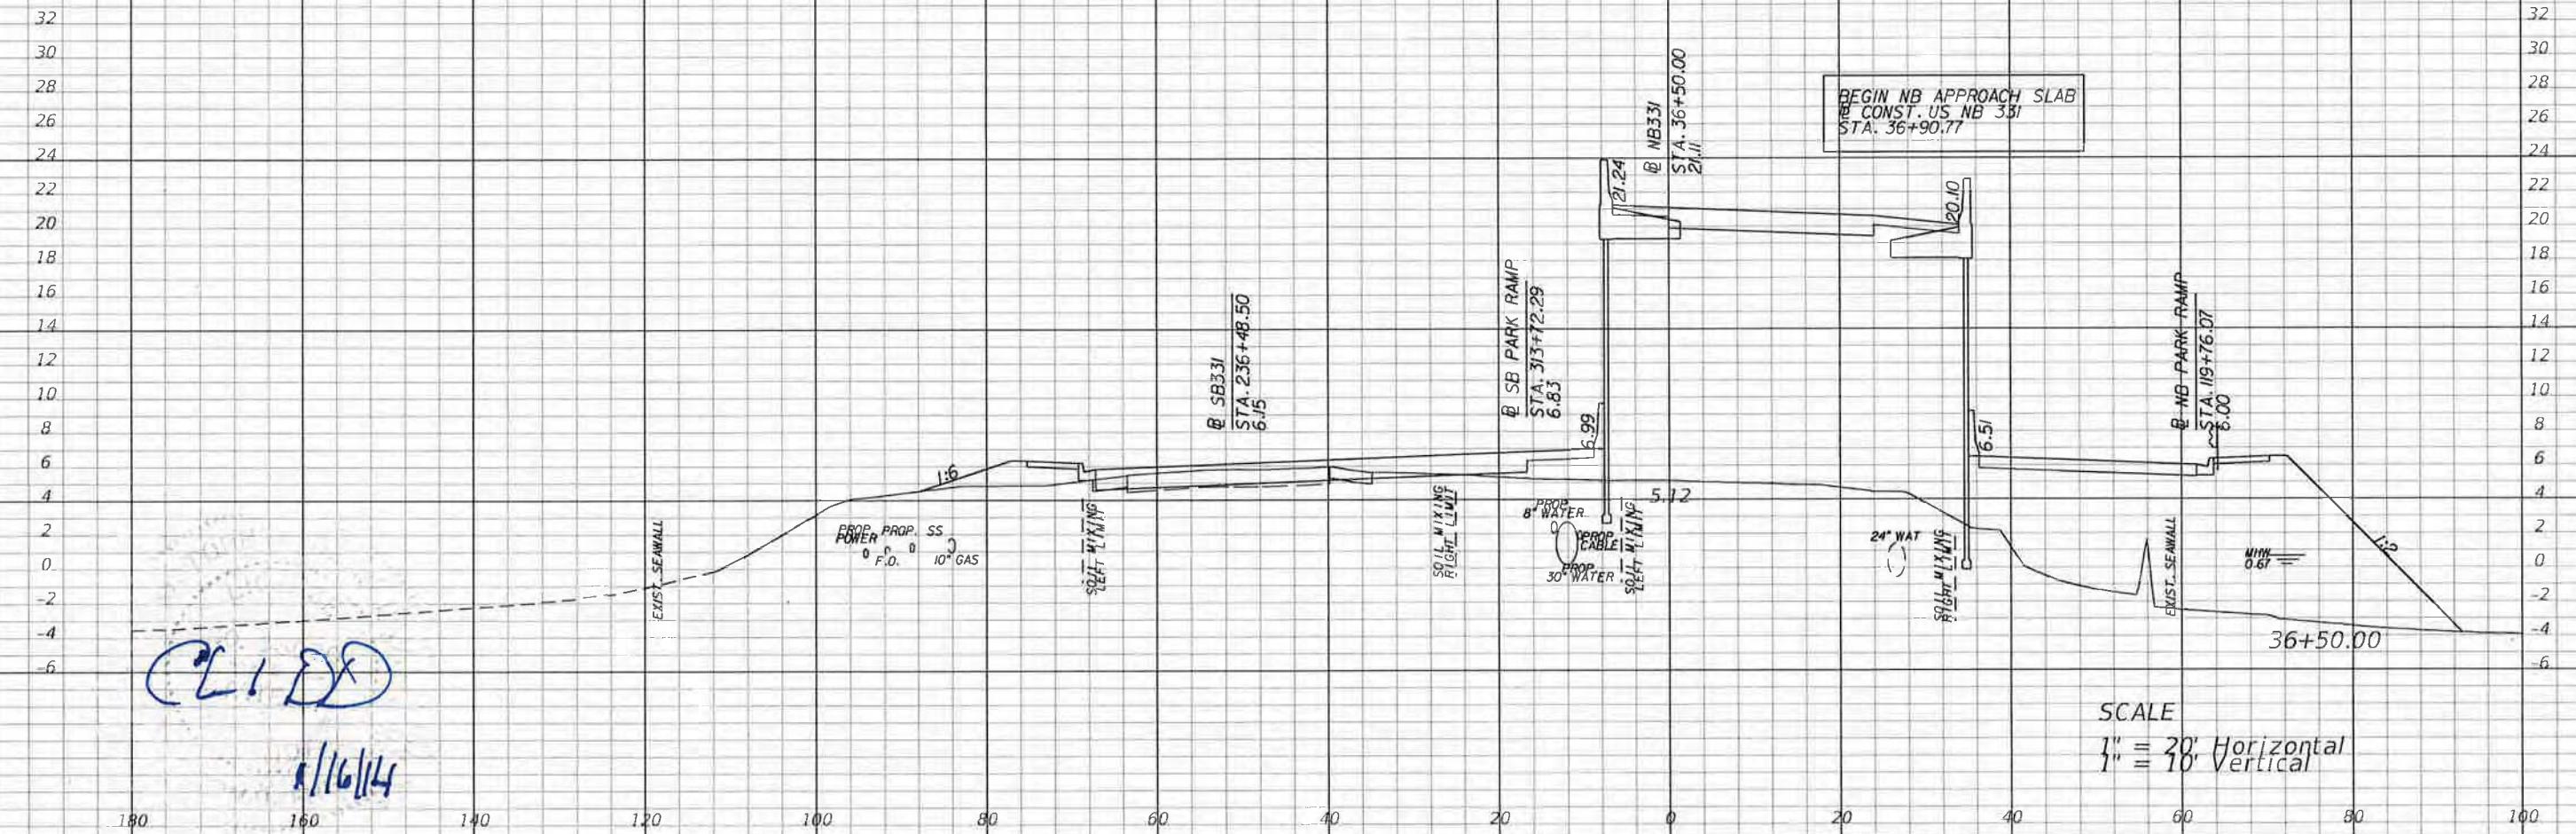

REVISIONS				Parsons Brinckerhoff, Inc. 121 W. Trade Street, Suite 1950 Charlotte, NC 28202 (704) 342-8469 Cert. of Auth. No. 01462 EOR: Christopher D Davis, P.E. No. 63070	STATE OF FLORIDA DEPARTMENT OF TRANSPORTATION ROAD NO. 83 COUNTY WALTON FINANCIAL PROJECT ID 220664-2-52-01	CROSS SECTIONS	SHEET NO.
DATE	DESCRIPTION	DATE	DESCRIPTION				142

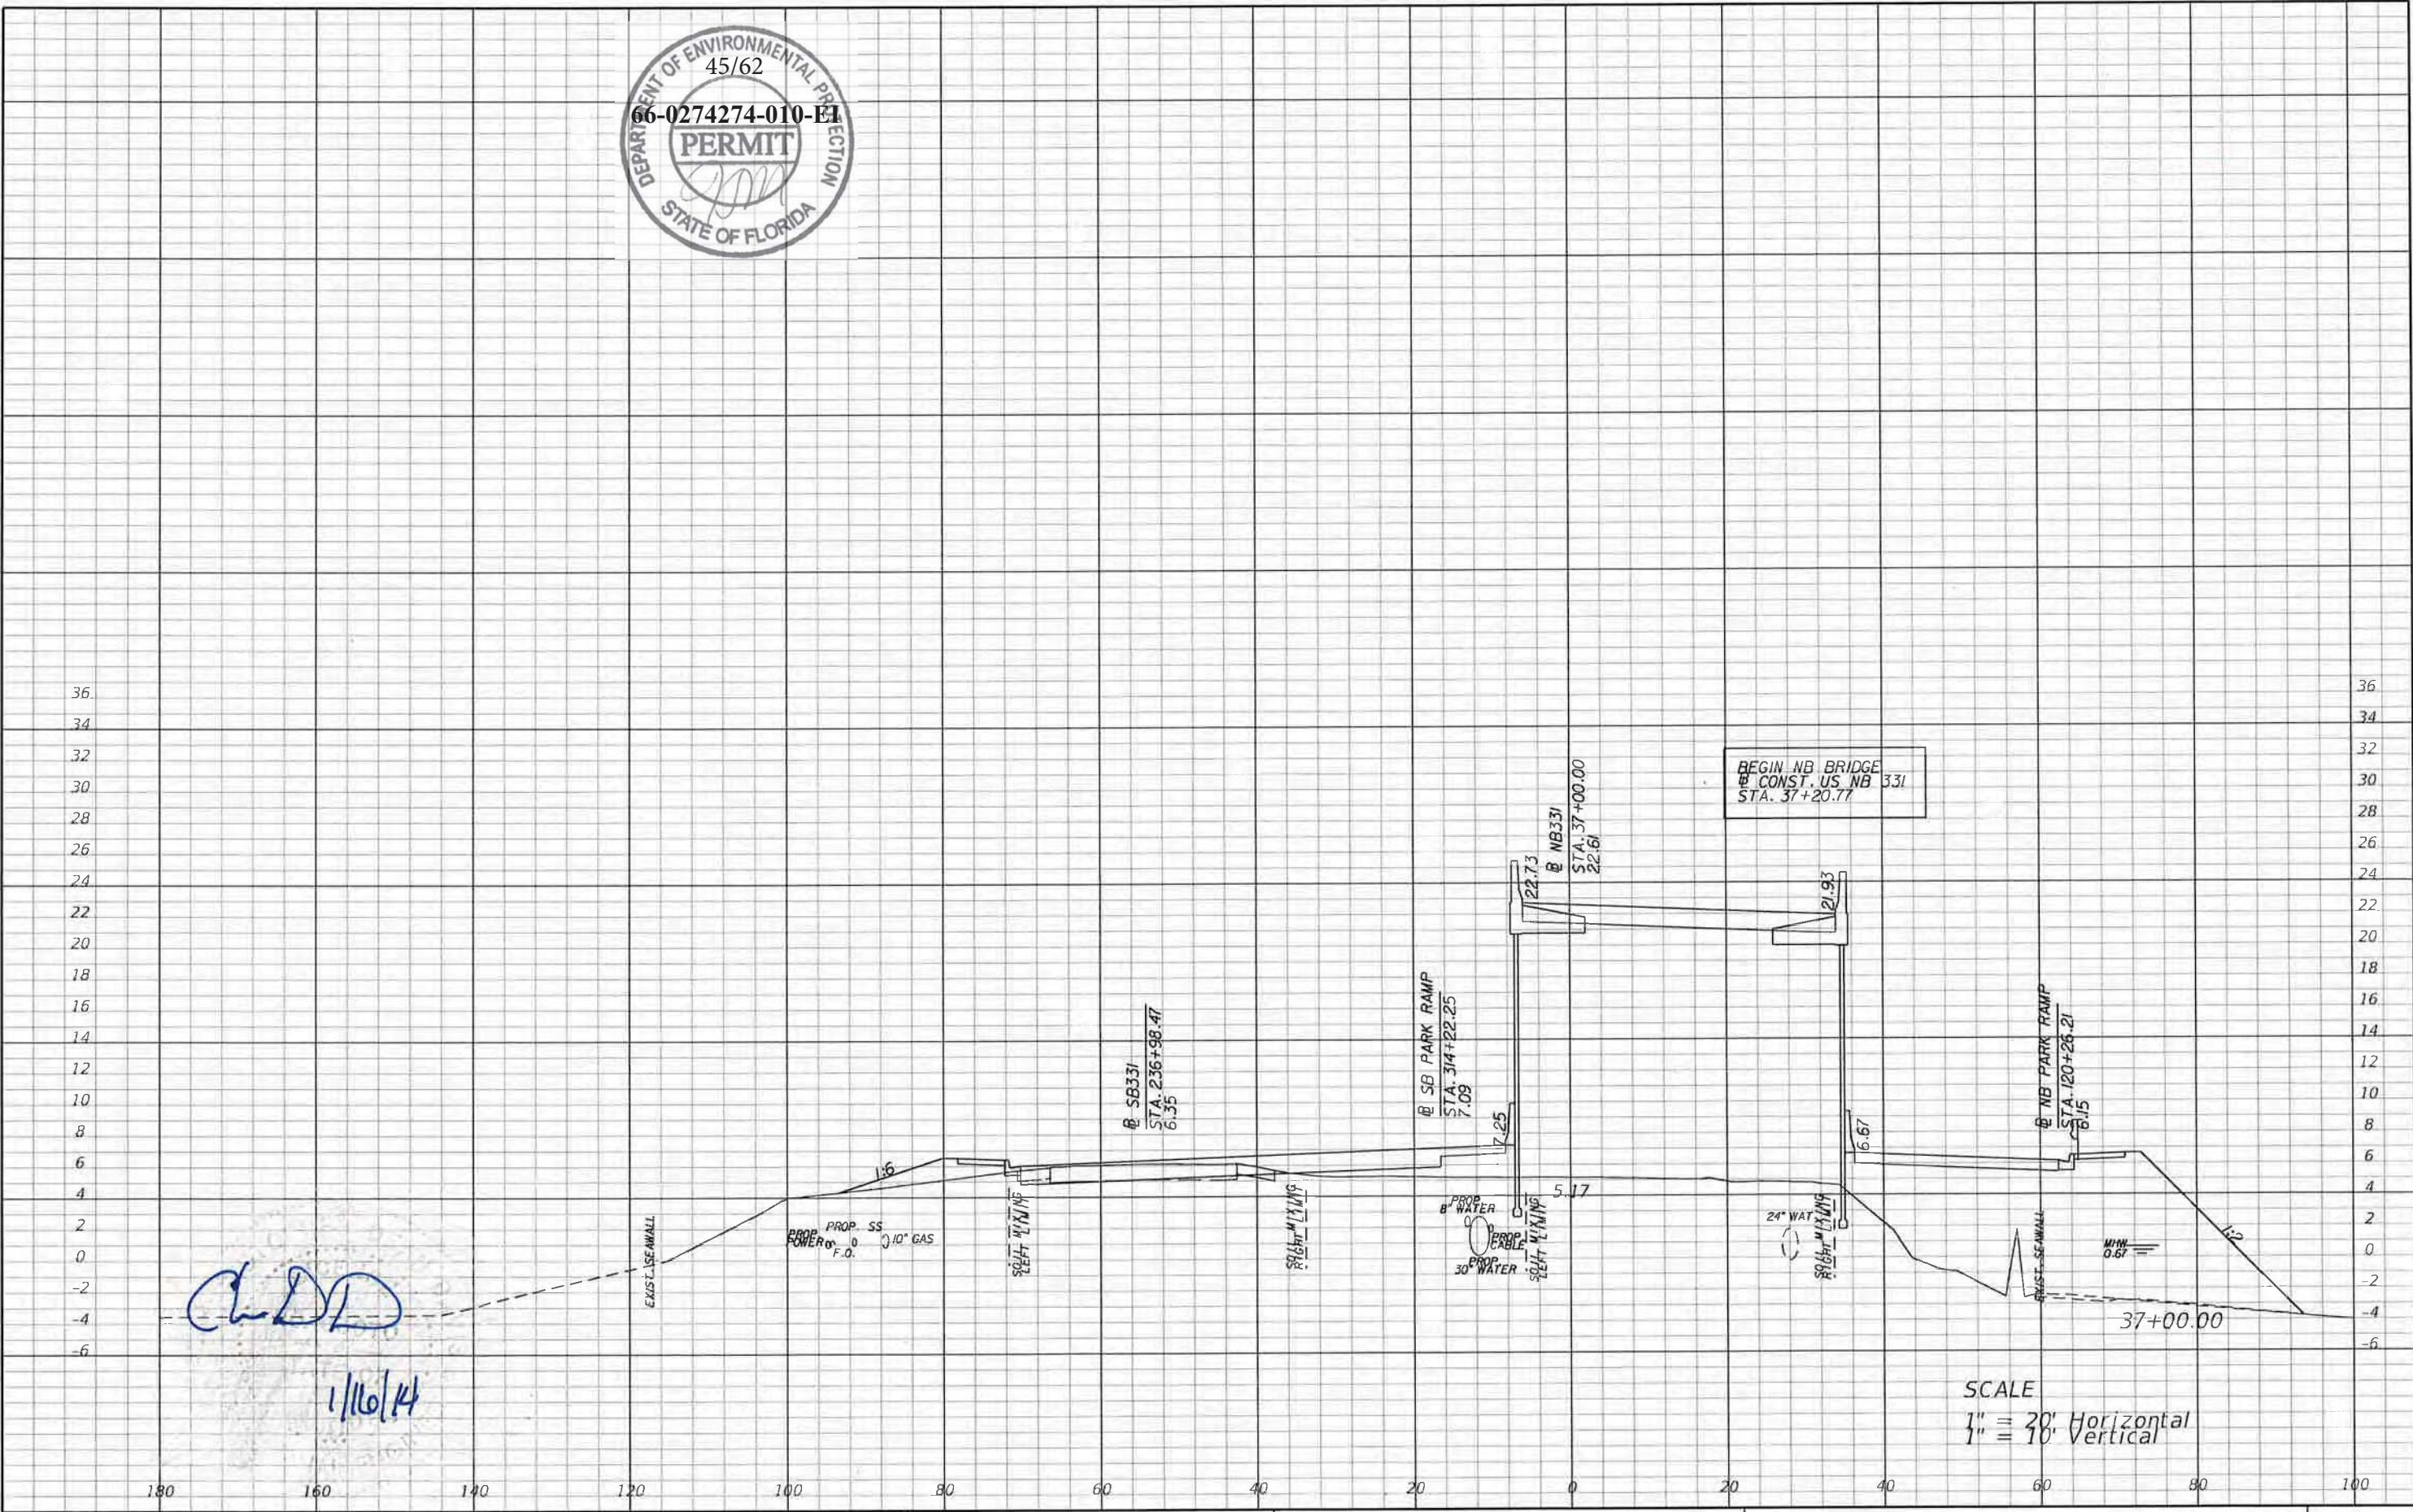


REVISIONS			
DATE	DESCRIPTION	DATE	DESCRIPTION

Parsons Brinckerhoff, Inc.  
121 W. Trade Street, Suite 1950  
Charlotte, NC 28202  
(704) 342-8469  
Cert. of Auth. No. 01462  
EOR: Christopher D Davis, P.E. No. 63070

STATE OF FLORIDA  
DEPARTMENT OF TRANSPORTATION  
ROAD NO. COUNTY FINANCIAL PROJECT ID  
83 WALTON 220664-2-52-01

CROSS SECTIONS

SHEET NO.  
143

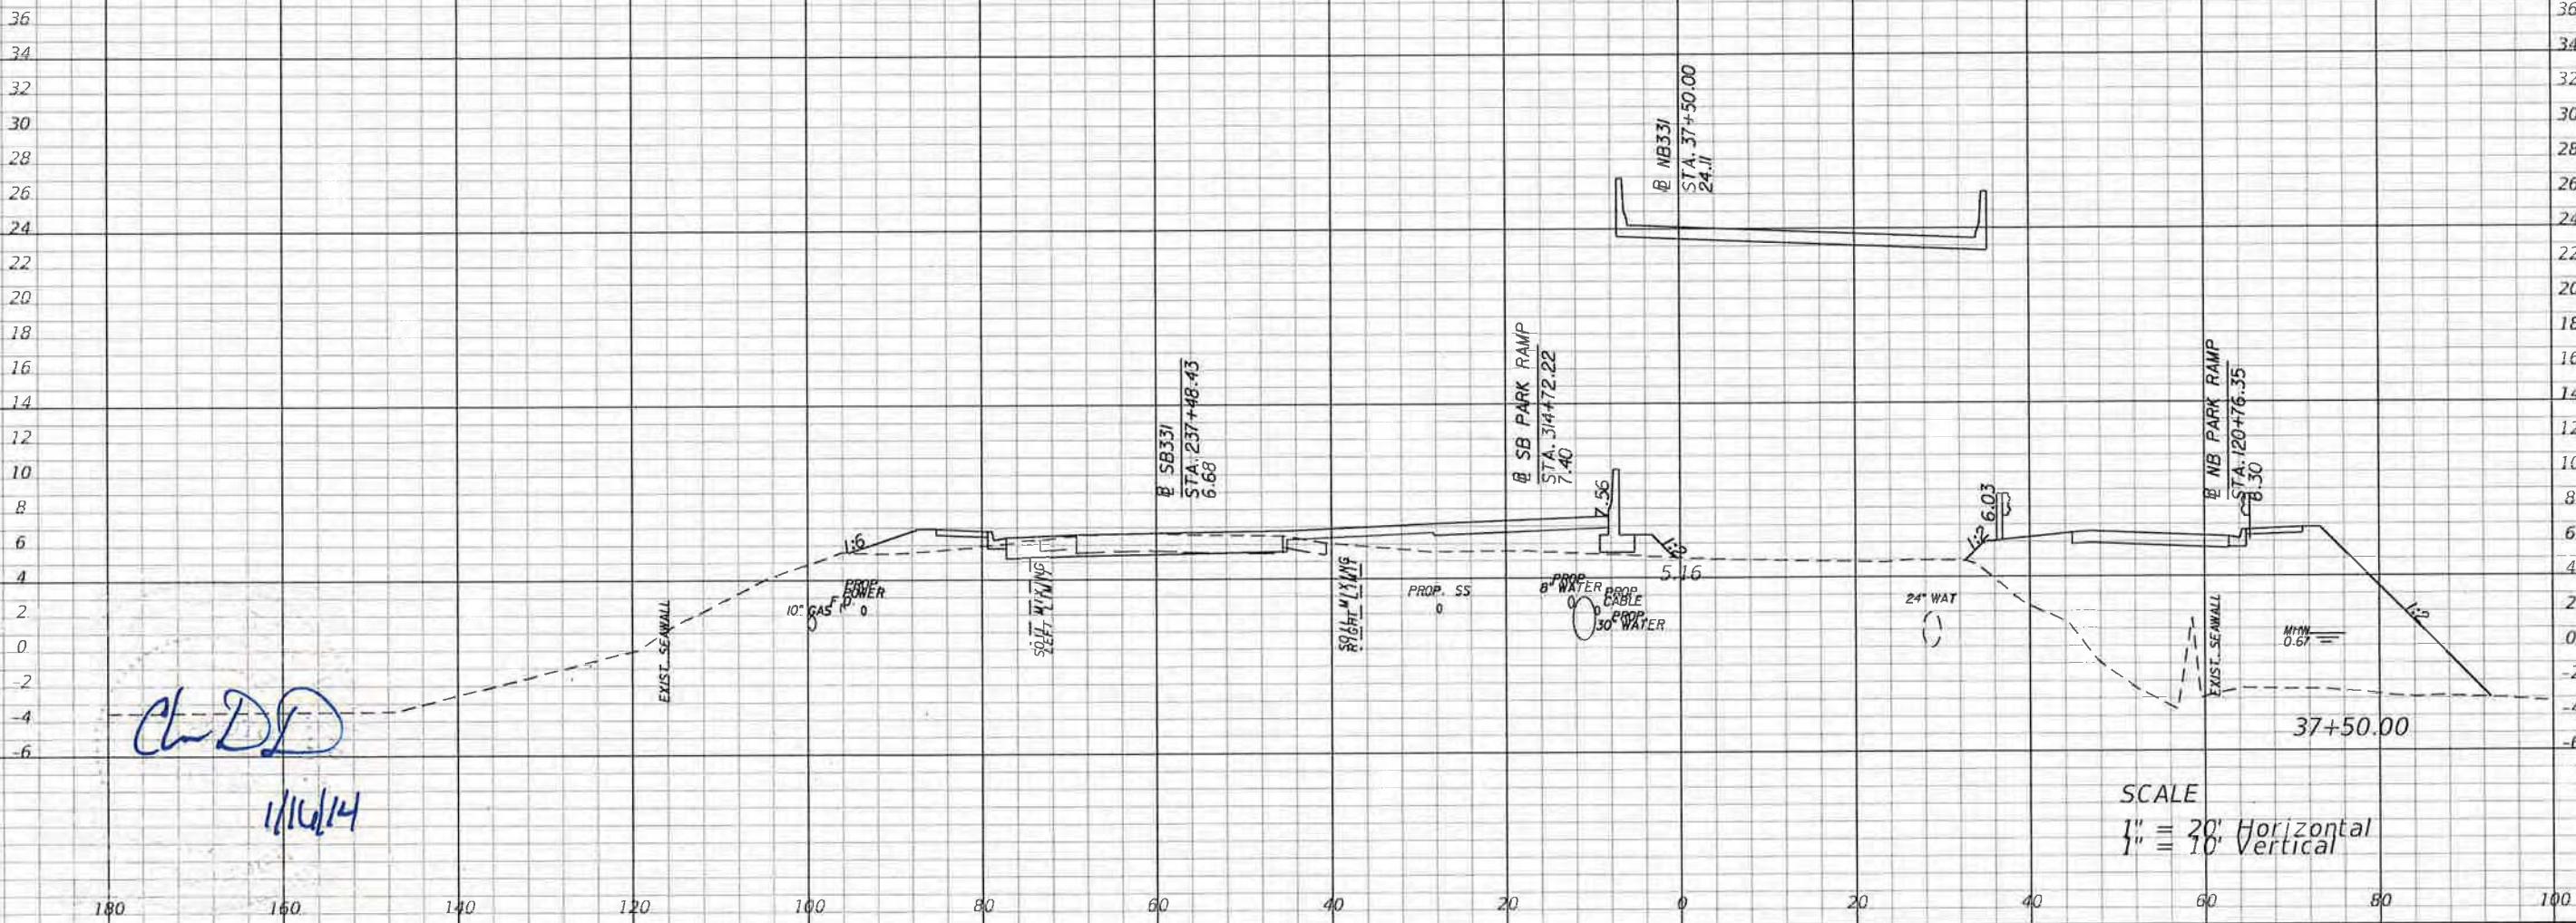

REVISIONS			
DATE	DESCRIPTION	DATE	DESCRIPTION

Parsons Brinckerhoff, Inc.  
121 W. Trade Street, Suite 1950  
Charlotte, NC 28202  
(704) 342-8469  
Cert. of Auth. No. 01462  
EOR: Christopher D Davis, P.E. No. 63070

STATE OF FLORIDA  
DEPARTMENT OF TRANSPORTATION

ROAD NO.	COUNTY	FINANCIAL PROJECT ID
83	WALTON	220664-2-52-01

### CROSS SECTIONS

SHEET NO.  
144




66-0274274-010-EL

PERMIT

1/16/14

BEGIN SB APPROACH SLAB  
STA. 237+88.24  
BEGIN EXIST SB BRIDGE  
STA. 238+18.24  
CONST. SB US 331

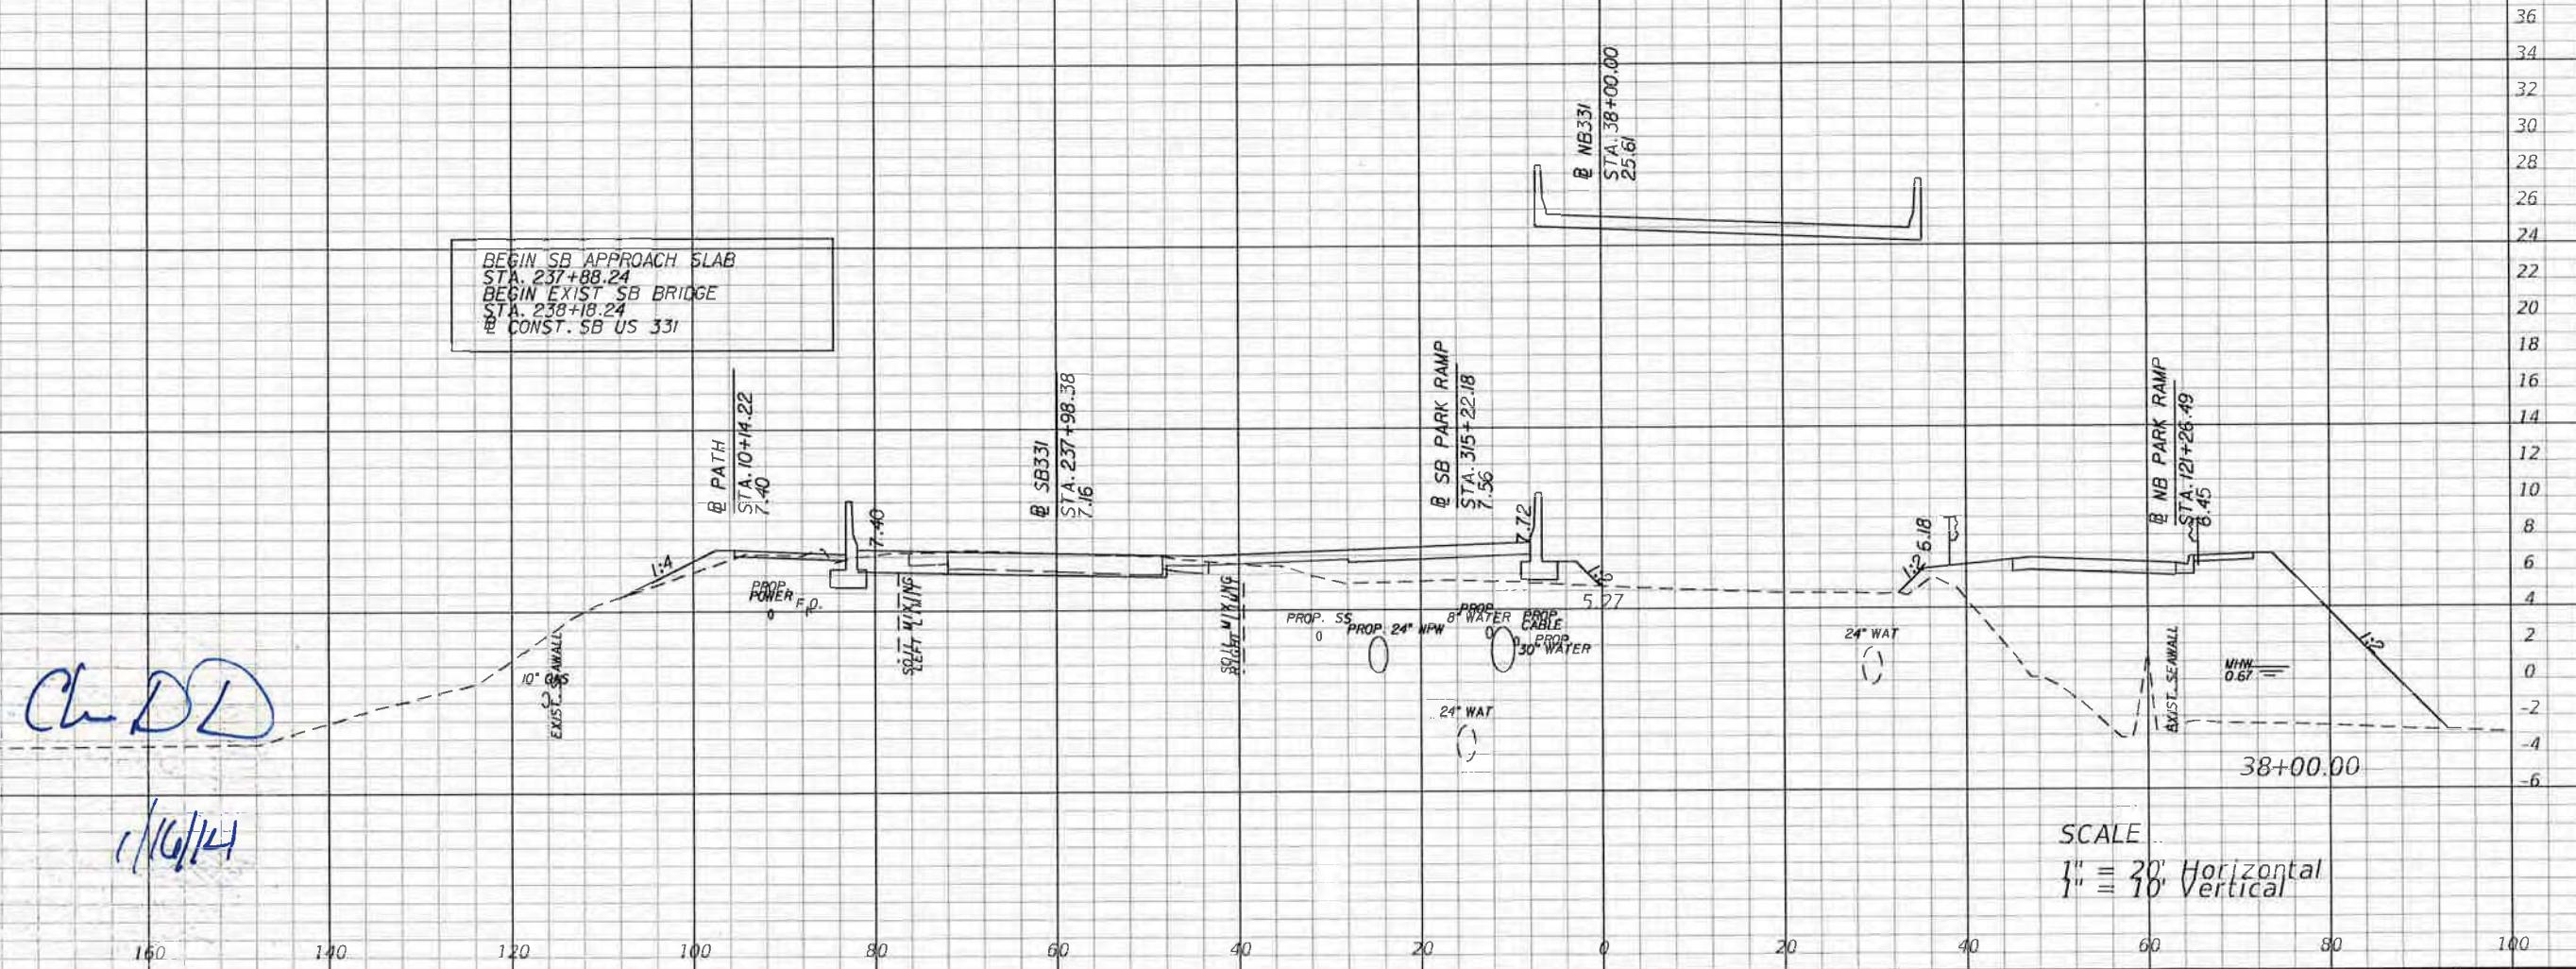

REVISIONS			
DATE	DESCRIPTION	DATE	DESCRIPTION

Parsons Brinckerhoff, Inc.  
121 W. Trade Street, Suite 1950  
Charlotte, NC 28202  
(704) 342-8469  
Cert. of Auth. No. 01462  
EOR: Christopher D Davis, P.E. No. 63070

STATE OF FLORIDA  
DEPARTMENT OF TRANSPORTATION

ROAD NO.	COUNTY	FINANCIAL PROJECT ID
83	WALTON	220664-2-52-01

CROSS SECTIONS

SHEET NO.  
145



38  
36  
34  
32  
30  
28  
26  
24  
22  
20  
18  
16  
14  
12  
10  
8  
6  
4  
2  
0  
-2  
-4  
-6

38  
36  
34  
32  
30  
28  
26  
24  
22  
20  
18  
16  
14  
12  
10  
8  
6  
4  
2  
0  
-2  
-4  
-6

180 160 140 120 100 80 60 40 20 0 20 40 60 80 100

REVISIONS

DATE	DESCRIPTION	DATE	DESCRIPTION

Parsons Brinckerhoff, Inc.  
121 W. Trade Street, Suite 1950  
Charlotte, NC 28202  
(704) 342-8469  
Cert. of Auth. No. 01462  
EOR: Christopher D Davis, P.E. No. 63070

STATE OF FLORIDA  
DEPARTMENT OF TRANSPORTATION

ROAD NO.	COUNTY	FINANCIAL PROJECT ID
83	WALTON	220664-2-52-01

davisch

1/16/2014 1:46:02 PM T:\projects\D3\_Choctawhatchee\_Bridge\_DB\roadway\RDXSRD01.DGN


CROSS SECTIONS

SHEET NO.

146

CLD

1/16/14

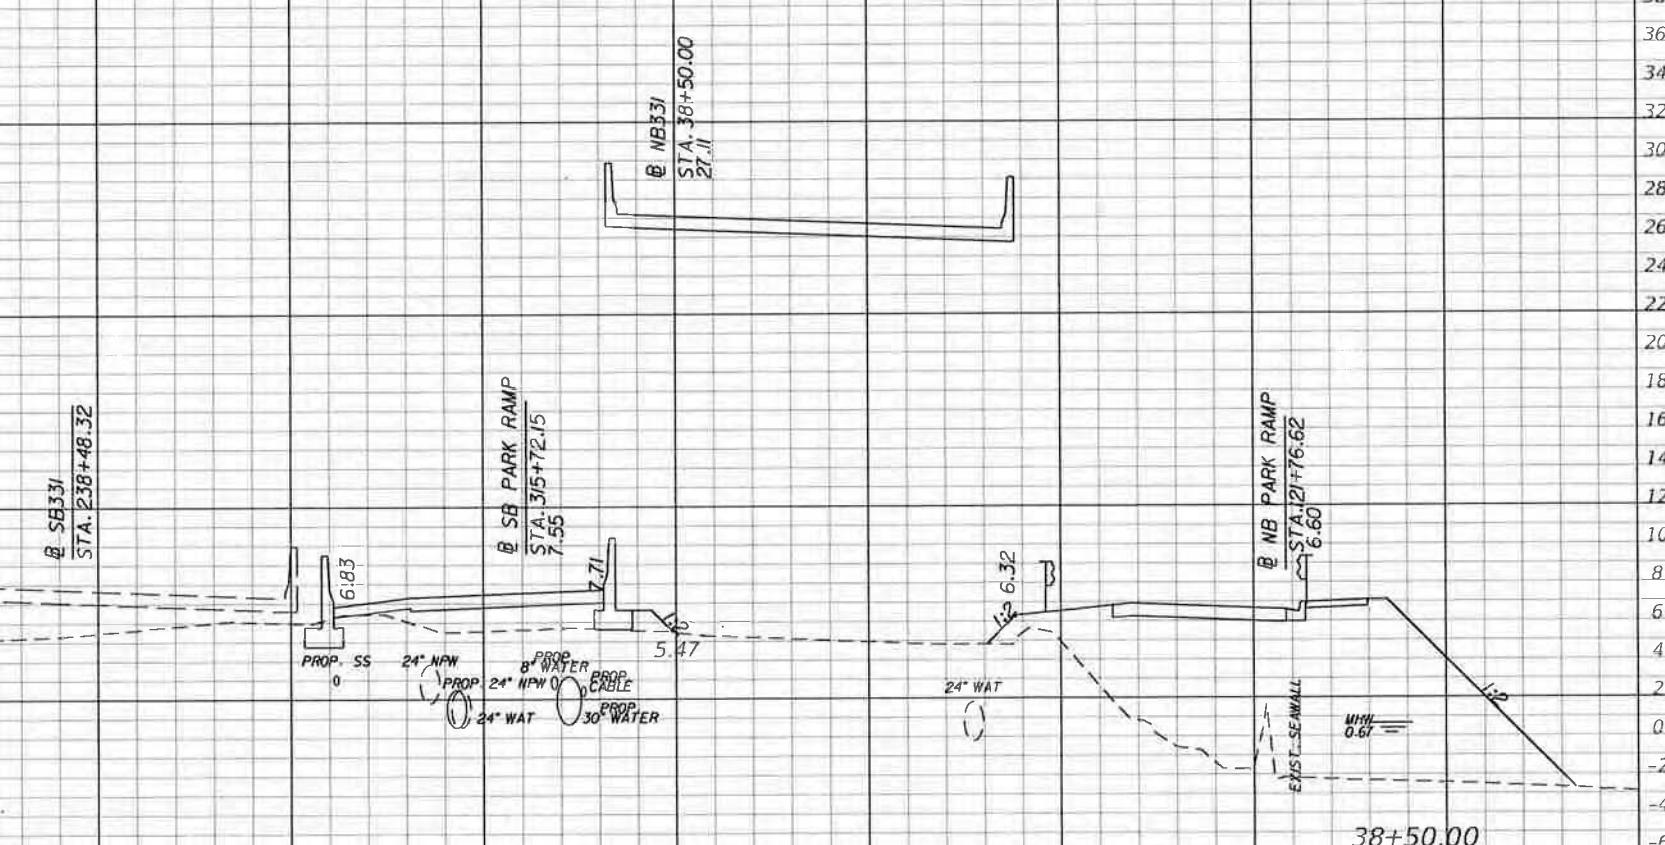



*CDL*  
1/16/14

REVISIONS


DATE	DESCRIPTION	DATE	DESCRIPTION

Parsons Brinckerhoff, Inc.  
121 W. Trade Street, Suite 1950  
Charlotte, NC 28202  
(704) 342-8469  
Cert. of Auth. No. 01462  
EOR: Christopher D Davis, P.E. No. 63070

STATE OF FLORIDA  
DEPARTMENT OF TRANSPORTATION  
ROAD NO. COUNTY FINANCIAL PROJECT ID  
83 WALTON 220664-2-52-01

CROSS SECTIONS


SHEET NO.  
147

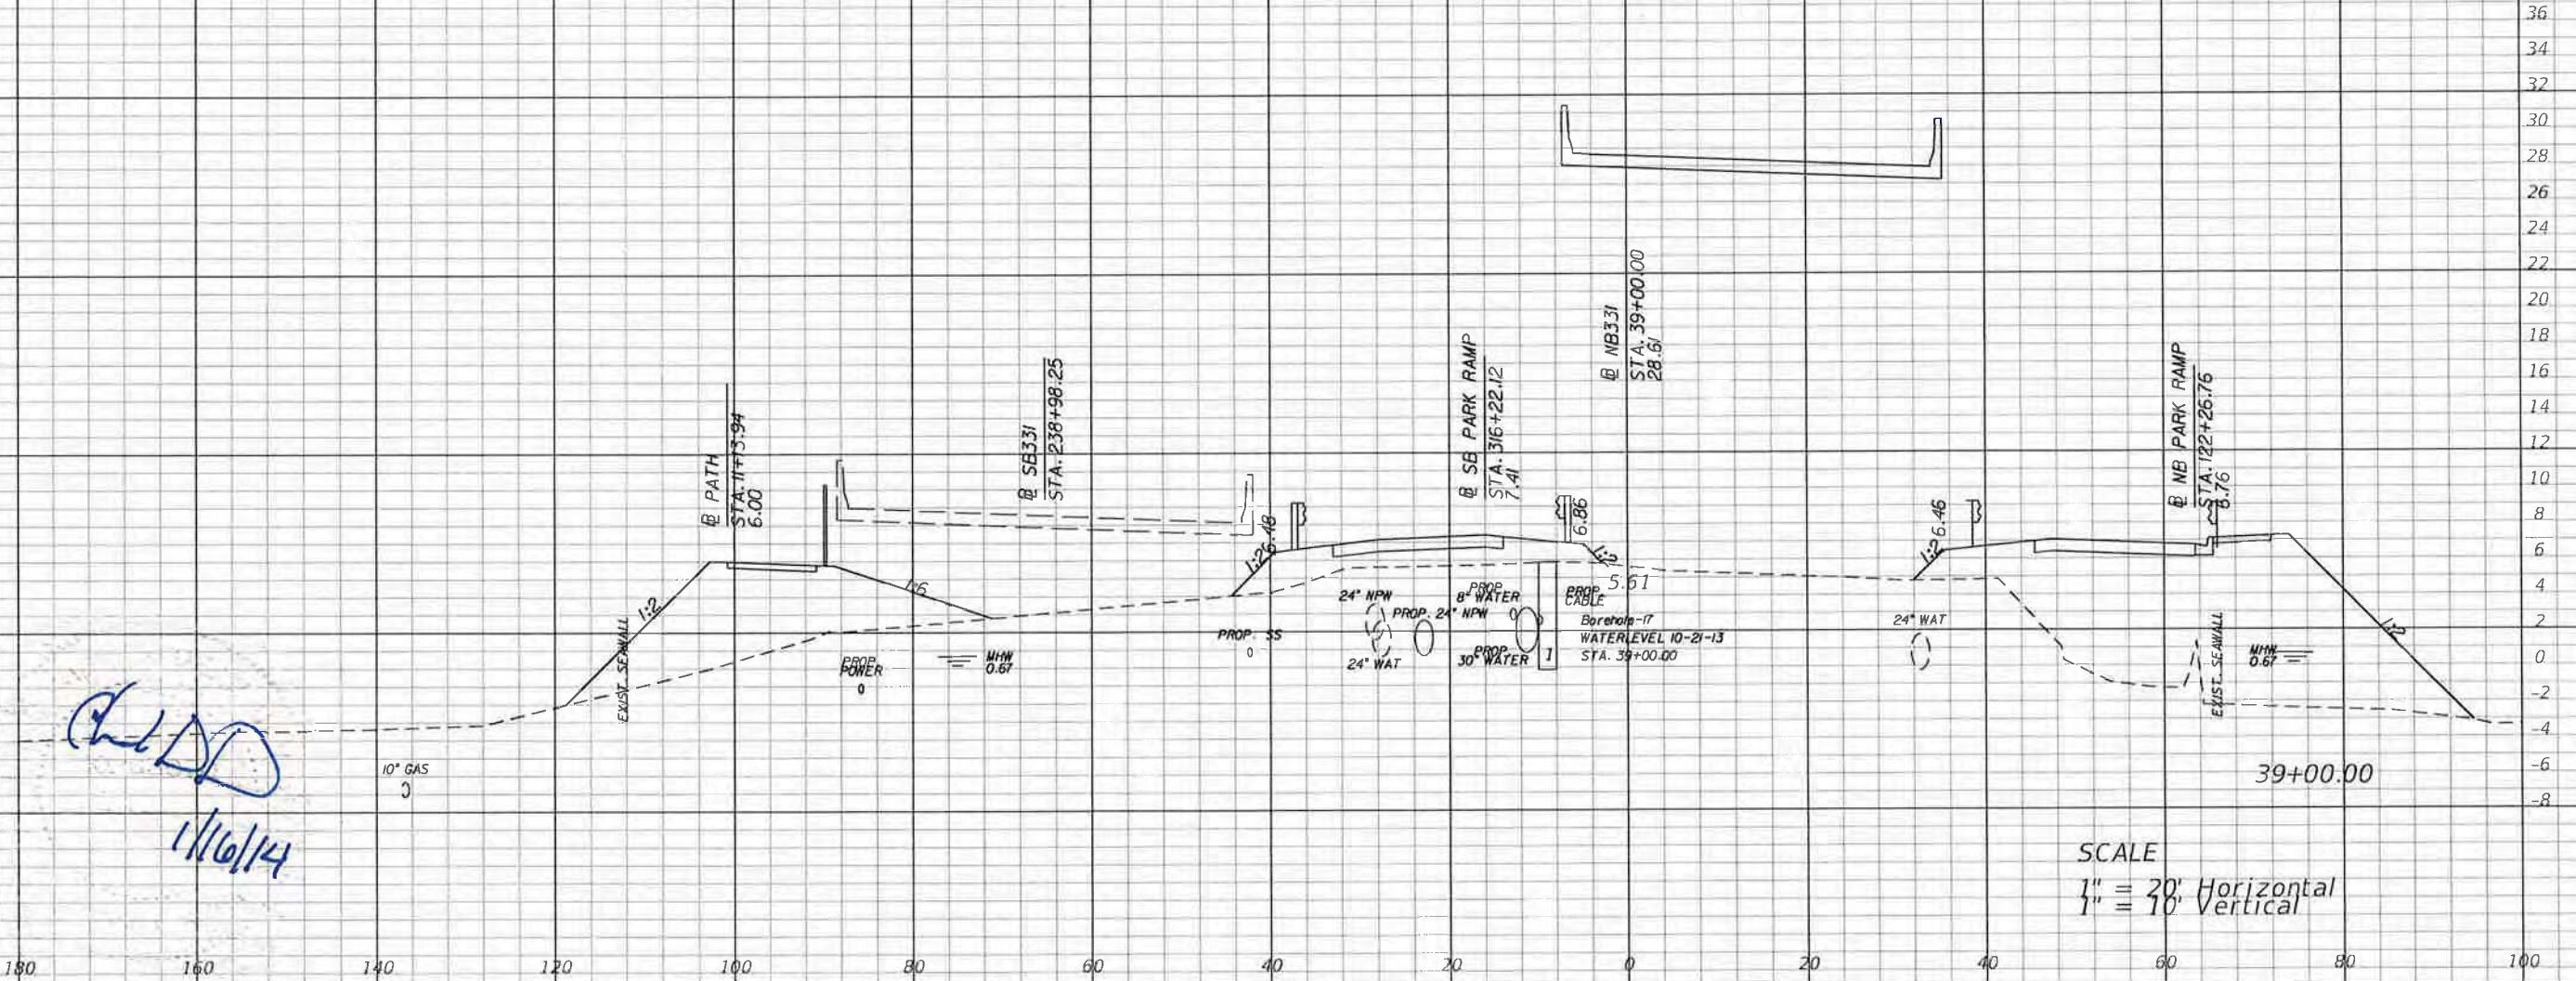



42  
40  
38  
36  
34  
32  
30  
28  
26  
24  
22  
20  
18  
16  
14  
12  
10  
8  
6  
4  
2  
0  
-2  
-4  
-6  
-8

42  
40  
38  
36  
34  
32  
30  
28  
26  
24  
22  
20  
18  
16  
14  
12  
10  
8  
6  
4  
2  
0  
-2  
-4  
-6  
-8

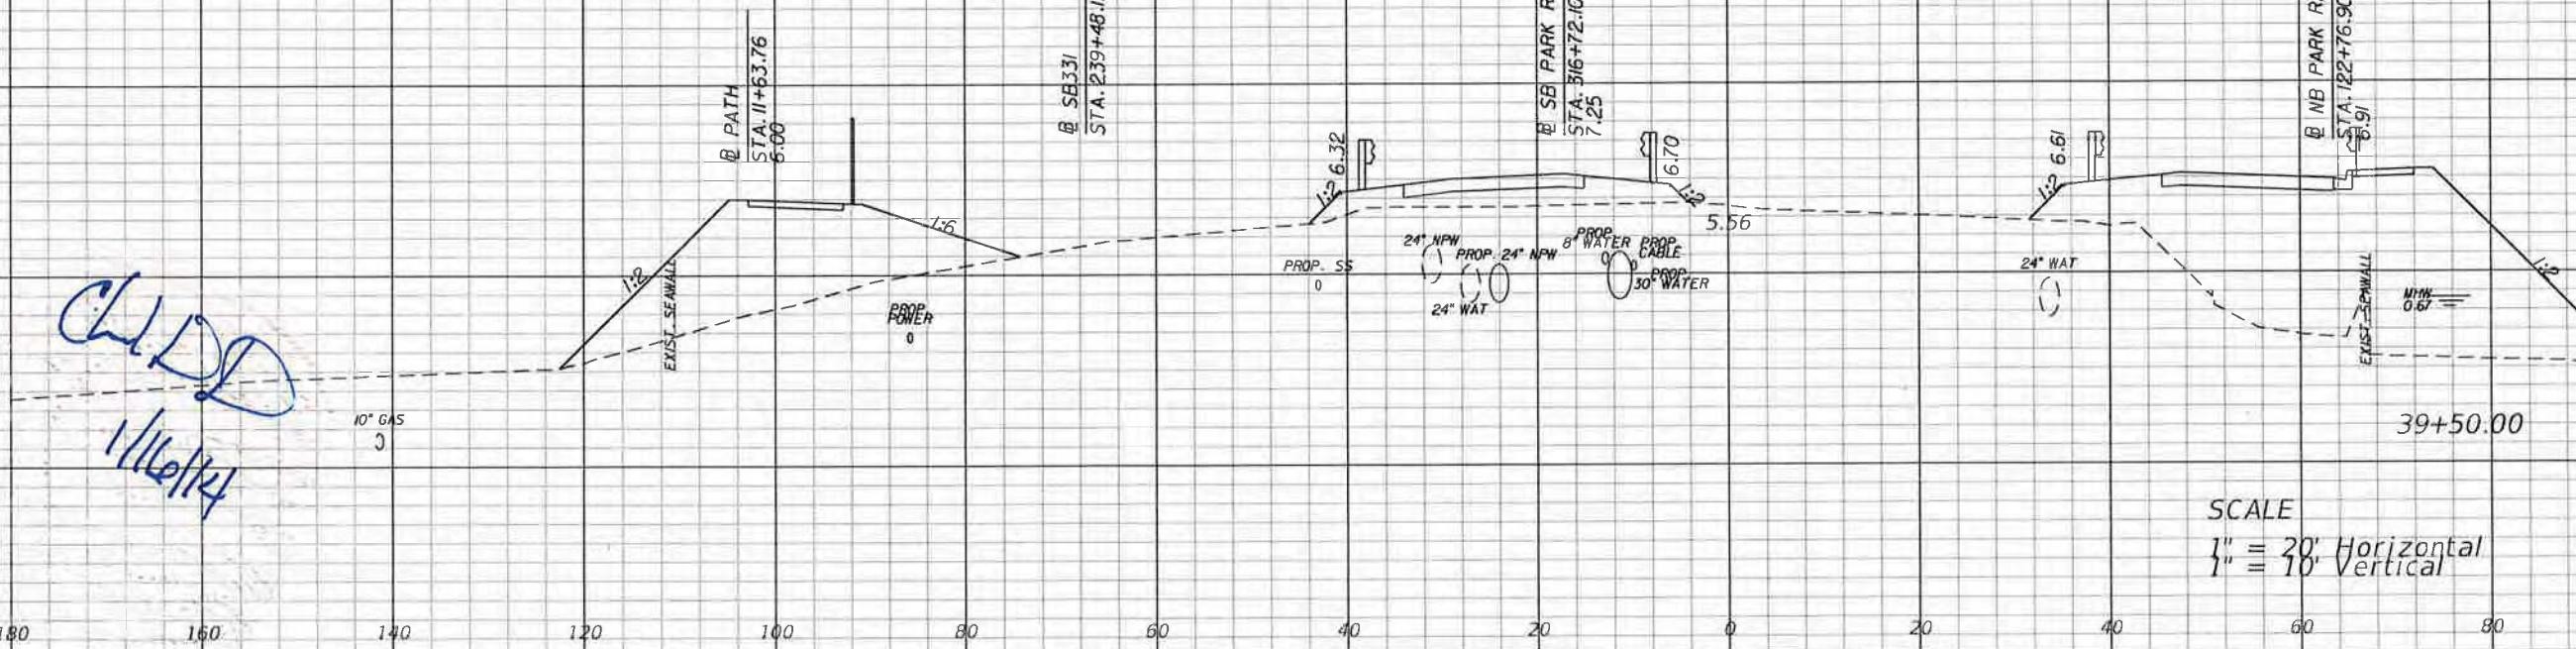

SCALE  
1" = 20' Horizontal  
1" = 10' Vertical

180 160 140 120 100 80 60 40 20 0 20 40 60 80 100

REVISIONS			
DATE	DESCRIPTION	DATE	DESCRIPTION

Parsons Brinckerhoff, Inc.  
121 W. Trade Street, Suite 1950  
Charlotte, NC 28202  
(704) 342-8469  
Cert. of Auth. No. 01462  
EOR: Christopher D. Davis, P.E. No. 63070

STATE OF FLORIDA DEPARTMENT OF TRANSPORTATION		
ROAD NO.	COUNTY	FINANCIAL PROJECT ID
83	WALTON	220664-2-52-01

CROSS SECTIONS

SHEET NO.  
148



42  
40  
38  
36  
34  
32  
30  
28  
26  
24  
22  
20  
18  
16  
14  
12  
10  
8  
6  
4  
2  
0  
-2  
-4  
-6  
-8

42  
40  
38  
36  
34  
32  
30  
28  
26  
24  
22  
20  
18  
16  
14  
12  
10  
8  
6  
4  
2  
0  
-2  
-4  
-6  
-8

180 160 140 120 100 80 60 40 20 0 20 40 60 80 100

REVISIONS

DATE	DESCRIPTION	DATE	DESCRIPTION

Parsons Brinckerhoff, Inc.  
121 W. Trade Street, Suite 1950  
Charlotte, NC 28202  
(704) 342-8469  
Cert. of Auth. No. 01462  
EOR: Christopher D Davis, P.E. No. 63070


STATE OF FLORIDA  
DEPARTMENT OF TRANSPORTATION

ROAD NO.	COUNTY	FINANCIAL PROJECT ID
83	WALTON	220664-2-52-01


SHEET NO.

149


### CROSS SECTIONS

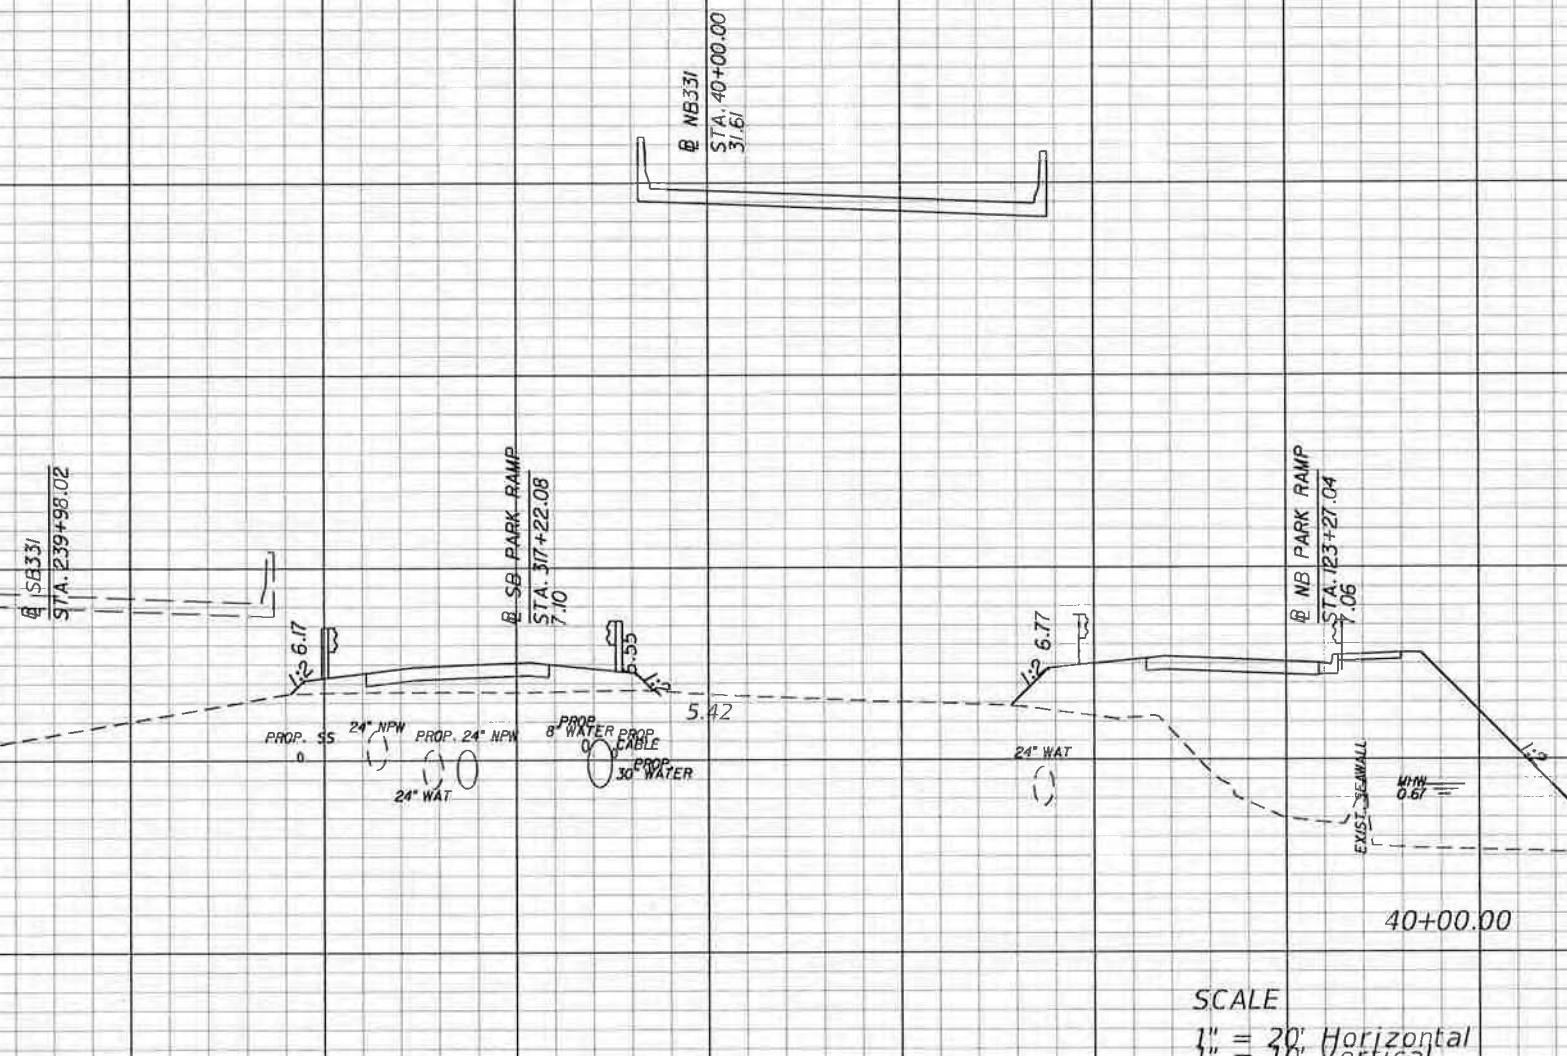

SCALE  
1" = 20' Horizontal  
1" = 10' Vertical

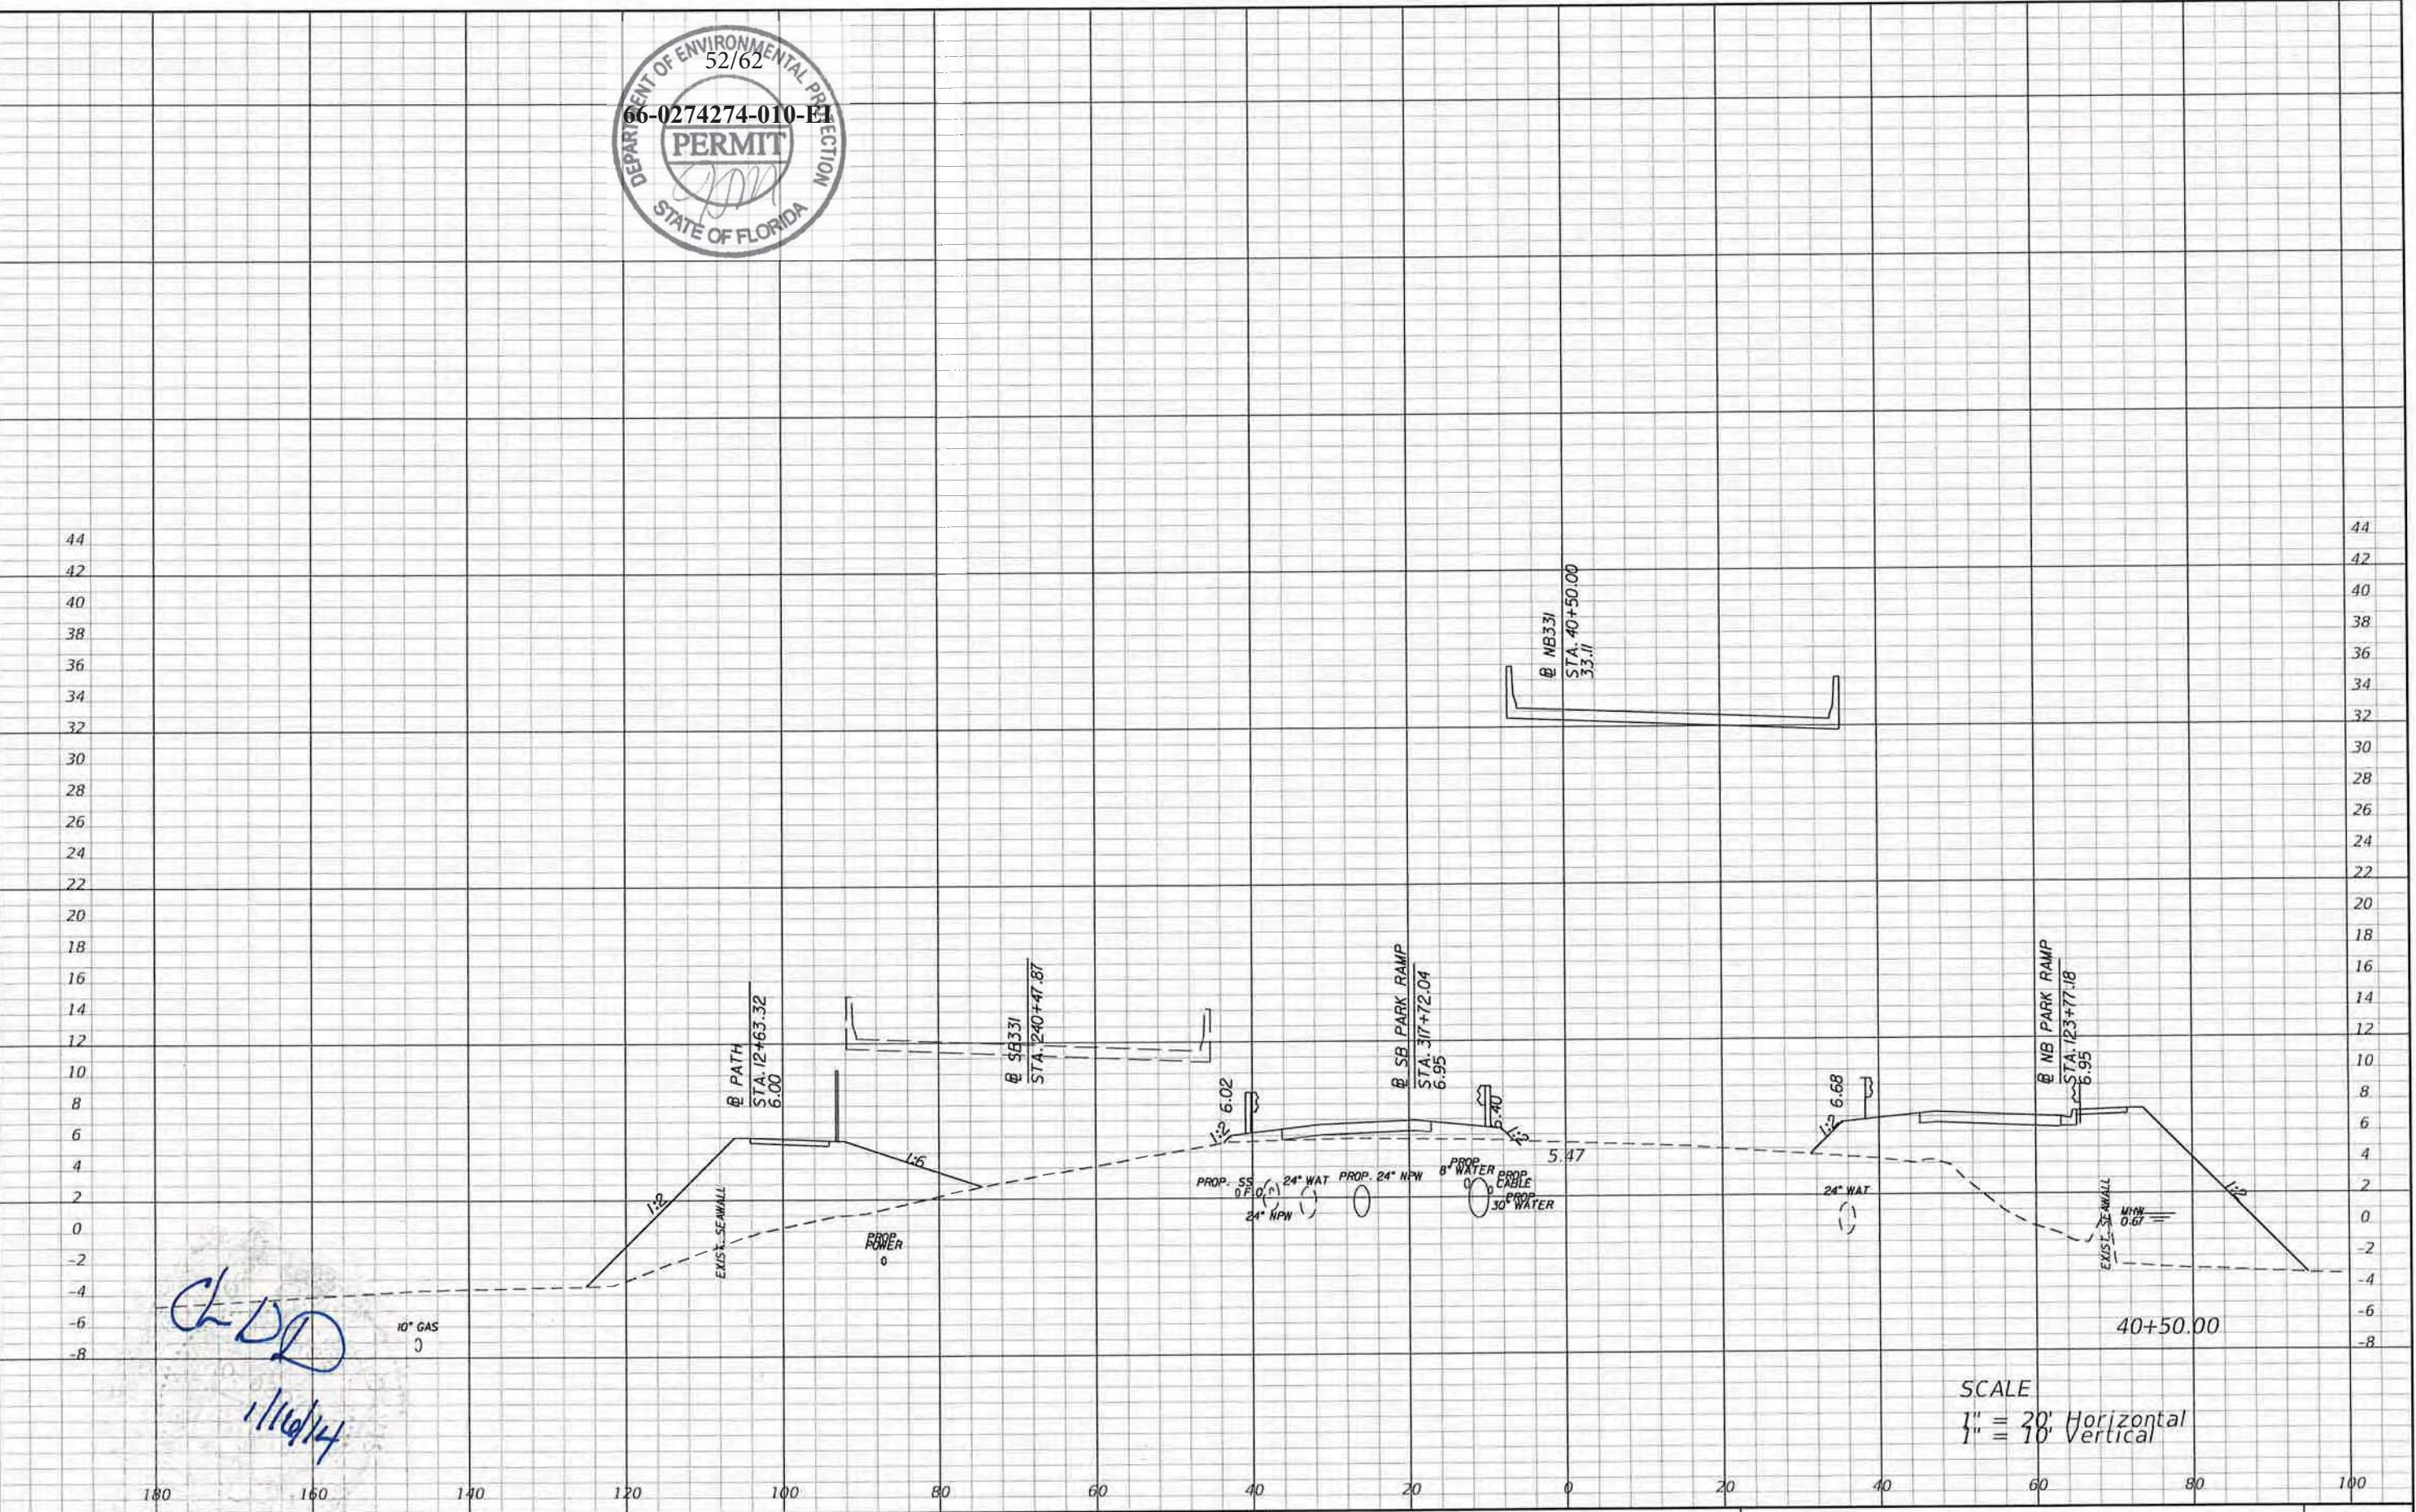


DATE	DESCRIPTION	DATE	DESCRIPTION	STATE OF FLORIDA DEPARTMENT OF TRANSPORTATION	SHEET NO.
				Parsons Brinckerhoff, Inc. 121 W. Trade Street, Suite 1950 Charlotte, NC 28202 (704) 342-8469 Cert. of Auth. No. 01462 EOR: Christopher D Davis, P.E. No. 63070	150

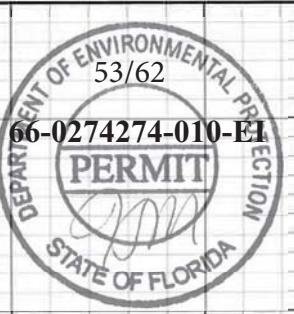

44  
42  
40  
38  
36  
34  
32  
30  
28  
26  
24  
22  
20  
18  
16  
14  
12  
10  
8  
6  
4  
2  
0  
-2  
-4  
-6  
-8

44  
42  
40  
38  
36  
34  
32  
30  
28  
26  
24  
22  
20  
18  
16  
14  
12  
10  
8  
6  
4  
2  
0  
-2  
-4  
-6  
-8

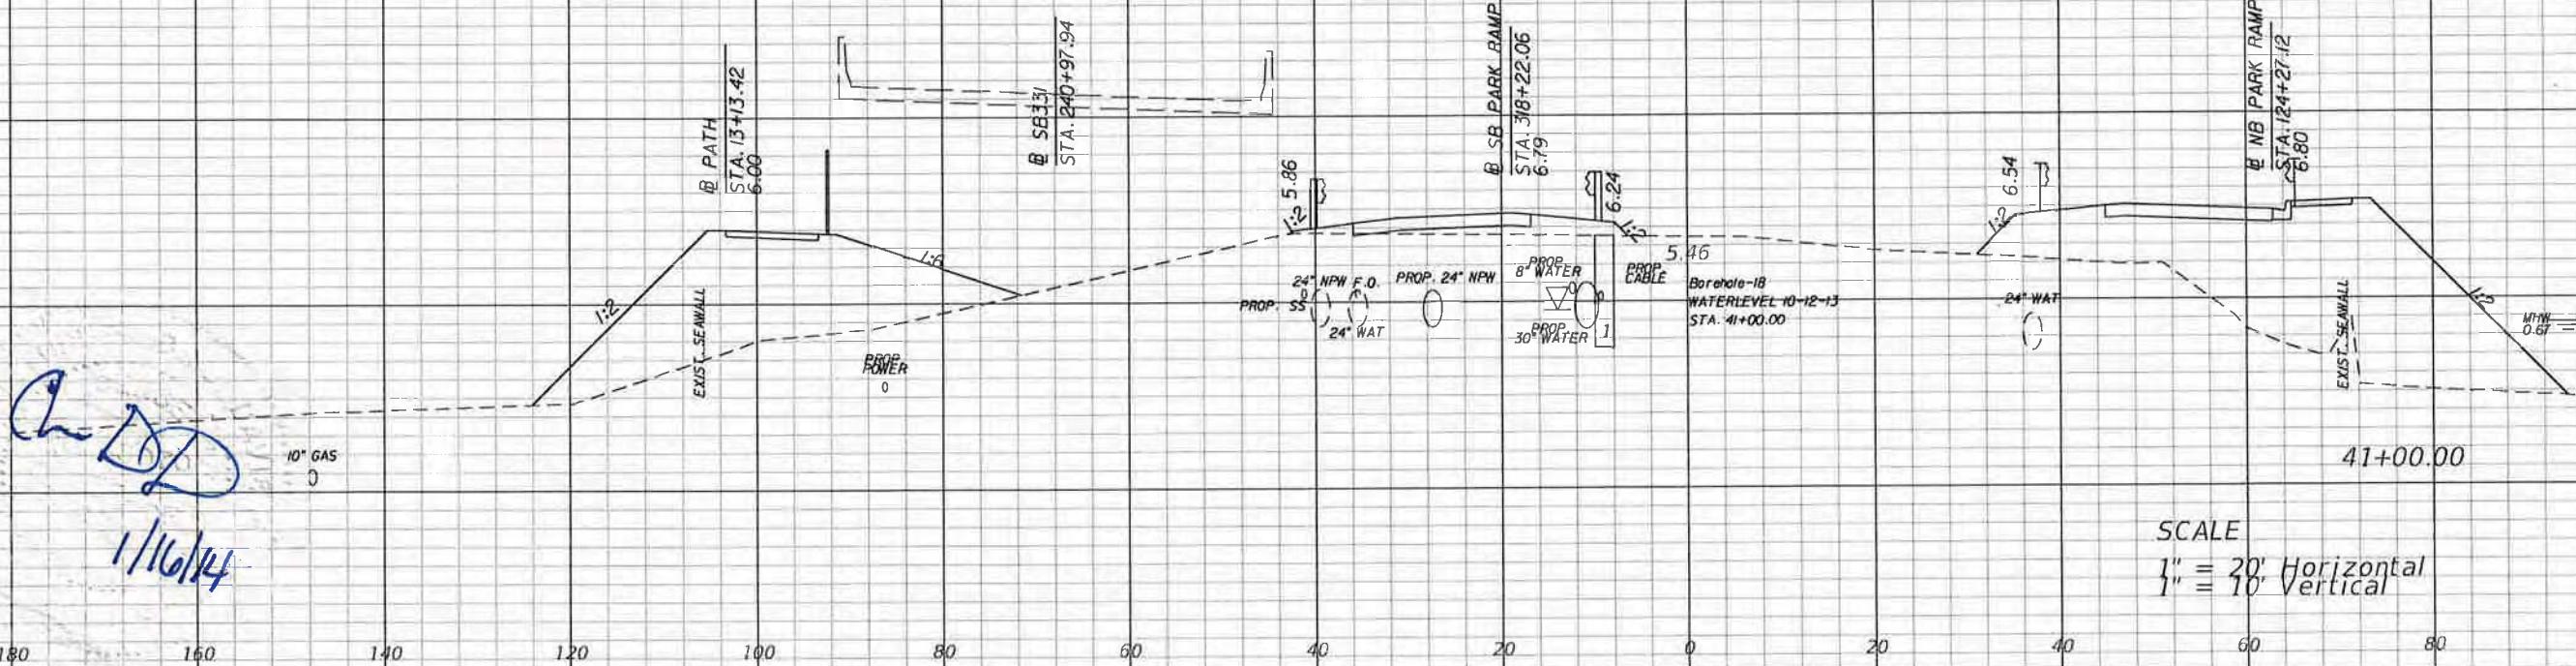

REVISIONS			
DATE	DESCRIPTION	DATE	DESCRIPTION

Parsons Brinckerhoff, Inc.  
121 W. Trade Street, Suite 1950  
Charlotte, NC 28202  
(704) 342-8469  
Cert. of Auth. No. 01462  
EOR: Christopher D Davis, P.E. No. 63070

STATE OF FLORIDA  
DEPARTMENT OF TRANSPORTATION  
ROAD NO. COUNTY FINANCIAL PROJECT ID  
83 WALTON 220664-2-52-01


CROSS SECTIONS

SHEET NO.  
151



42  
40  
38  
36  
34  
32  
30  
28  
26  
24  
22  
20  
18  
16  
14  
12  
10  
8  
6  
4  
2  
0  
-2  
-4  
-6  
-8

42  
40  
38  
36  
34  
32  
30  
28  
26  
24  
22  
20  
18  
16  
14  
12  
10  
8  
6  
4  
2  
0  
-2  
-4  
-6  
-8

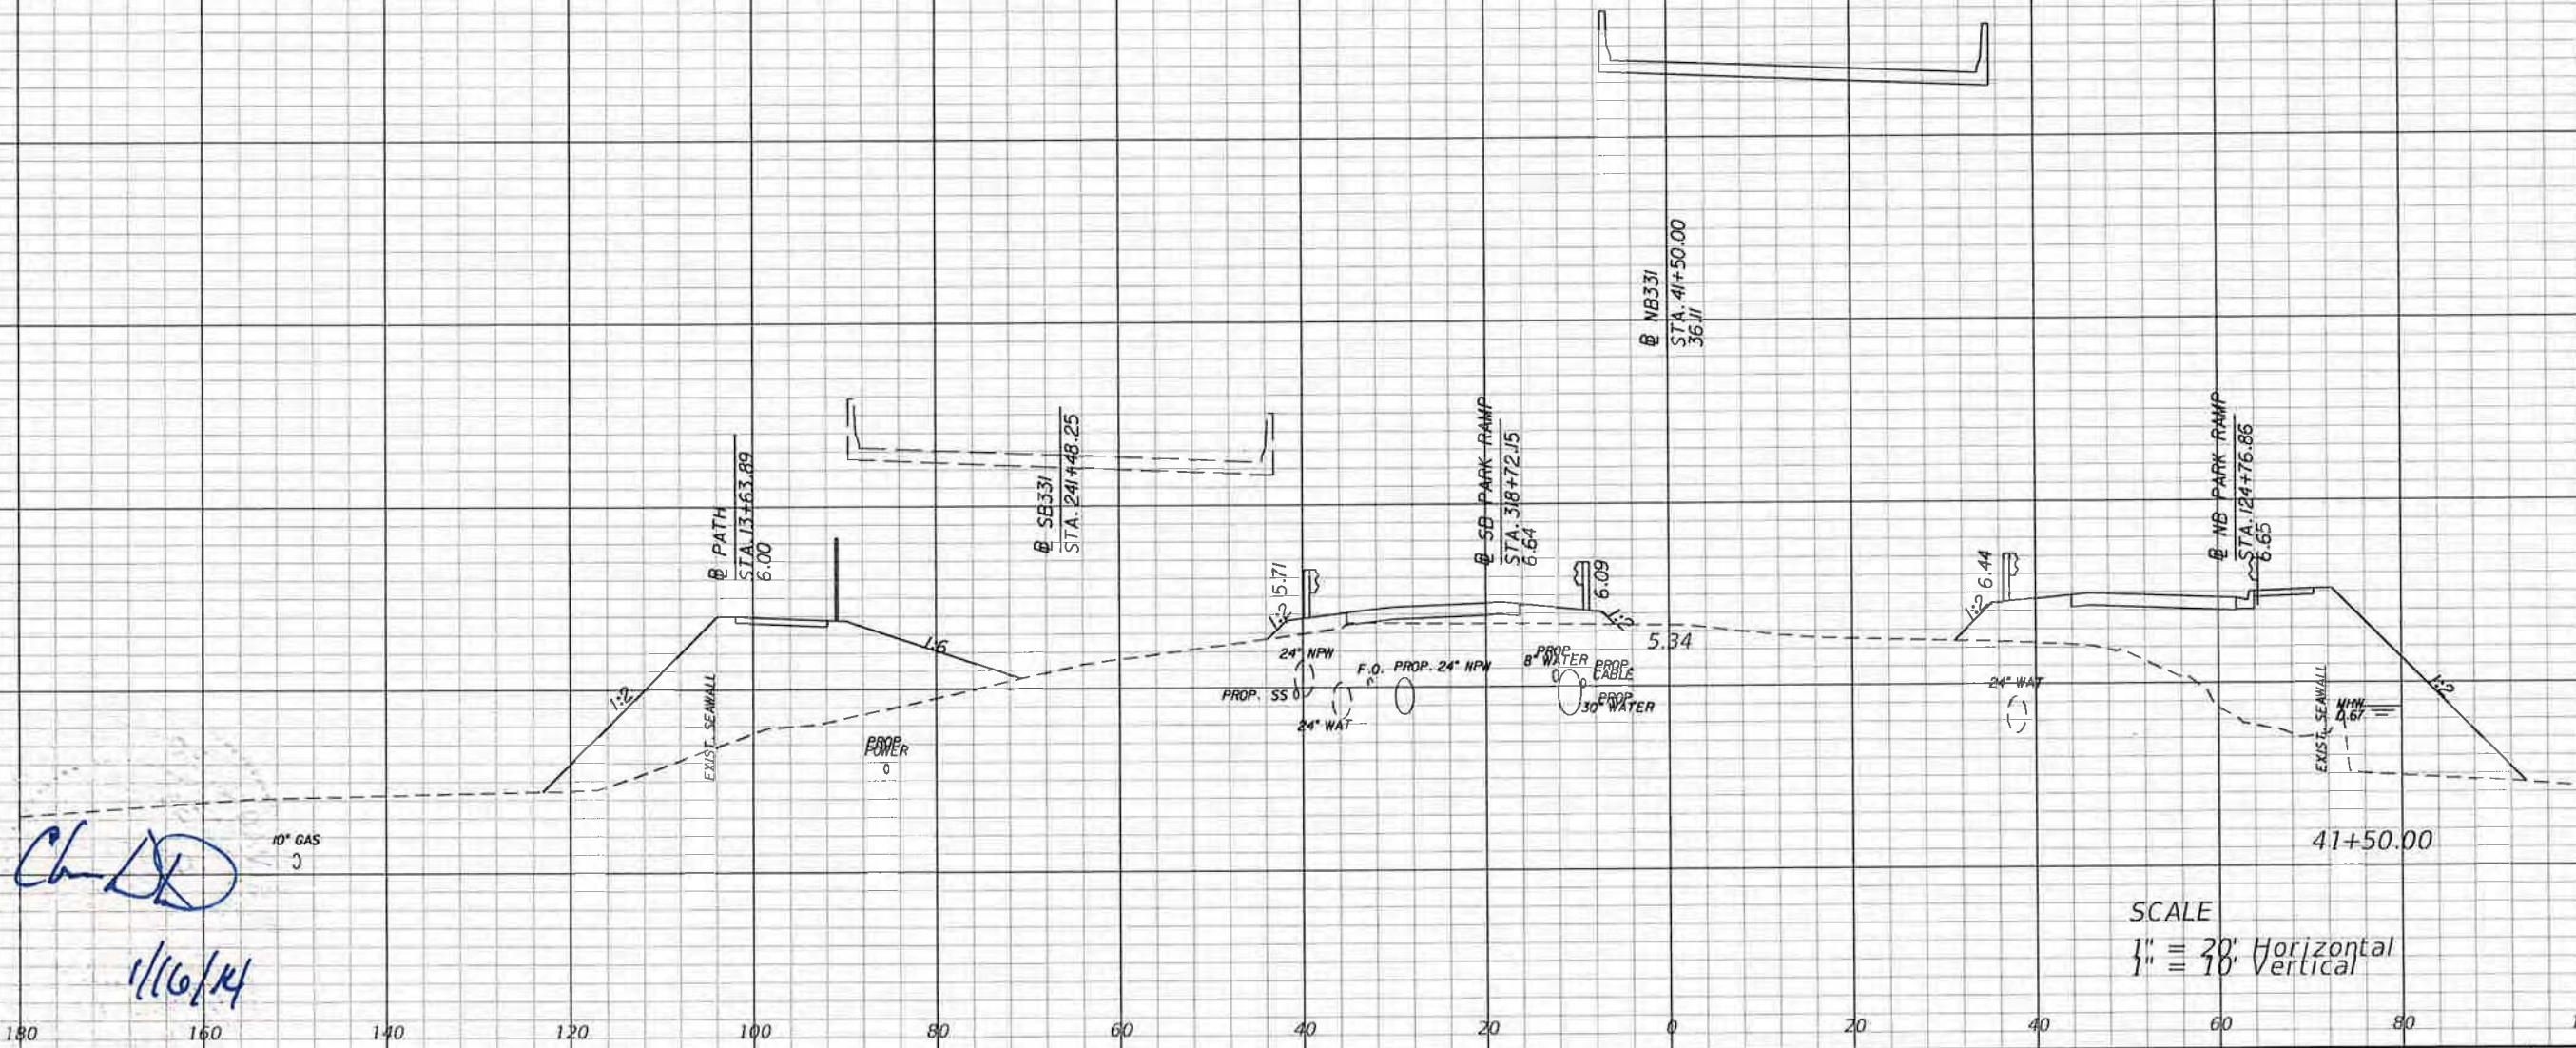

REVISIONS			
DATE	DESCRIPTION	DATE	DESCRIPTION

Parsons Brinckerhoff, Inc.  
121 W. Trade Street, Suite 1950  
Charlotte, NC 28202  
(704) 342-8469  
Cert. of Auth. No. 01462  
EOR: Christopher D Davis, P.E. No. 63070

STATE OF FLORIDA  
DEPARTMENT OF TRANSPORTATION

ROAD NO.	COUNTY	FINANCIAL PROJECT ID
83	WALTON	220664-2-52-01


### CROSS SECTIONS

SHEET NO.  
152



44  
42  
40  
38  
36  
34  
32  
30  
28  
26  
24  
22  
20  
18  
16  
14  
12  
10  
8  
6  
4  
2  
0  
-2  
-4  
-6  
-8

44  
42  
40  
38  
36  
34  
32  
30  
28  
26  
24  
22  
20  
18  
16  
14  
12  
10  
8  
6  
4  
2  
0  
-2  
-4  
-6  
-8

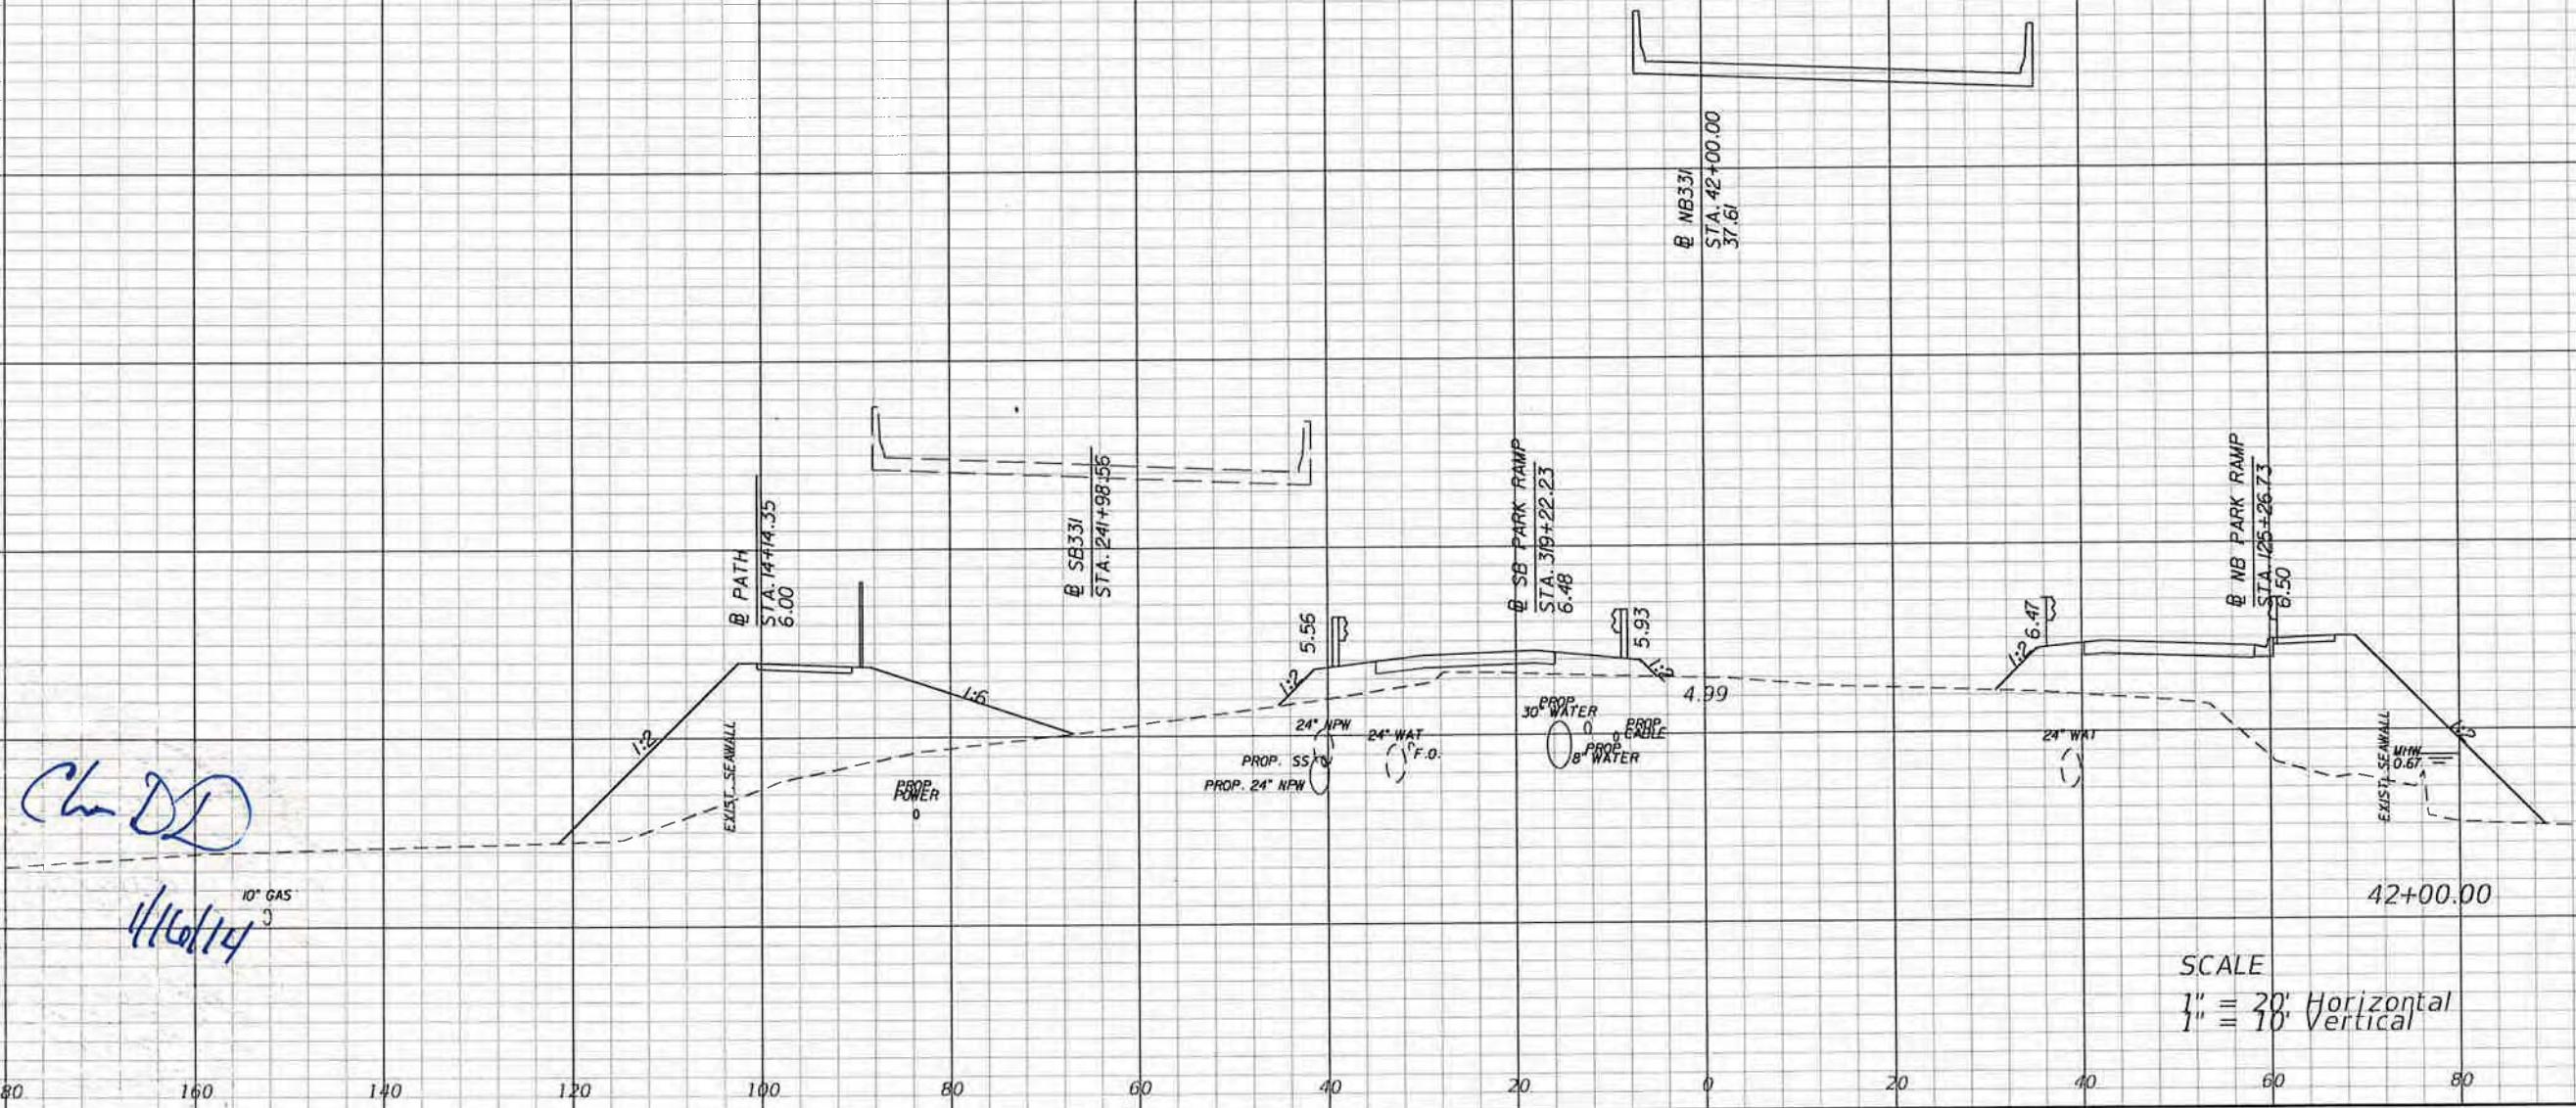

REVISIONS			
DATE	DESCRIPTION	DATE	DESCRIPTION


Parsons Brinckerhoff, Inc.  
121 W. Trade Street, Suite 1950  
Charlotte, NC 28202  
(704) 342-8469  
Cert. of Auth. No. 01462  
EOR: Christopher D Davis, P.E. No. 63070

STATE OF FLORIDA  
DEPARTMENT OF TRANSPORTATION

ROAD NO.	COUNTY	FINANCIAL PROJECT ID
83	WALTON	220664-2-52-01

### CROSS SECTIONS

SHEET NO.  
153

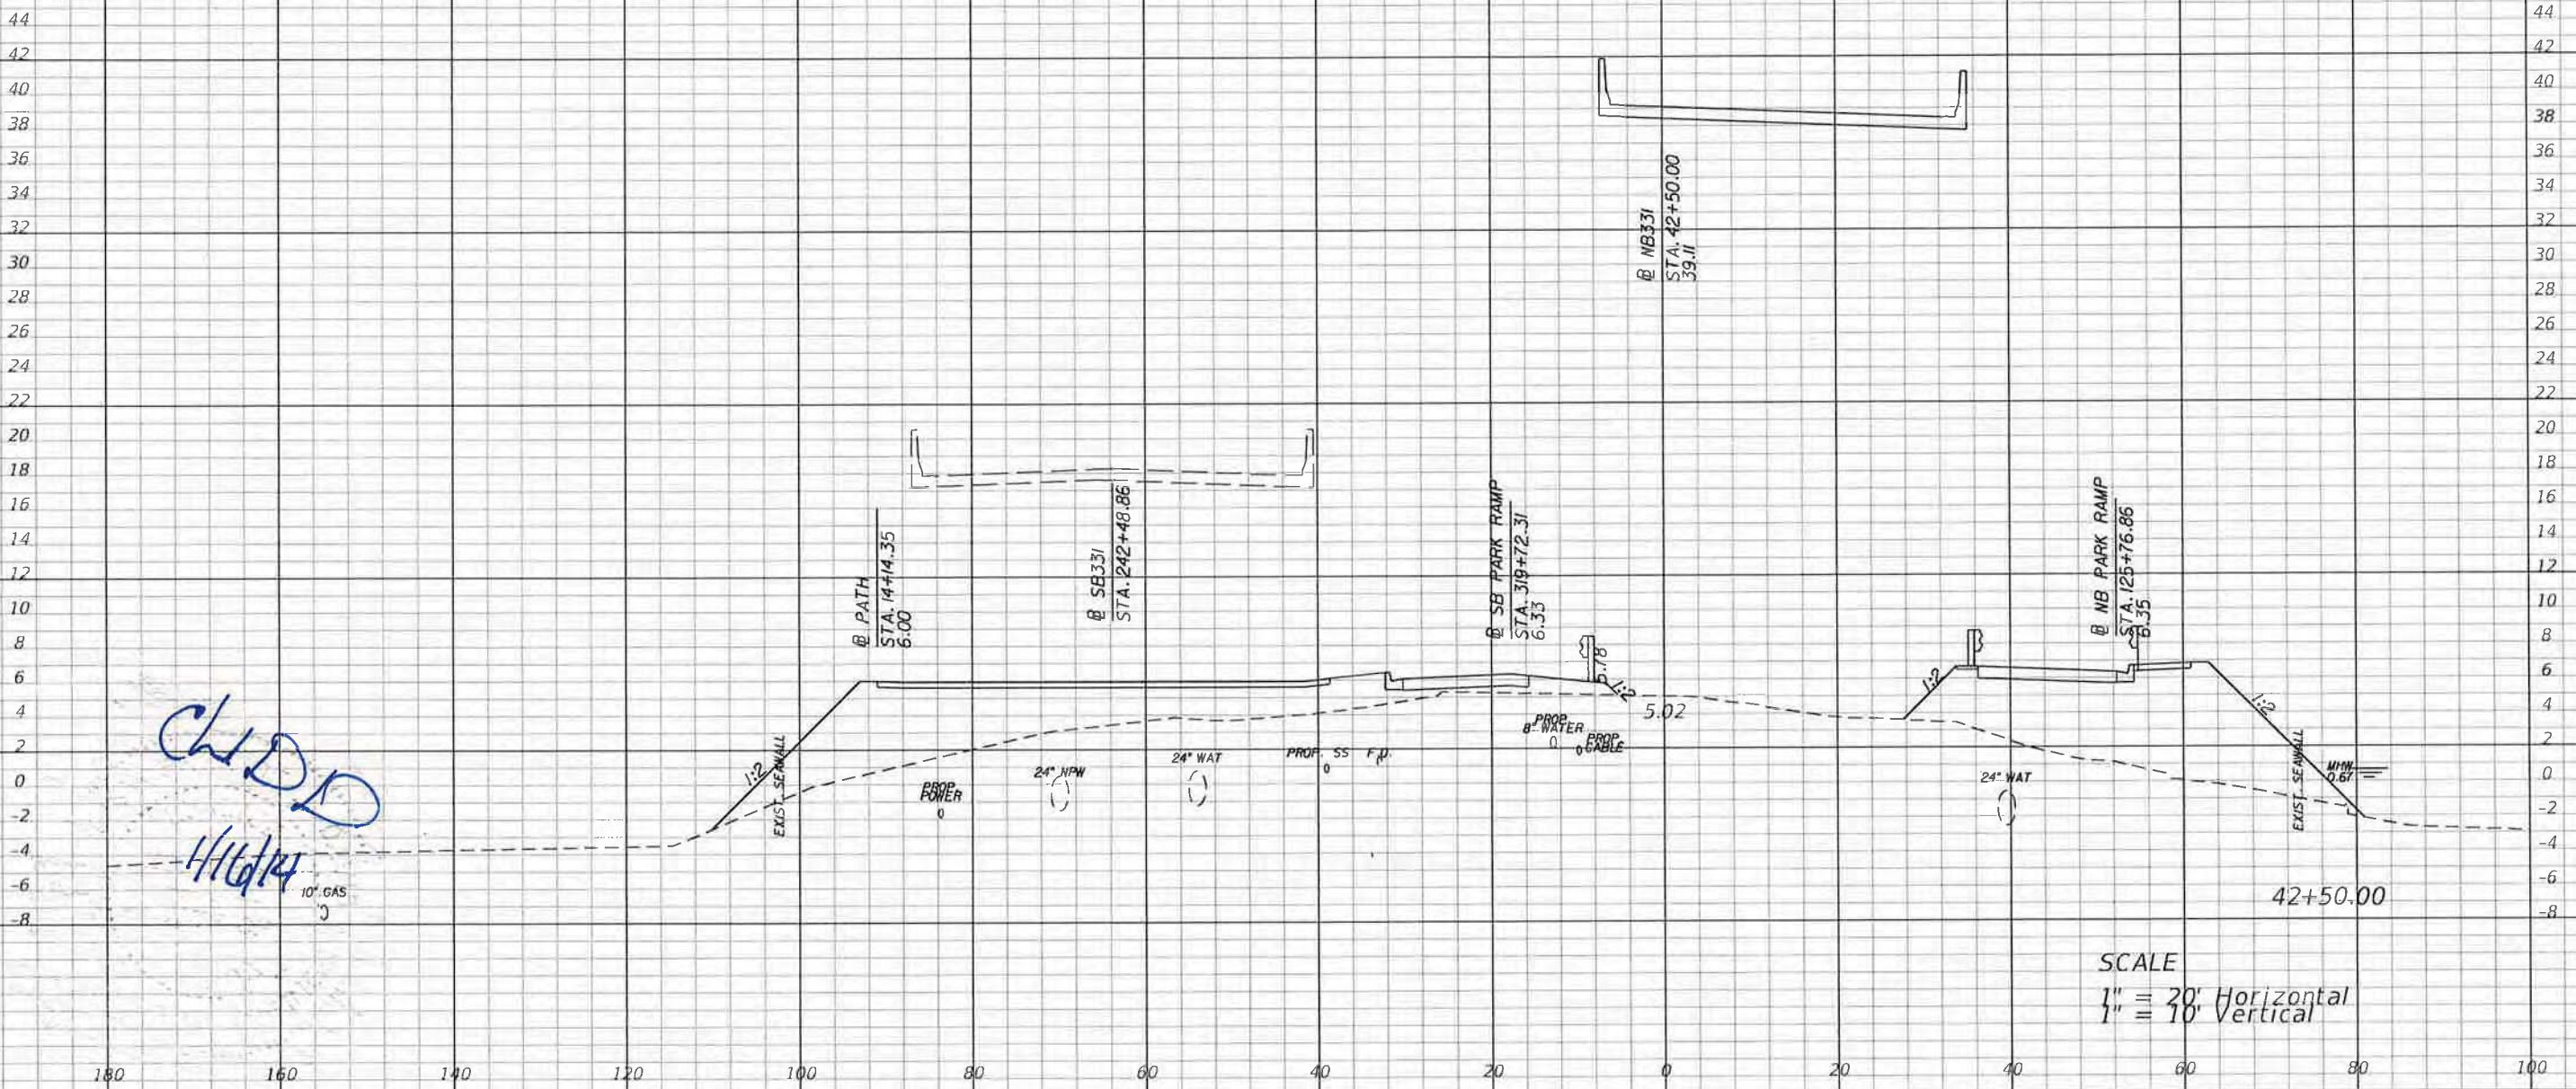

REVISIONS			
DATE	DESCRIPTION	DATE	DESCRIPTION

Parsons Brinckerhoff, Inc.  
121 W. Trade Street, Suite 1950  
Charlotte, NC 28202  
(704) 342-8469  
Cert. of Auth. No. 01462  
EOR: Christopher D Davis, P.E. No. 63070


STATE OF FLORIDA  
DEPARTMENT OF TRANSPORTATION  
ROAD NO. COUNTY FINANCIAL PROJECT ID  
83 WALTON 220664-2-52-01

### CROSS SECTIONS

SHEET NO.  
154



66-0274274-010-EL  
PERMIT

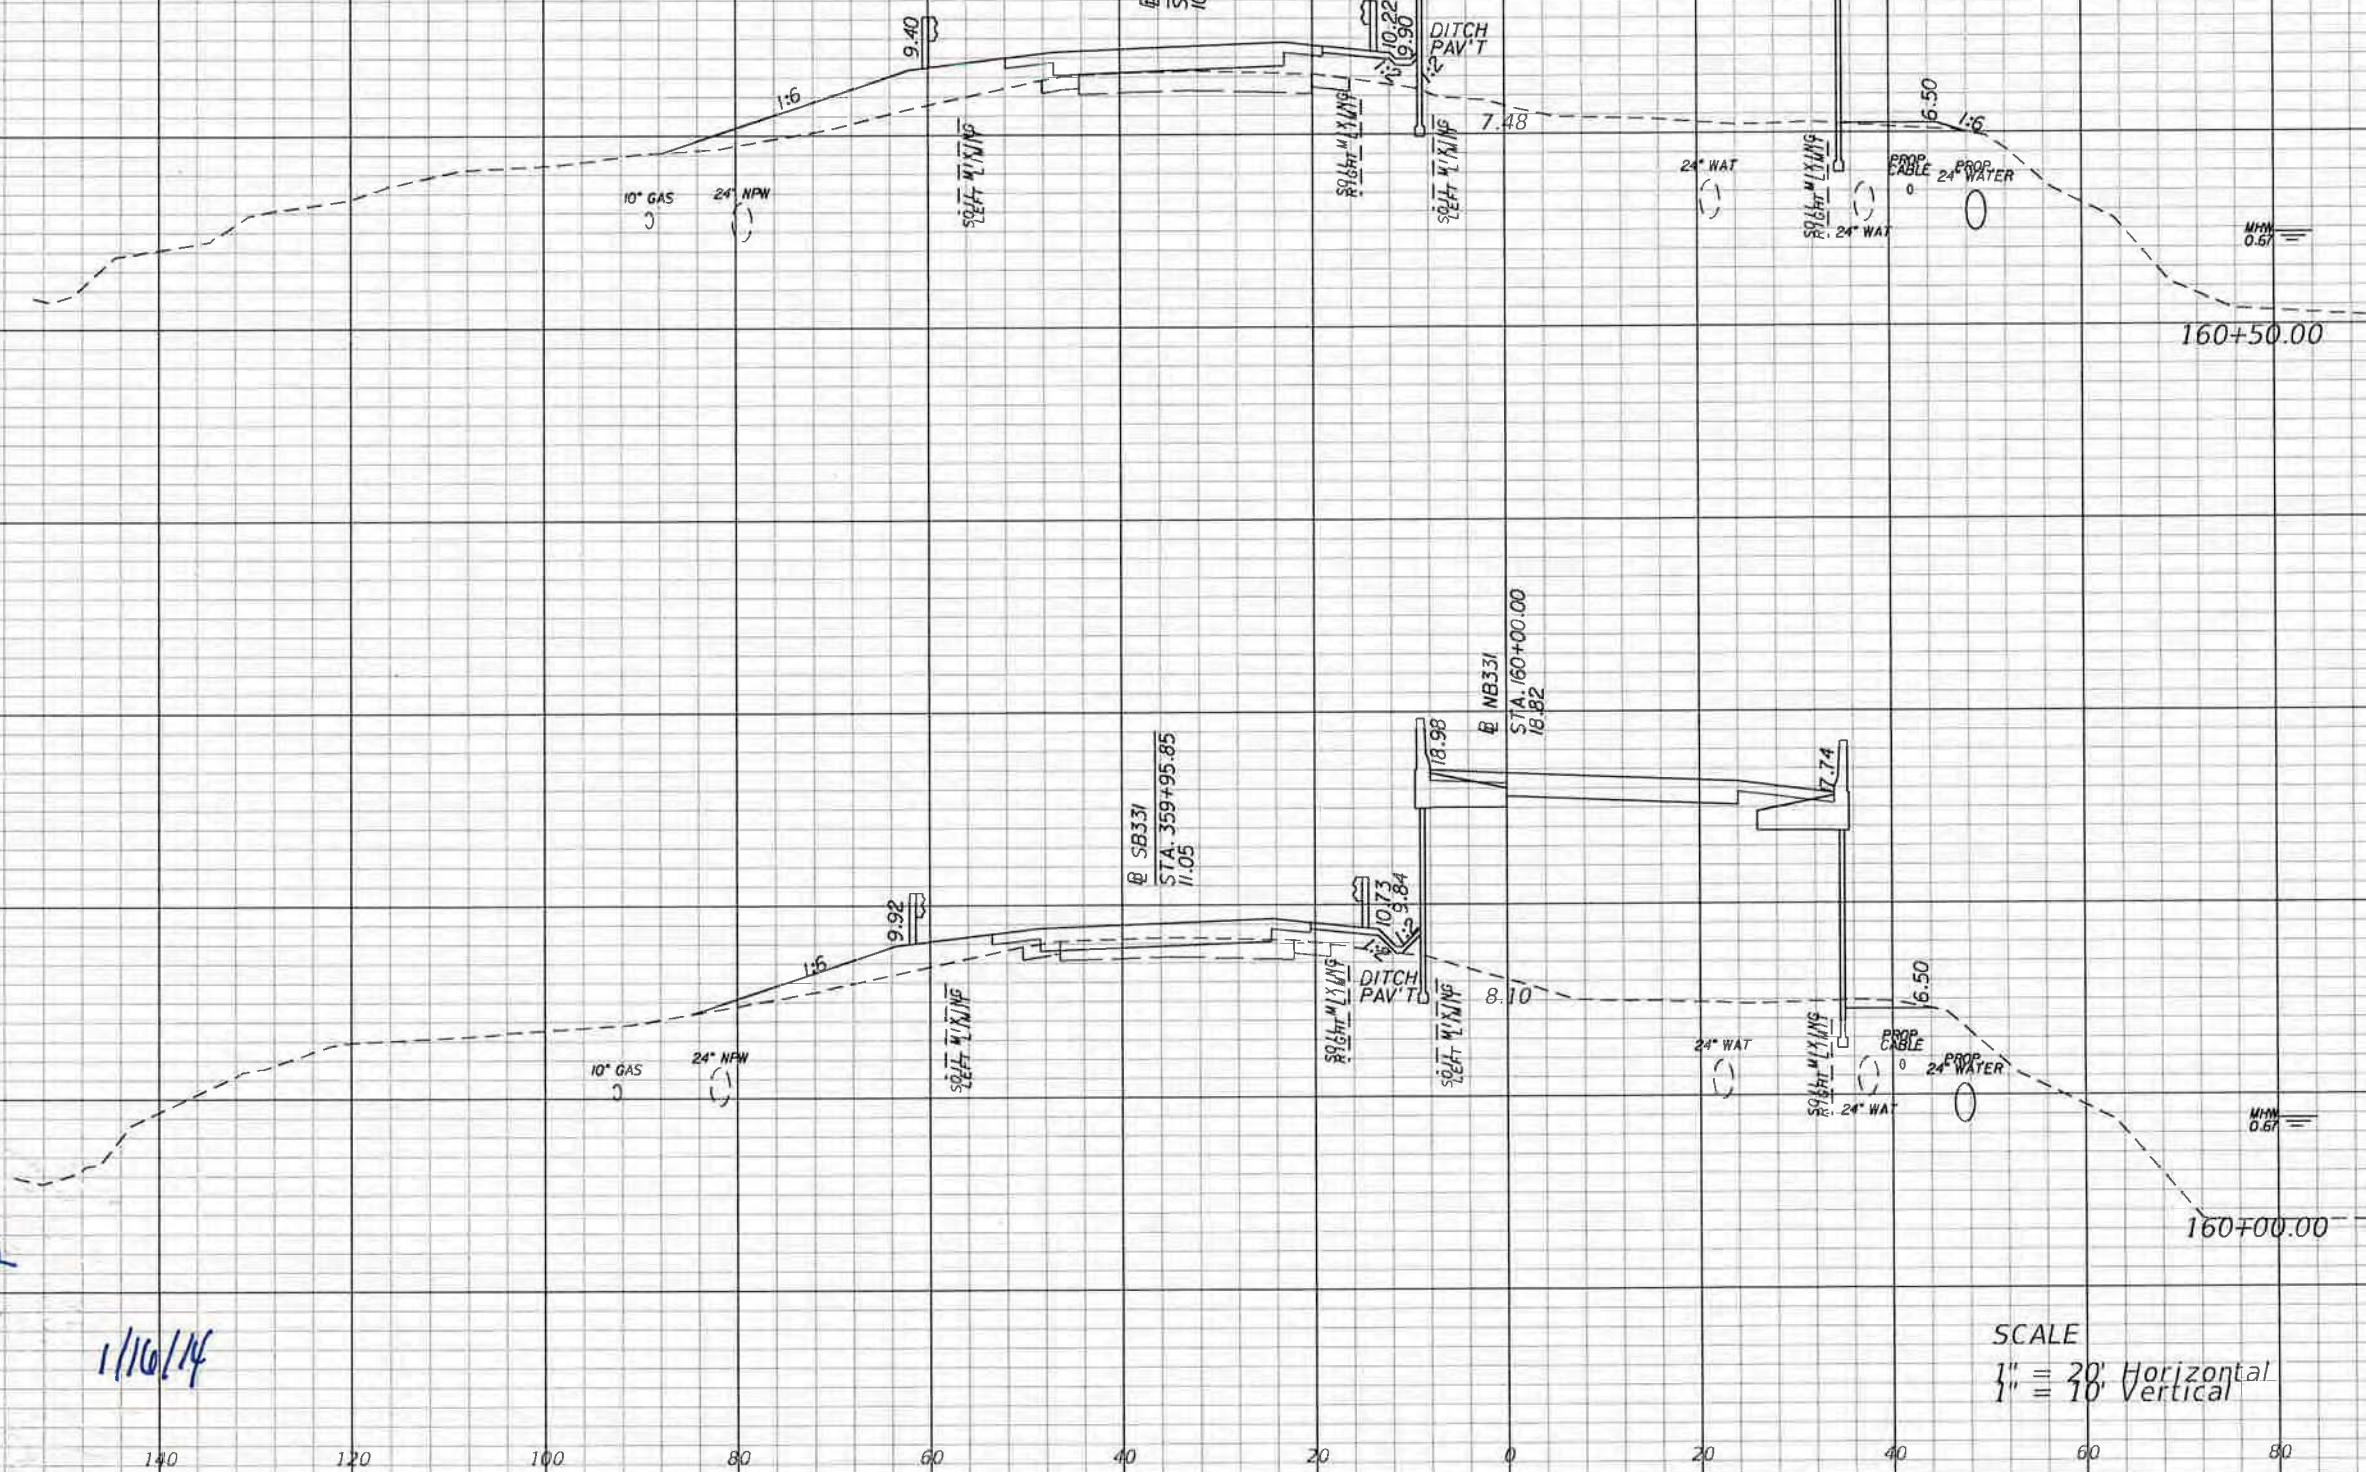


REVISIONS			
DATE	DESCRIPTION	DATE	DESCRIPTION

Parsons Brinckerhoff, Inc.  
121 W. Trade Street, Suite 1950  
Charlotte, NC 28202  
(704) 342-8469  
Cert. of Auth. No. 01462  
EOR: Christopher D Davis, P.E. No. 63070

STATE OF FLORIDA  
DEPARTMENT OF TRANSPORTATION  
ROAD NO. COUNTY FINANCIAL PROJECT ID  
83 WALTON 220664-2-52-01

CROSS SECTIONS

SHEET NO.  
249

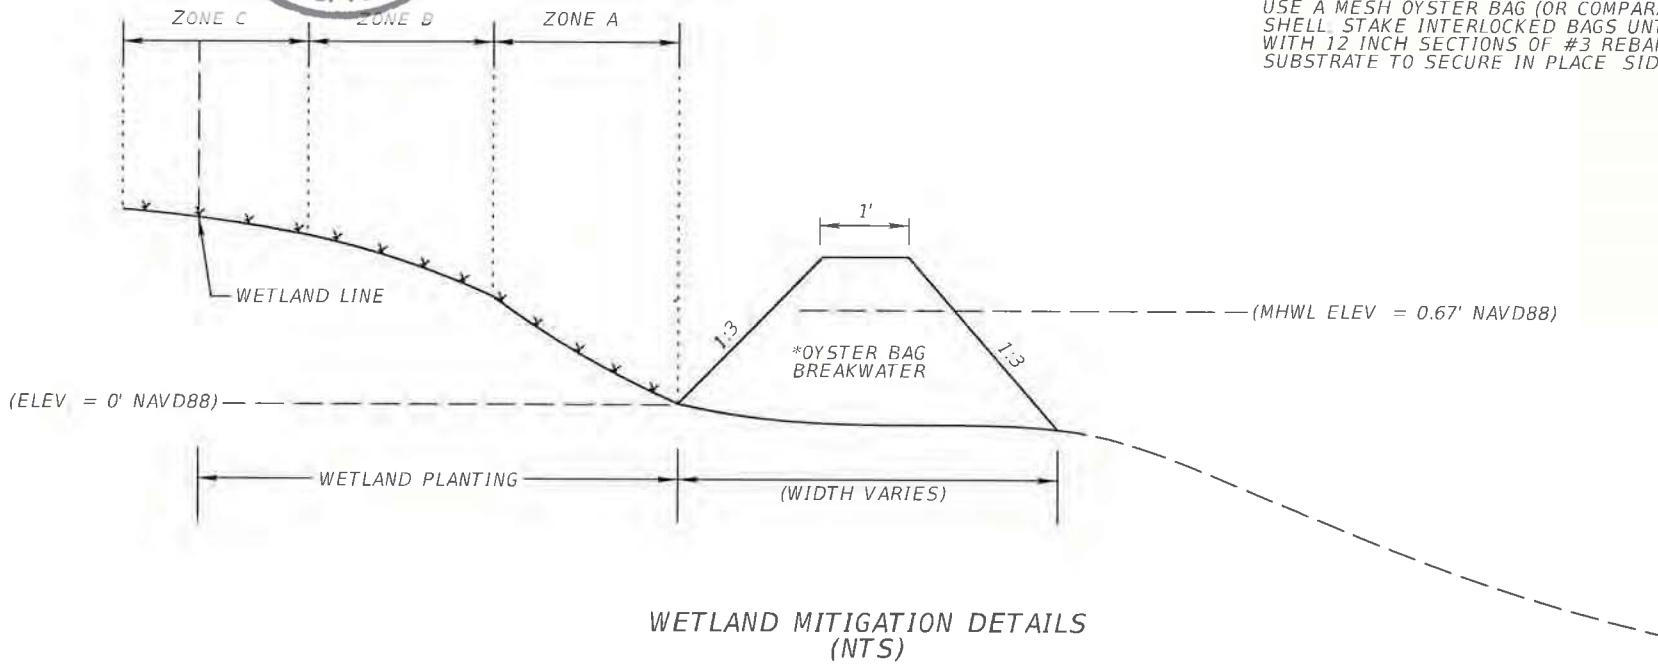

\*PLACE GEOTEXTILE FABRIC UNDER FOOTPRINT OF OYSTERBAG BREAKWATER SEGMENTS  
USE A MESH OYSTER BAG (OR COMPARABLE) FILLED WITH 30LBS OF WASHED OYSTER  
SHELL STAKE INTERLOCKED BAGS UNTIL REACHING THE DESIRED ELEVATION. STAKE  
WITH 12 INCH SECTIONS OF #3 REBAR STAKES (OR COMPARABLE) INTO THE BAG AND/OR  
SUBSTRATE TO SECURE IN PLACE SIDE SLOPES ARE 1:3



NOTE: In areas to be planted, all rip rap and rubble will be removed to one foot below the planting surface.

**CHOCTAWHATCHEE BAY BRIDGE - ONSITE MITIGATION AREA  
PLANTING PLAN**

WETLAND TYPE	ZONE	ACREAGE	SQUARE FEET	ELEVATION	SCIENTIFIC NAME	COMMON NAME	PERCENT COVER	SIZE	SPACING O.C. (ft.)	PLANT QUANTITY
HERBACEOUS										
LOW MARSH	A	0.27	11,925	0 to 1	SPARTINA ALTERNIFLORA	SMOOTH CORDGRASS	100%	2" CELL	3.0	1,325
					SHRUB					
HERBACEOUS										
HIGH MARSH	B	0.48	20,762	1 to 2	JUNCUS ROMERIANUS	BLACK NEEDLE RUSH	50%	2" CELL	3.0	1,153
					SPARTINA PATENS	SALTMARSH CORDGRASS	50%	2" CELL	3.0	1,154
HERBACEOUS										
TRANSITIONAL AREA	C	0.33 (0.14 WITHIN WEA)	14,241	>2	GARILLARDIA AESTIVALIS	BLANKET FLOWER	15%	2" CELL	3.0	238
					IVA FRUTESCENS	MARSH ELDER	25%	2" CELL	5.0	142
					MUHLENBERGIA CAPILLARIS	MUHLY GRASS	35%	4"	5.0	200
					SPARTINA BAKERI	SAND CORDGRASS	25%	1 GALLON	5.0	142

\*MHWL IS 0.67 NAVD88


REVISIONS				Parsons Brinckerhoff, Inc. 121 W. Trade Street, Suite 1950 Charlotte, NC 28202 (704) 342-8469 Cert. of Auth. No. 01462 EOR: Christopher D Davis, P.E. No. 63070	STATE OF FLORIDA DEPARTMENT OF TRANSPORTATION			TYPICAL SECTION DETAILS (3)	SHEET NO. 17
DATE	DESCRIPTION	DATE	DESCRIPTION		ROAD NO.	COUNTY	FINANCIAL PROJECT ID		
					83	WALTON	220664-2-52-01		


SEE PLAN SHEET (21)




0 10 50  
Feet

SCALE: 1"=50'  
1"

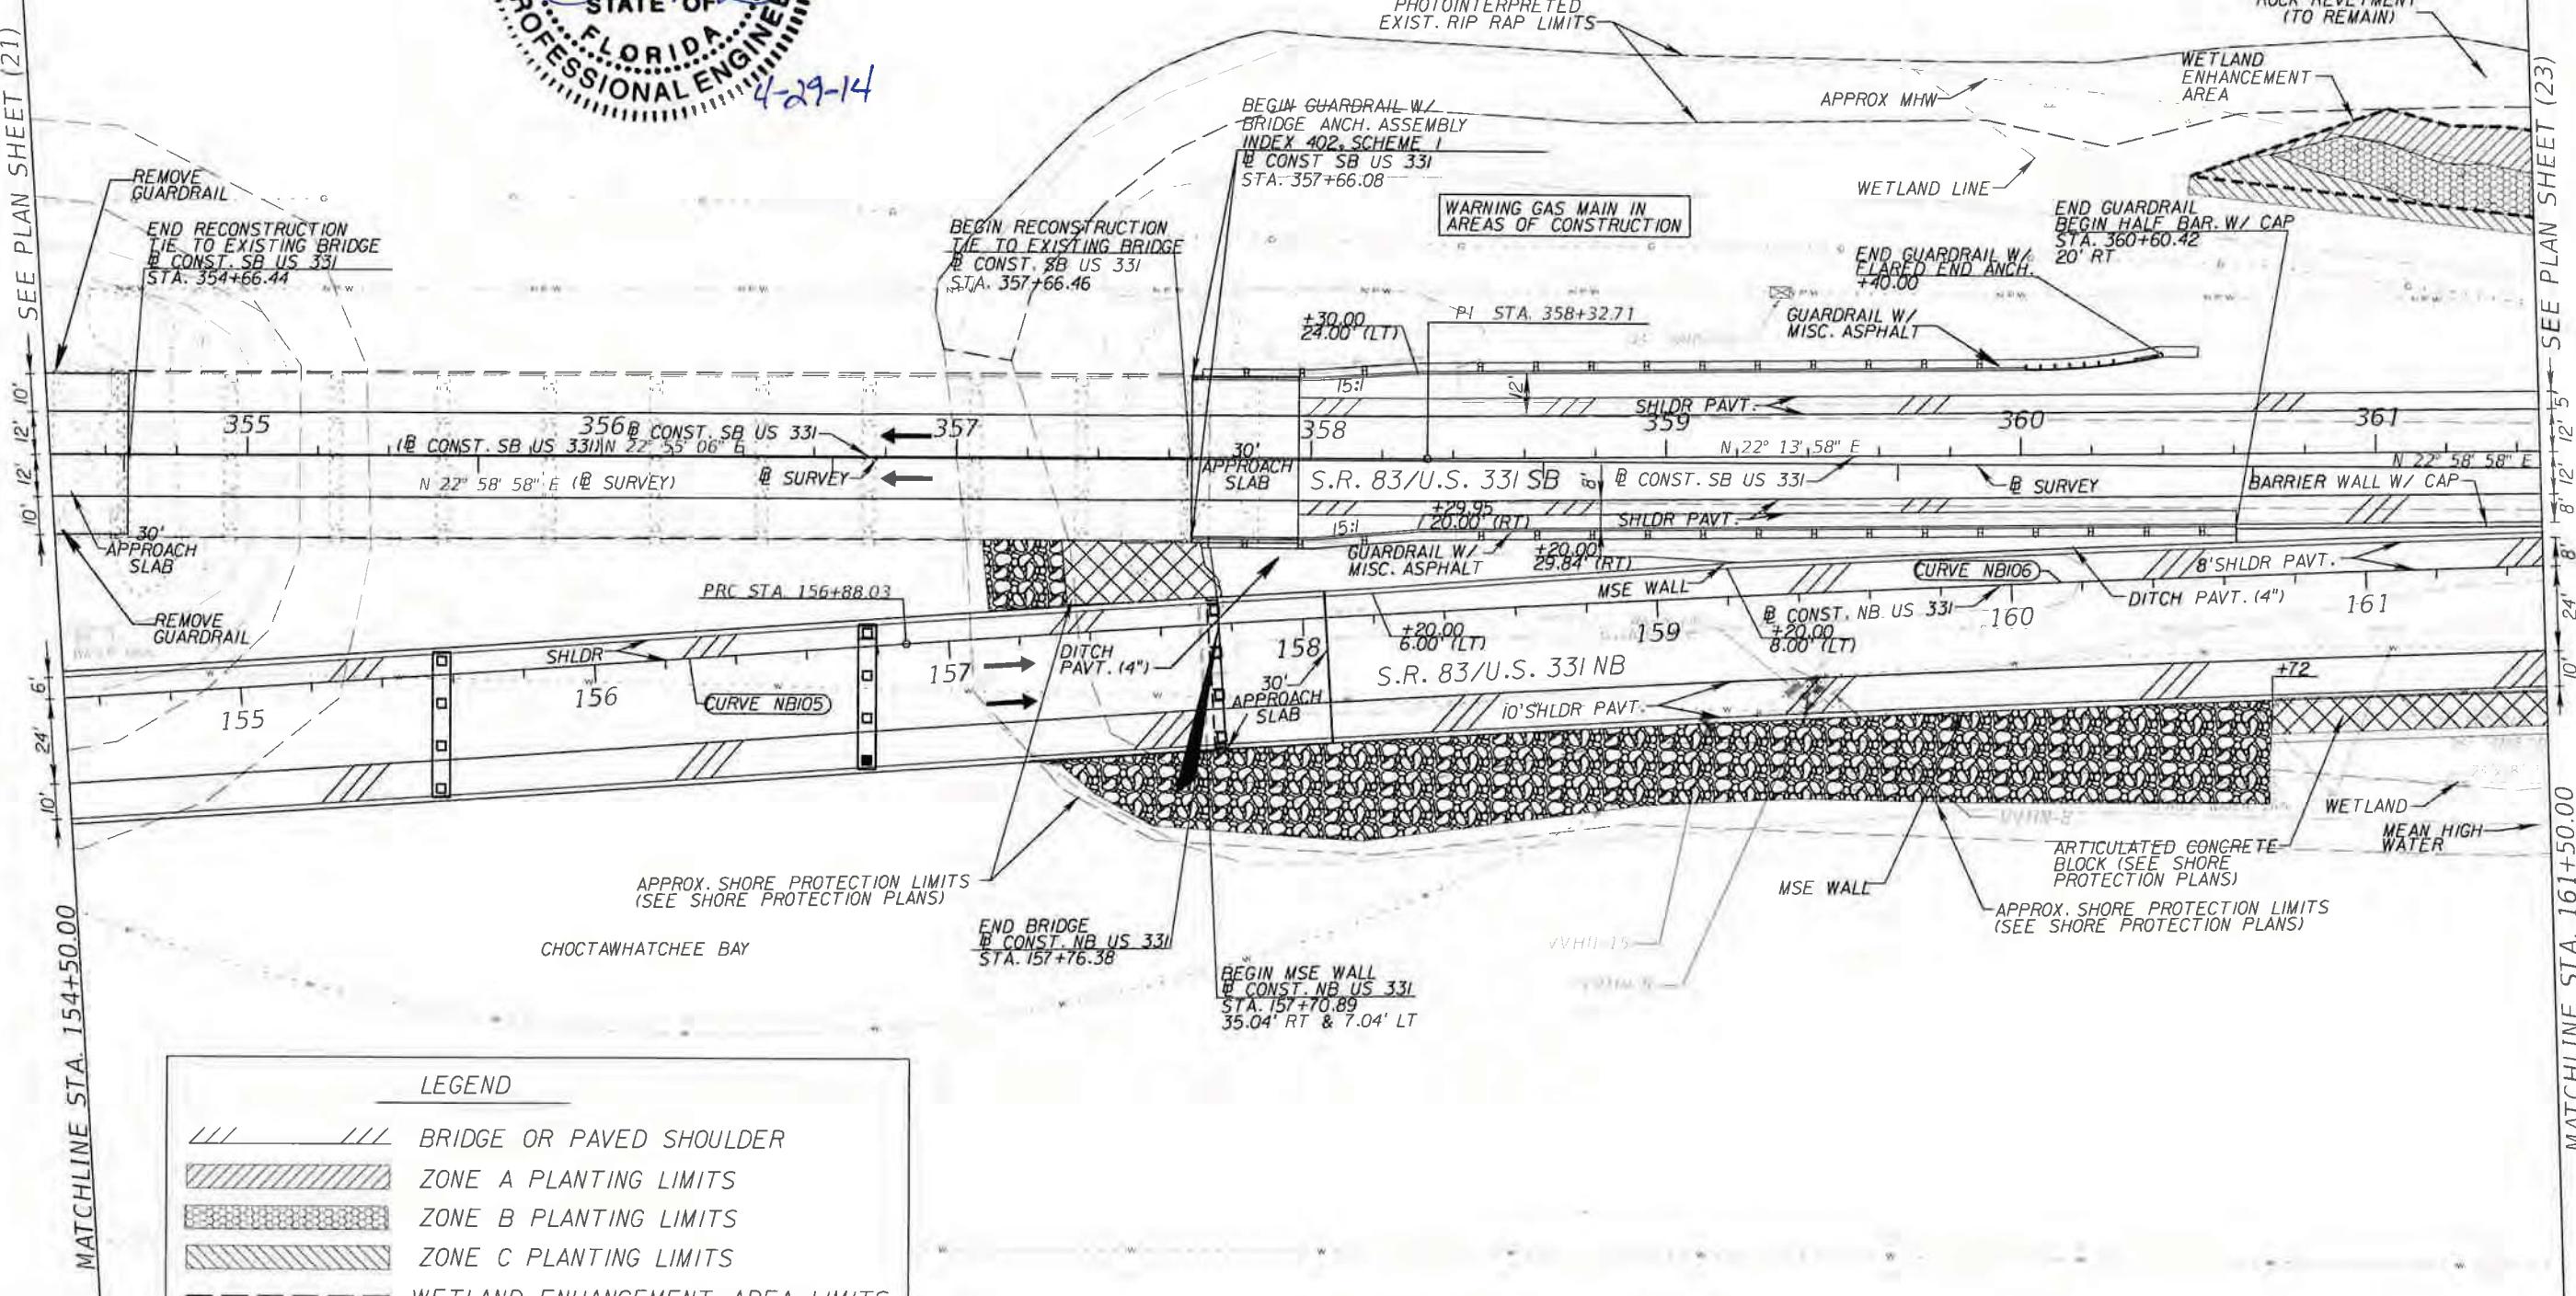

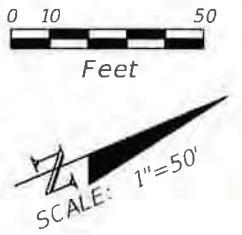


MATCHLINE STA. 161+50.00 SEE PLAN SHEET (22)

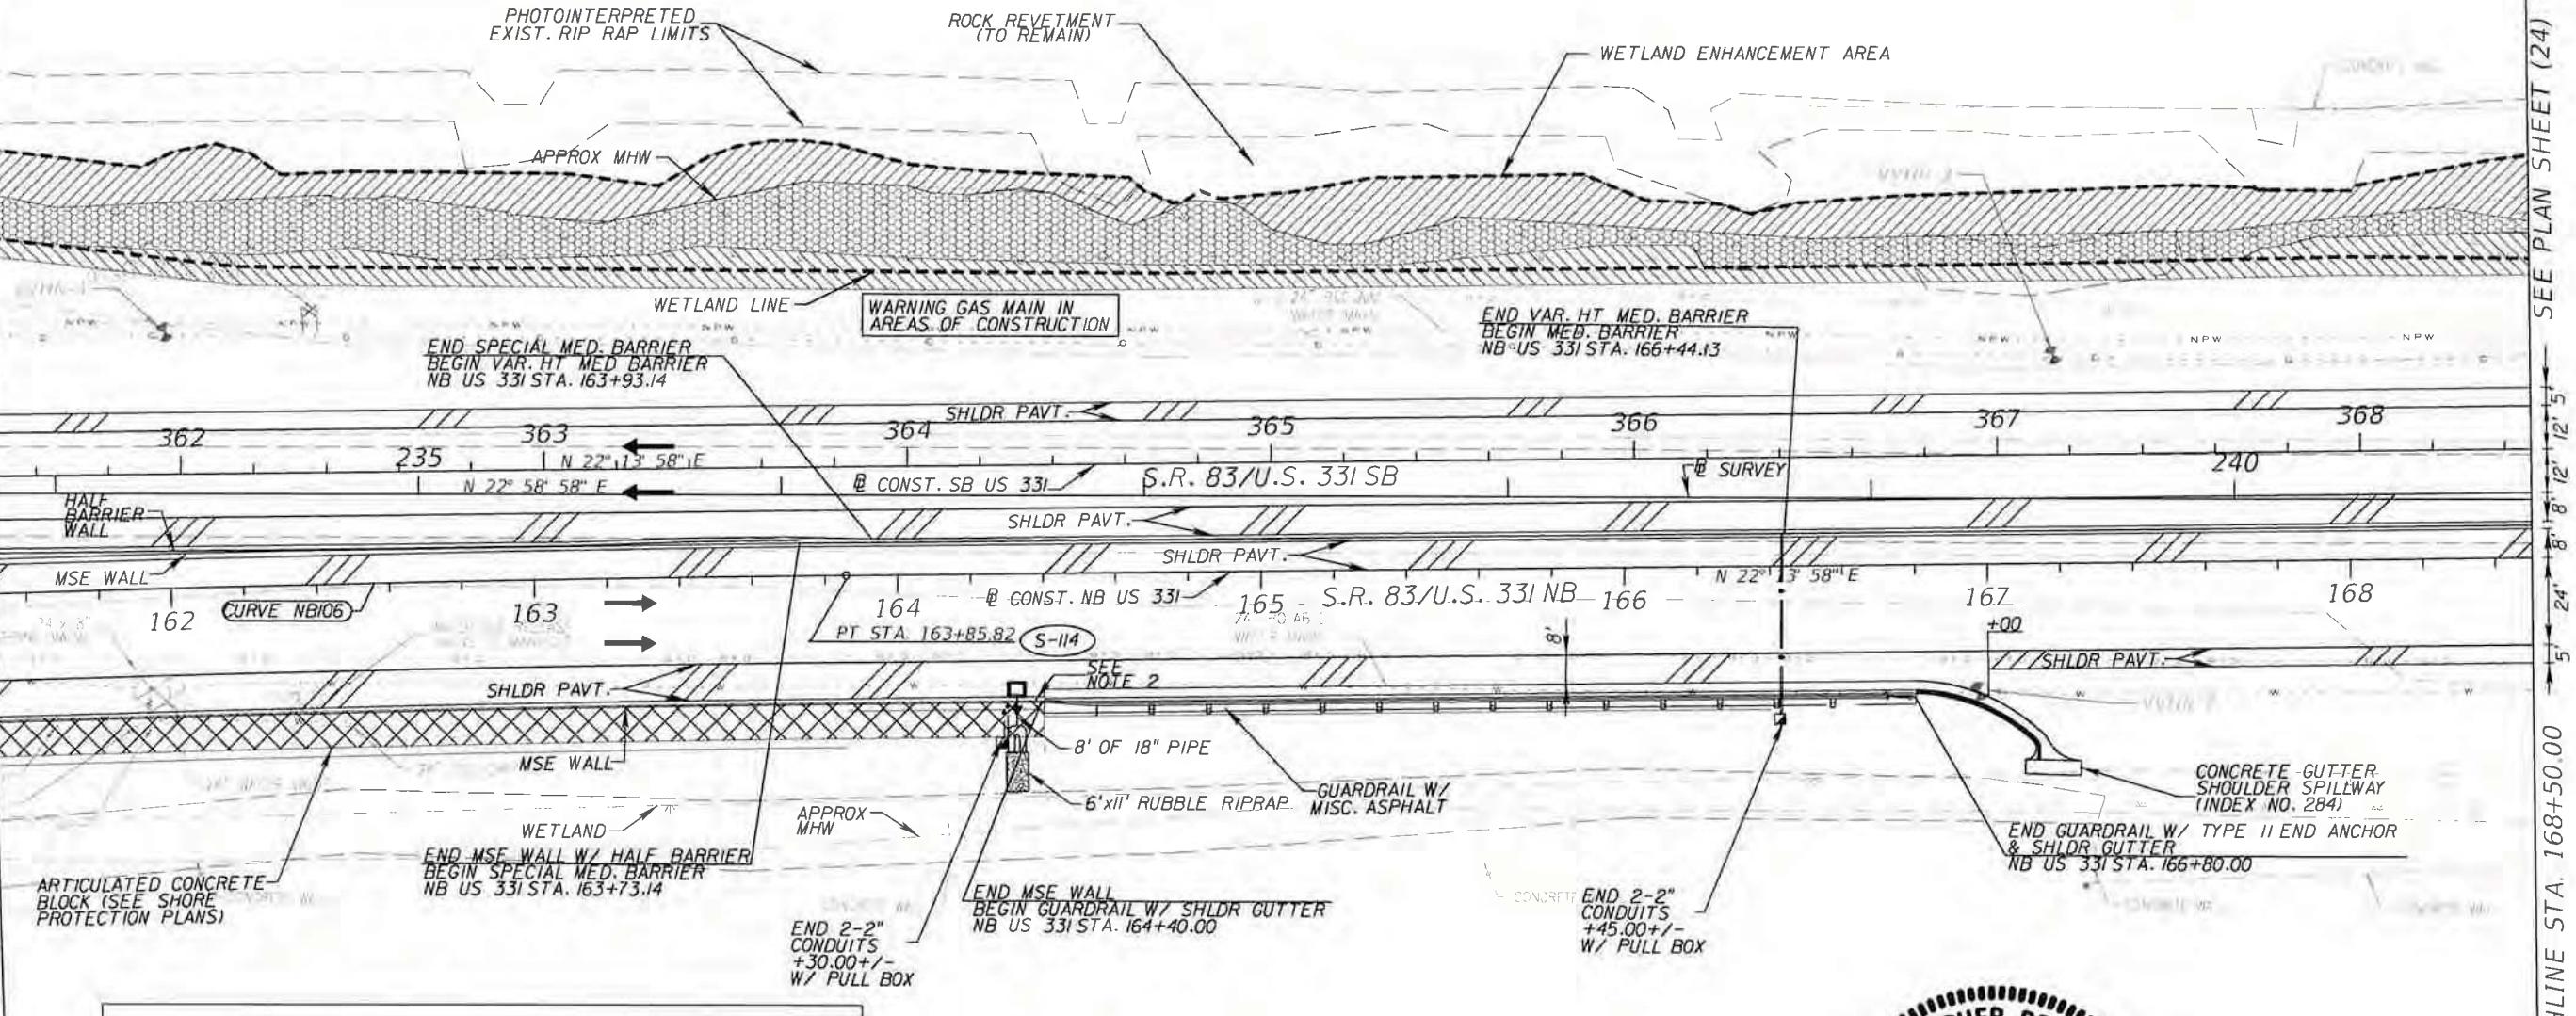

SEE PLAN SHEET (24)

MATCHLINE STA. 168+50.00

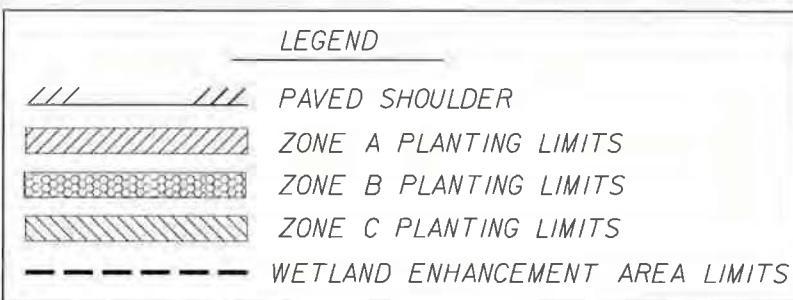

NOTES: 1. FOR SPECIAL MEDIAN BARRIER DESIGN, SEE RETAINING WALL PLANS  
2. FOR MSE WALL TRAFFIC RAILING DETAILS ADJACENT TO DRAINAGE STRUCTURES, REFER TO INDEX 6201.

REVISIONS			
DATE	DESCRIPTION	DATE	DESCRIPTION

Parsons Brinckerhoff, Inc.  
121 W. Trade Street, Suite 1950  
Charlotte, NC 28202  
(704) 342-8469  
Cert. of Auth. No. 01462  
EOR: Christopher D Davis, P.E. No. 63070

STATE OF FLORIDA  
DEPARTMENT OF TRANSPORTATION  
ROAD NO. COUNTY FINANCIAL PROJECT ID  
83 WALTON 220664-2-52-01




PLAN (23)

SHEET NO.  
48

MATCHLINE STA. 168+50.00

SEE PLAN SHEET (23)

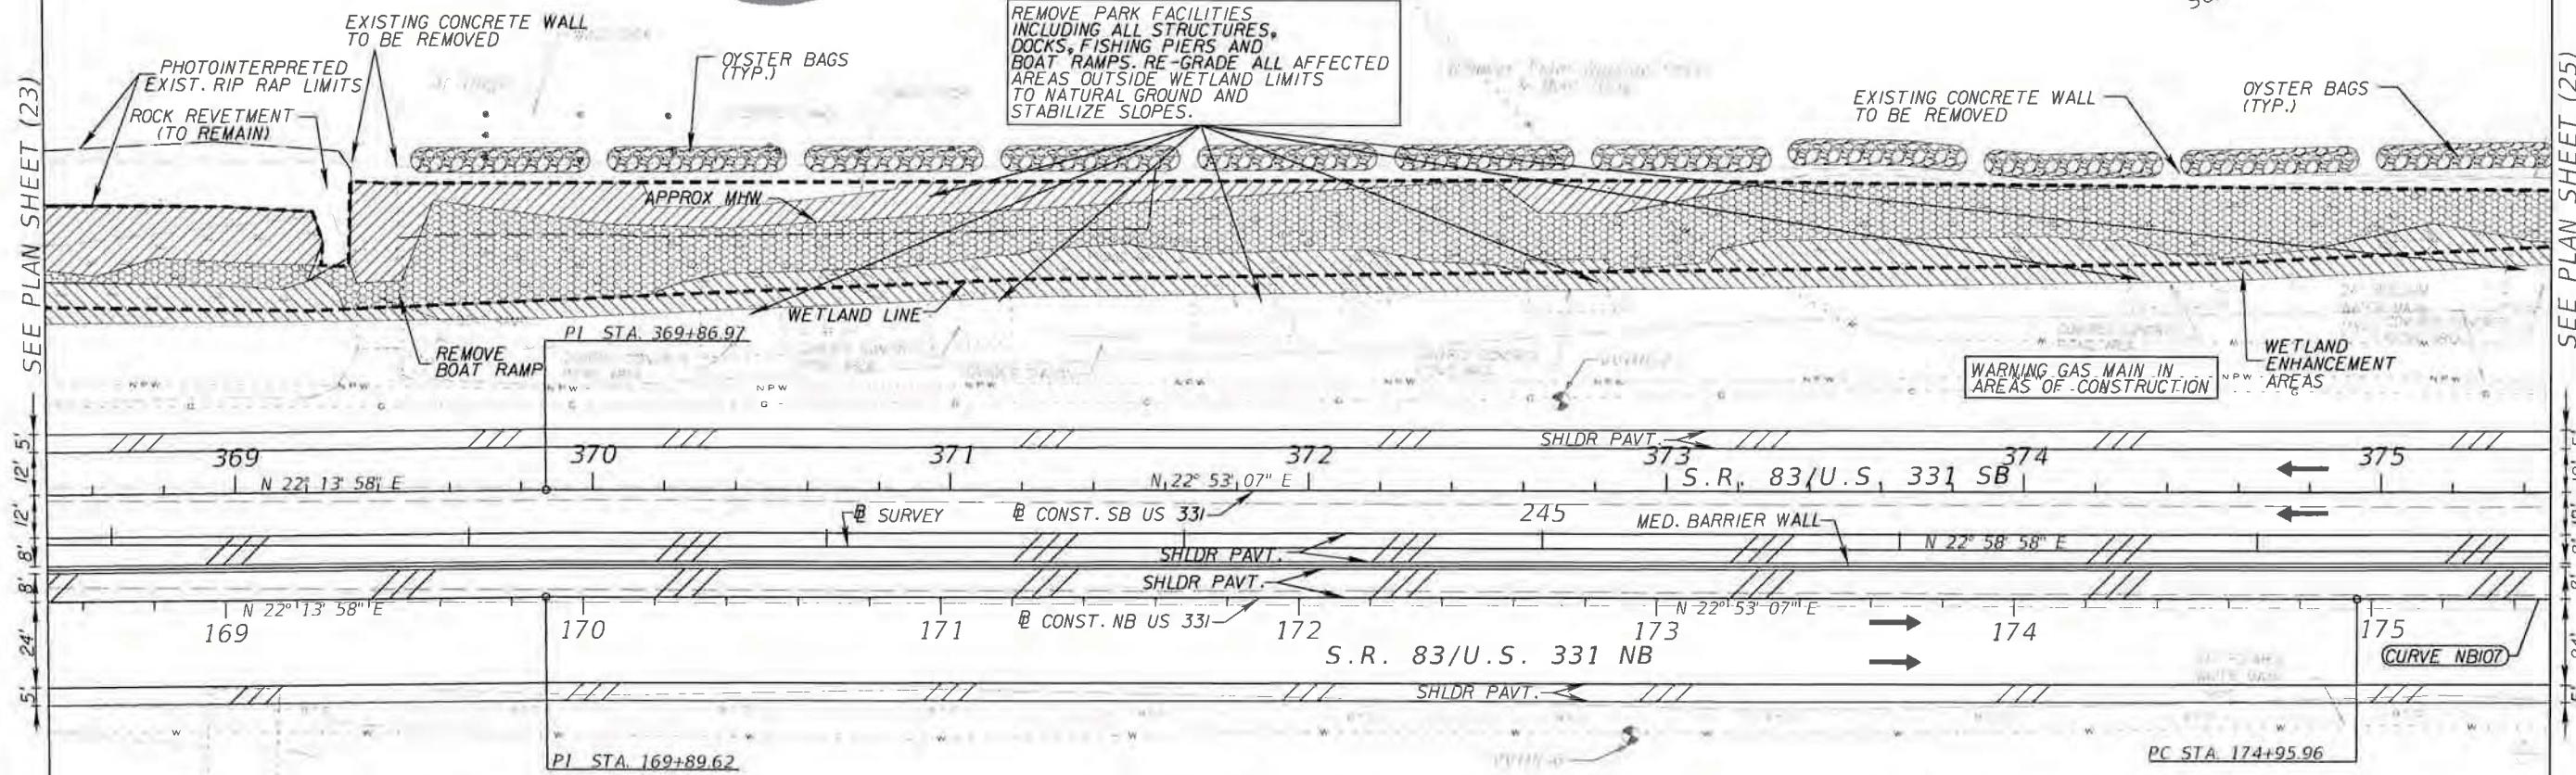

MATCHLINE STA. 175+50.00

SEE PLAN SHEET (25)



REVISIONS			
DATE	DESCRIPTION	DATE	DESCRIPTION

Parsons Brinckerhoff, Inc.  
121 W. Trade Street, Suite 1950  
Charlotte, NC 28202  
(704) 342-8469  
Cert. of Auth. No. 01462  
EOR: Christopher D Davis, P.E. No. 63070


STATE OF FLORIDA  
DEPARTMENT OF TRANSPORTATION  
ROAD NO. COUNTY FINANCIAL PROJECT ID  
83 WALTON 220664-2-52-01



PLAN (24)

SHEET NO.  
49

MATCHLINE STA. 175+50.00 SEE PLAN SHEET (24)

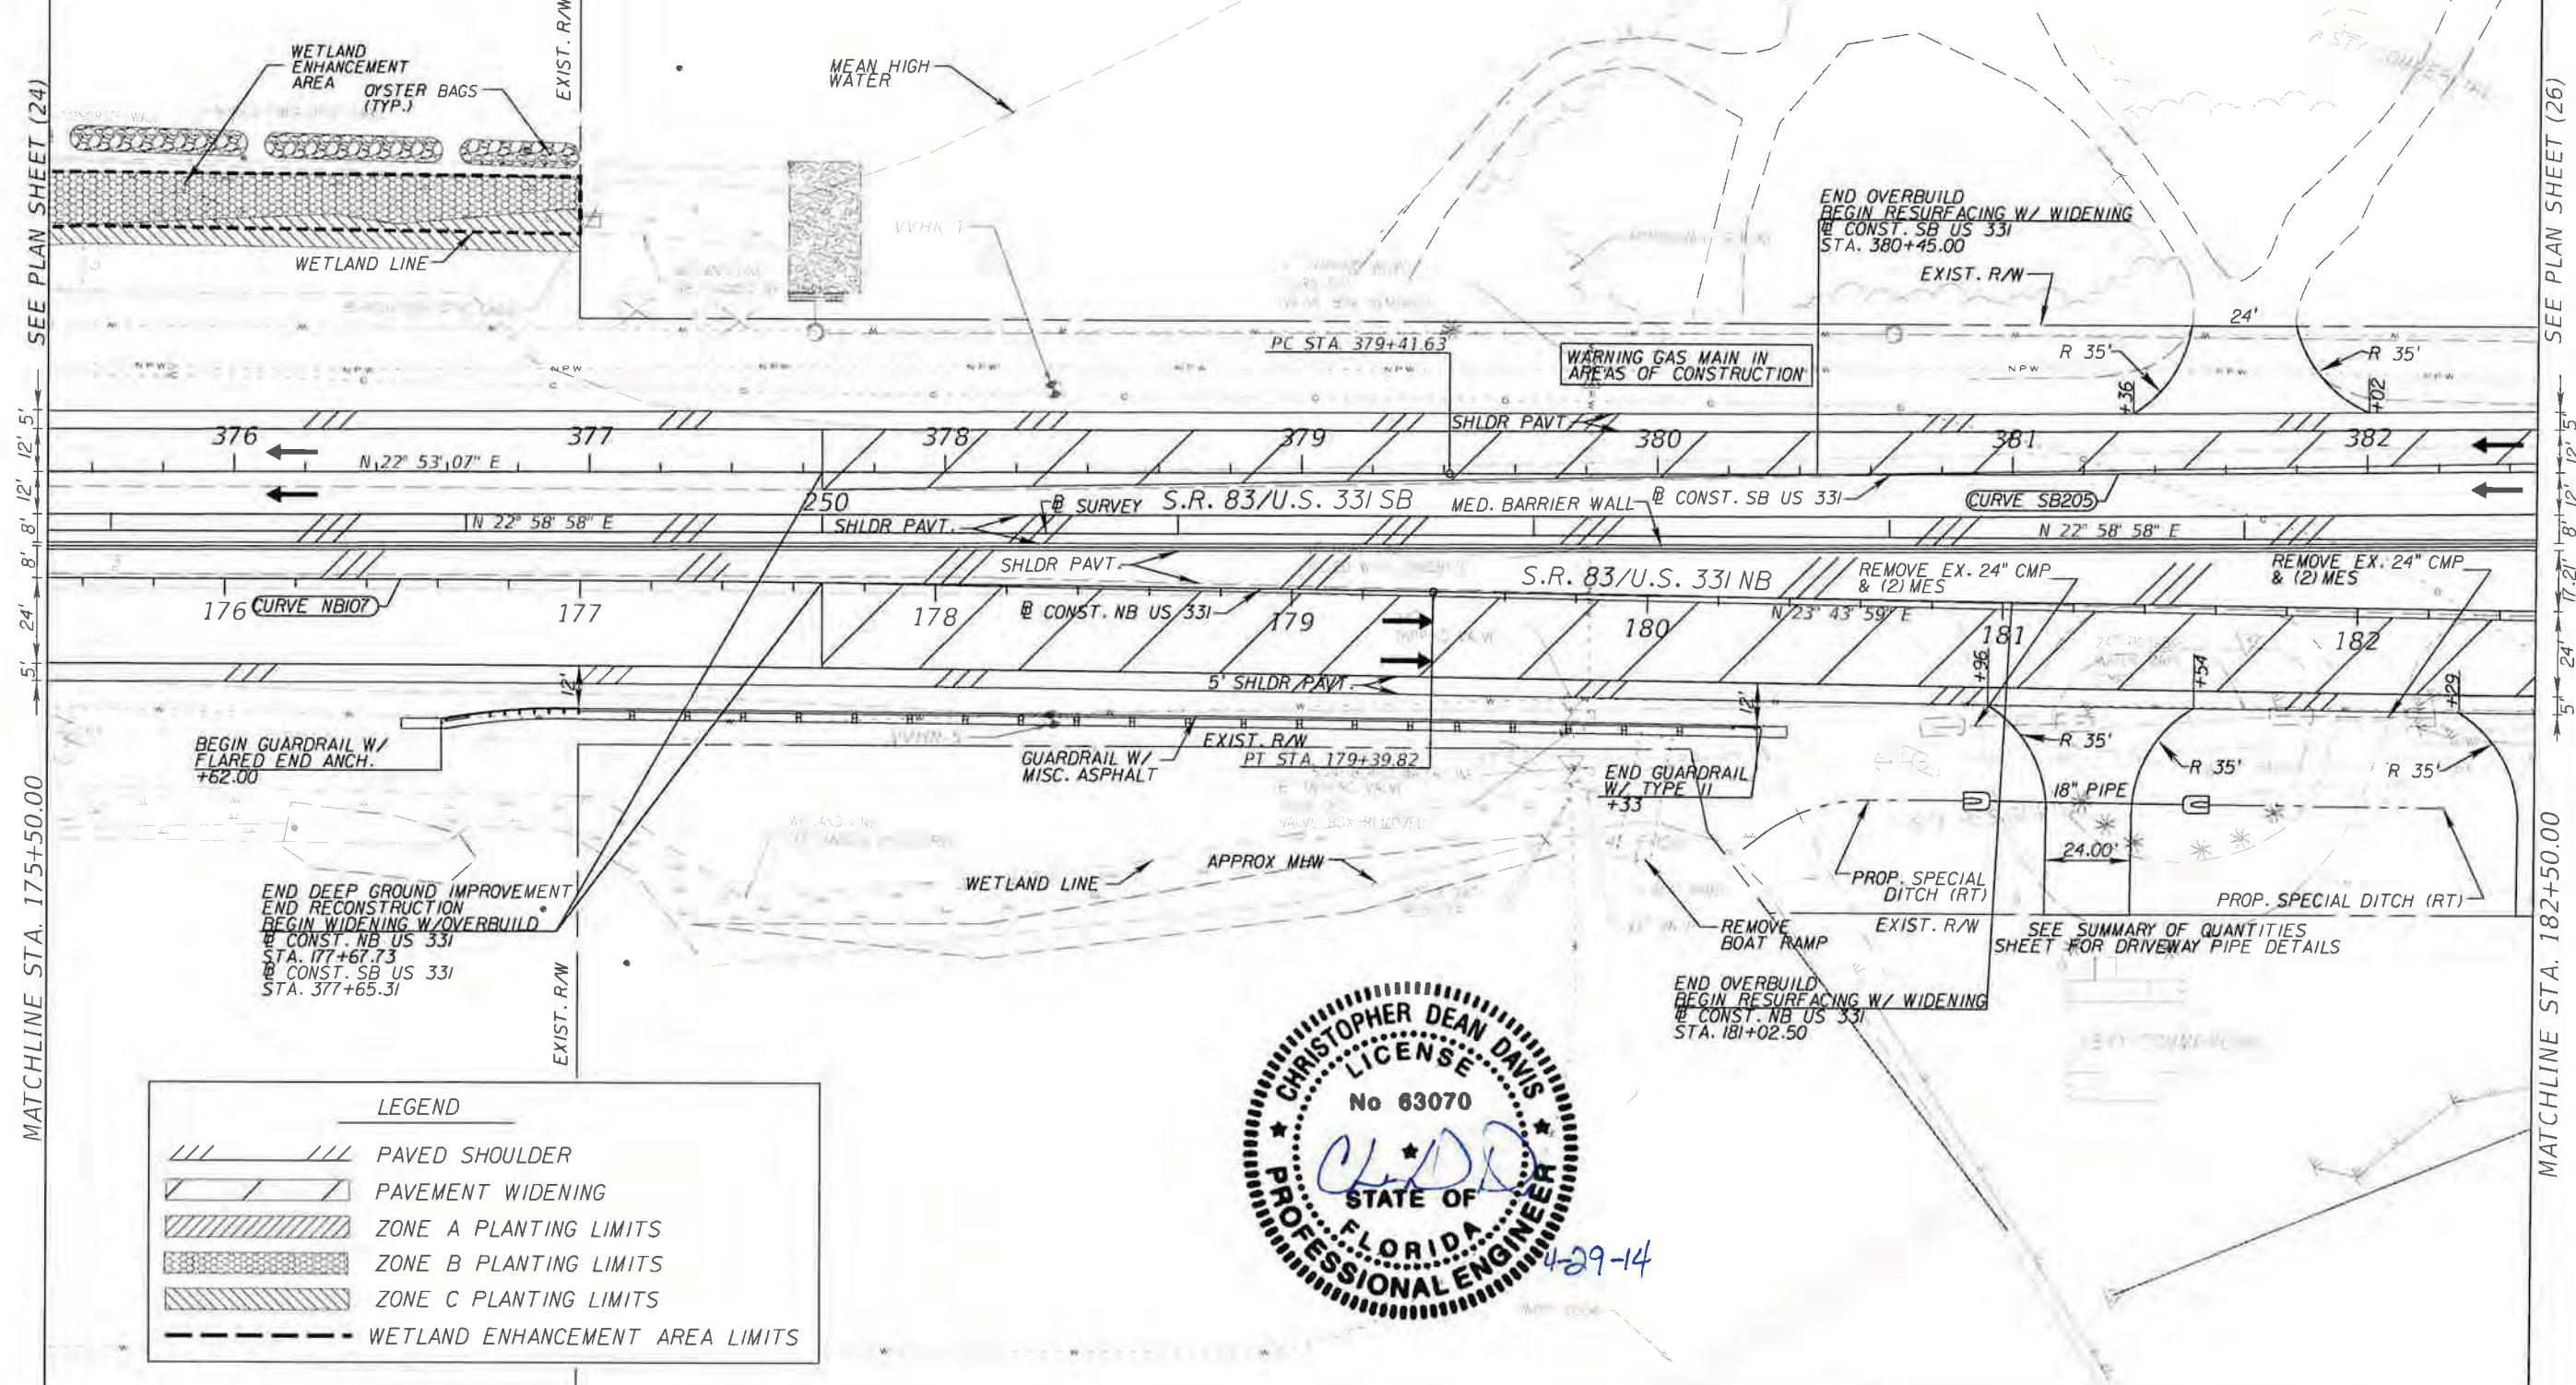

REVISIONS			
DATE	DESCRIPTION	DATE	DESCRIPTION

Parsons Brinckerhoff, Inc.  
121 W. Trade Street, Suite 1950  
Charlotte, NC 28202  
(704) 342-8469  
Cert. of Auth. No. 01462  
EOR: Christopher D Davis, P.E. No. 63070

STATE OF FLORIDA  
DEPARTMENT OF TRANSPORTATION

ROAD NO.	COUNTY	FINANCIAL PROJECT ID
83	WALTON	220664-2-52-01

PLAN (25)

SHEET NO.  
50

Exhibit 2

**STORMWATER OPERATION / MAINTENANCE PLAN**

**AFTER EACH RAINFALL EVENT**

1. **Debris in retention/detention areas** – All debris and foreign material shall be removed immediately
2. **Yard Inlets, Catch Basins, etc.** – All debris and foreign materials shall be removed immediately

**PERIODIC POND/SYSTEM MAINTENANCE**

1. Cleaning/sweeping of pavement areas shall be accomplished monthly if needed.
2. Inspect pond periodically for accumulation of trash and debris and schedule removal activities prior to the next inspection.
3. Mowing and landscaping maintenance should be done no less than three (3) times during the active growing season for this area.
4. Weeds or undesirable growth shall be removed during the next periodic mowing/clean up cycles.
5. Catch basins shall be flushed as necessary (if any).
6. The Maintenance Entity shall re-grade and re-stabilize swale/retention/detention areas as required to maintain the approved design, cross-section, line, and grade.
7. Remove sediment from pond when accumulation reaches four (4) inches.  
Measure accumulation once a year.

**INSPECTIONS**

1. A maintenance inspection must be performed by a registered professional, **one year** after conversion to the Operation Phase and then **every five years thereafter**.
2. The inspection must be conducted using the plans, calculations and specifications approved by the Agency.
3. The maintenance inspection must be documented on Form 62-330.311(1), “Operation and Maintenance Inspection Certification”. The inspection Form must be maintained and made available to Agency staff upon request.

**STANDARD MANATEE AND MARINE TURTLE  
CONSTRUCTION CONDITIONS FOR IN-WATER WORK**

March 2012

The permittee shall comply with the following conditions intended to protect manatees and marine turtles from direct project effects:

- a. All personnel associated with the project shall be instructed about the presence of marine turtles, manatees and manatee speed zones, and the need to avoid collisions with (and injury to) these protected marine species. The permittee shall advise all construction personnel that there are civil and criminal penalties for harming, harassing, or killing manatees which are protected under the Marine Mammal Protection Act, the Endangered Species Act, and the Florida Manatee Sanctuary Act.
- b. All vessels associated with the construction project shall operate at "Idle Speed/No Wake" at all times while in the immediate area and while in water where the draft of the vessel provides less than a four-foot clearance from the bottom. All vessels will follow routes of deep water whenever possible.
- c. Siltation or turbidity barriers shall be made of material in which manatees and marine turtles cannot become entangled, shall be properly secured, and shall be regularly monitored to avoid manatee entanglement or entrapment. Barriers must not impede manatee or marine turtle movement.
- d. All on-site project personnel are responsible for observing water-related activities for the presence of marine turtles and manatee(s). All in-water operations, including vessels, must be shutdown if a marine turtle or manatee comes within 50 feet of the operation. Activities will not resume until the animal(s) has moved beyond the 50-foot radius of the project operation, or until 30 minutes elapses if the animal(s) has not reappeared within 50 feet of the operation. Animals must not be herded away or harassed into leaving.
- e. Any collision with or injury to a marine turtle or manatee shall be reported immediately to the Florida Fish and Wildlife Conservation Commission (FWC) Hotline at 1-888-404-3922, and to FWC at [ImperiledSpecies@myFWC.com](mailto:ImperiledSpecies@myFWC.com). Collision and/or injury should also be reported to the U.S. Fish and Wildlife Service (for north Florida, Jacksonville 1-904-731-3336 or for south Florida Vero Beach 1-772-562-3909).
- f. Temporary signs concerning manatees shall be posted prior to and during all in-water project activities. All signs are to be removed by the permittee upon completion of the project. Temporary signs that have already been approved for this use by the FWC must be used. One sign which reads *Caution: Boaters* must be posted. A second sign measuring at least 8 ½" by 11" explaining the requirements for "Idle Speed/No Wake" and the shut down of in-water operations must be posted in a location prominently visible to all personnel engaged in water-related activities. These signs can be viewed at MyFWC.com/manatee. Questions concerning these signs can be sent to the email address listed above.
- g. Lighting on offshore or onshore equipment including dredge, crew boats, and all ancillary vessels shall be minimized through reduction, shielding, lowering, and appropriate placement to avoid excessive illumination of the water's surface and visibility from adjacent marine turtle nesting beaches while meeting all Coast Guard, EM 385-1-1, and OSHA requirements. Light intensity of all fixtures on the vessels shall be reduced to the minimum standard required by OSHA for General Construction areas, in order not to misdirect marine turtles. Lights used to survey nearshore or inlet waters for manatees and sea turtles shall be mounted as low as possible and aimed to minimize visibility from adjacent nesting beaches. Shields shall be affixed to the light housing and be large enough to block light from all lamps from being transmitted outside the construction area.

# **CAUTION: MANATEE HABITAT**

**All project vessels**

**IDLE SPEED / NO WAKE**

When a manatee is within 50 feet of work  
all in-water activities must


**SHUT DOWN**

Report any collision with or injury to a manatee:

**Wildlife Alert:**

**1-888-404-FWCC(3922)**

**cell \*FWC or #FWC**

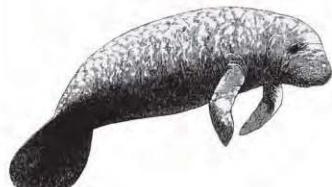



**UNITED STATES DEPARTMENT OF COMMERCE**  
**National Oceanic and Atmospheric Administration**  
**NATIONAL MARINE FISHERIES SERVICE**  
 Southeast Regional Office  
 263 13th Avenue South  
 St. Petersburg, FL 33701

## **SEA TURTLE AND SMALLTOOTH SAWFISH CONSTRUCTION CONDITIONS**

The permittee shall comply with the following protected species construction conditions:

- a. The permittee shall instruct all personnel associated with the project of the potential presence of these species and the need to avoid collisions with sea turtles and smalltooth sawfish. All construction personnel are responsible for observing water-related activities for the presence of these species.
- b. The permittee shall advise all construction personnel that there are civil and criminal penalties for harming, harassing, or killing sea turtles or smalltooth sawfish, which are protected under the Endangered Species Act of 1973.
- c. Siltation barriers shall be made of material in which a sea turtle or smalltooth sawfish cannot become entangled, be properly secured, and be regularly monitored to avoid protected species entrapment. Barriers may not block sea turtle or smalltooth sawfish entry to or exit from designated critical habitat without prior agreement from the National Marine Fisheries Service's Protected Resources Division, St. Petersburg, Florida.
- d. All vessels associated with the construction project shall operate at “no wake/idle” speeds at all times while in the construction area and while in water depths where the draft of the vessel provides less than a four-foot clearance from the bottom. All vessels will preferentially follow deep-water routes (e.g., marked channels) whenever possible.
- e. If a sea turtle or smalltooth sawfish is seen within 100 yards of the active daily construction/dredging operation or vessel movement, all appropriate precautions shall be implemented to ensure its protection. These precautions shall include cessation of operation of any moving equipment closer than 50 feet of a sea turtle or smalltooth sawfish. Operation of any mechanical construction equipment shall cease immediately if a sea turtle or smalltooth sawfish is seen within a 50-ft radius of the equipment. Activities may not resume until the protected species has departed the project area of its own volition.
- f. Any collision with and/or injury to a sea turtle or smalltooth sawfish shall be reported immediately to the National Marine Fisheries Service's Protected Resources Division (727-824-5312) and the local authorized sea turtle stranding/rescue organization.
- g. Any special construction conditions, required of your specific project, outside these general conditions, if applicable, will be addressed in the primary consultation.

Revised: March 23, 2006

O:\forms\Sea Turtle and Smalltooth Sawfish Construction Conditions.doc



## Exhibit 5

### CONSTRUCTION SPECIAL PROVISIONS GULF STURGEON PROTECTION GUIDELINES (PURSUANT TO NMFS AND USFWS)

The Gulf sturgeon (*Acipenser oxyrinchus desotoi*) is listed under the Endangered Species Act as threatened. It is managed under the joint jurisdiction of the National Marine Fisheries Service (NMFS) and the U.S. Fish and Wildlife Service (USFWS). Potential habitat for the Gulf sturgeon is located within the limits of this project.

The following special provisions will be incorporated into any construction contract where involvement with sturgeon may occur:

The FDOT has coordinated with the NMFS and USFWS early in the project development stage. The following provisions are intended to avoid/ protect known spawning habitats, nursery areas, feeding areas and thermal refuges.

1. The Florida Department of Transportation (FDOT) shall advise all FDOT project personnel and Contractor personnel on the project that there are civil and criminal penalties for harming, harassing or killing sturgeon. The FDOT and the Contractor will be held responsible for any sturgeon harmed, harassed, or killed as a result of the project activity.
2. The FDOT shall provide information to all FDOT and Contract personnel for identification of sturgeon.
3. Appropriate work shift personnel will be instructed in the appearance, habits, biology, migratory patterns, and preservation of sturgeon. At least one of these trained personnel will be on site during construction activities to maintain a constant surveillance for these species, assure the cessation of activities (such as dredging, excess turbidity, and construction barge activity), which may endanger these species, and assure that uninhibited passage for the animals is provided.
4. Post signs on site warning of the presence of sturgeon, of their endangered status and federal protection, and precautions needed.
5. Turbidity from construction activity will be adequately controlled to prevent degradation of the quality and transparency of the water. When sturgeon are present, turbidity curtains of appropriate dimension will be used to restrict the animals' access to the work area. Pollution booms or turbidity curtains should use tangle resistant or hemp rope when anchoring, or employ surface anchors' to prevent entangling sturgeon. Continuous surveillance will be maintained in order to free animals which may become trapped in silt or turbidity barriers.
6. No dredging of the river bottom will be conducted for barge access.

7. Drilled shaft pile construction will be used whenever prudent and feasible as determined by FDOT.
8. Care shall be taken in lowering equipment or material below the water surface and into the stream bed. These precautions will be taken to ensure no harm occurs to any sturgeon which may enter the construction area undetected.
9. Construction debris shall not be discarded into the water.
10. If the use of explosives is necessary, the following protection measures will be employed for projects in FDOT's District 3
  - a. In riverine areas:
    - No blasting will occur in known spawning, staging, feeding, or nursery areas.
    - In-water explosive work should be avoided between the months of April to October.
    - If explosive work becomes necessary within the April to October time frame, a non-lethal "Fish Scare" charge will be detonated one minute prior to detonation of the underwater blast.
  - b. In estuarine areas:
    - No blasting will occur in known spawning, staging, feeding, or nursery areas.
    - In-water explosive work should be avoided between the months of October to April.
    - If explosive work becomes necessary within the October to April time frame, a non-lethal "Fish Scare" charge will be detonated one minute prior to detonation of the underwater blast.
  - c. In the event that a sturgeon is killed during blasting, the NMFS and the USFWS will be notified immediately.

National Marine Fisheries Service  
by email at:  
[takereport.nmfsser@noaa.gov](mailto:takereport.nmfsser@noaa.gov)

US Fish and Wildlife Service  
1601 Balboa Ave.  
Panama City, Florida 32405  
Tel: (850) 769-0552

11. Any sturgeon carcass will be secured on site or held in a freezer until an agency representative arranges for its transport for analysis.
12. Following completion of the project, a report summarizing any involvement with sturgeon will be prepared for USFWS and NMFS.